

ELECTRICAL LEGEND	
SYMBOL	DESCRIPTION
	2x4 LIGHT FIXTURE, RECESSED OR SURFACE MOUNTED LETTER INDICATES FIXTURE TYPE. SEE LIGHTING FIXTURE SCHEDULE. HALF SHADING INDICATES EMERGENCY FIXTURE.
	2x2 LIGHT FIXTURE, RECESSED OR SURFACE MOUNTED LETTER INDICATES FIXTURE TYPE. SEE LIGHTING FIXTURE SCHEDULE
	4FT OR 8FT LIGHT FIXTURE, RECESSED OR SURFACE MOUNTED LETTER INDICATES FIXTURE TYPE. SEE LIGHTING FIXTURE SCHEDULE HEAVY LINE INDICATES FIXTURE IS CONNECTED TO CRITICAL POWER SYSTEM
	4FT OR 8FT CHANNEL LIGHT FIXTURE, SUSPENDED OR SURFACE MOUNTED LETTER INDICATES FIXTURE TYPE. SEE LIGHTING FIXTURE SCHEDULE
	UNDER COUNTER LIGHT FIXTURE LETTER INDICATES FIXTURE TYPE. SEE LIGHTING FIXTURE SCHEDULE
	STAGGER STRIP LIGHT FIXTURE, SURFACE MOUNTED IN LIGHTING COVE LETTER INDICATES FIXTURE TYPE. SEE LIGHTING FIXTURE SCHEDULE
	DIRECT/INDIRECT FIXTURE, SUSPENDED LETTER INDICATES FIXTURE TYPE. SEE LIGHTING FIXTURE SCHEDULE
	RECESSED LIGHT FIXTURE LETTER INDICATES FIXTURE TYPE. SEE LIGHTING FIXTURE SCHEDULE
	SURFACE LIGHT FIXTURE LETTER INDICATES FIXTURE TYPE. SEE LIGHTING FIXTURE SCHEDULE
	WALL MOUNTED LIGHT FIXTURE LETTER INDICATES FIXTURE TYPE. SEE LIGHTING FIXTURE SCHEDULE
**FOR ALL LIGHTING TYPES ABOVE: -A HEAVY LINE THROUGH A FIXTURE SHOWS THE FIXTURE IS CONNECTED TO THE CRITICAL BRANCH POWER SYSTEM. -A FIXTURE HALF SHADED SHOWS THE FIXTURE IS ON THE LIFE SAFETY BRANCH POWER SYSTEM.	
	RACEWAY CONCEALED ABOVE CEILING OR IN WALL
	RACEWAY CONCEALED BELOW FLOOR OR SLAB
	RACEWAY EXPOSED ON WALL OR CEILING
	CONDUIT, HOMERUN TO PANEL BOARD
	EXIT SIGN, SINGLE FACE, CEILING, ARROW INDICATES DIRECTION. LETTER INDICATES FIXTURE TYPE. SEE LIGHTING FIXTURE SCHEDULE
	EXIT SIGN, DOUBLE FACE, CEILING MOUNTED, ARROW INDICATES DIRECTION. LETTER INDICATES FIXTURE TYPE. SEE LIGHTING FIXTURE SCHEDULE
	EXIT SIGN W/EMERGENCY LIGHTING UNIT, CEILING MOUNTED, ARROW INDICATES DIRECTION. LETTER INDICATES FIXTURE TYPE. SEE LIGHTING FIXTURE SCHEDULE
	EXIT SIGN, SINGLE FACE, WALL/END MOUNTED, ARROW INDICATES DIRECTION. LETTER INDICATES FIXTURE TYPE. SEE LIGHTING FIXTURE SCHEDULE
	EXIT SIGN, DOUBLE FACE, WALL/END MOUNTED, ARROW INDICATES DIRECTION. INDICATES FIXTURE TYPE. SEE LIGHTING FIXTURE SCHEDULE
	EXIT SIGN W/EMERGENCY LIGHTING UNIT, WALL/END MOUNTED, ARROW INDICATES DIRECTION. INDICATES FIXTURE TYPE. SEE LIGHTING FIXTURE SCHEDULE
	EMERGENCY LIGHTING UNIT, 2-HEAD WITH BATTERY BACK-UP, WALL MOUNTED, "NOT SWITCHED" LETTER INDICATES FIXTURE TYPE. SEE LIGHTING FIXTURE SCHEDULE
	PHOTOCELL, REMOTE MOUNTED, 120V, 10 SECOND TIME DELAY, UL WET LOCATION, RATED FOR 1500 W @ 120 VAC AND 4000 W @ 277 VAC (FOR USE WITH LAMP SOURCE(S) SHOWN)
	SWITCH, SINGLE POLE, 120/277VAC, 20A, MOUNTED AT 46" AFF UNLESS OTHERWISE NOTED, SEE ELECTRICAL MOUNTING HEIGHT DETAIL. LOWER CASE LETTER INDICATES FIXTURE SWITCHING, WHEN INDICATED
	3-WAY SWITCH, 120/277 VAC, 20A, MOUNTED AT 46" AFF UNLESS OTHERWISE NOTED
	4-WAY SWITCH 120/277 VAC, 20A, MOUNTED AT 46" AFF UNLESS OTHERWISE NOTED
	WEATHERPROOF SWITCH, SINGLE POLE 120/277 VAC, 20A, MOUNTED AT 46" AFF UNLESS OTHERWISE NOTED
	PILOT LIGHT SWITCH 120/277 VAC, 20A, MOUNTED AT 46" AFF UNLESS OTHERWISE NOTED
	3-WAY PILOT LIGHT SWITCH 120/277 VAC, 20A, MOUNTED AT 46" AFF UNLESS OTHERWISE NOTED
	4-WAY PILOT LIGHT SWITCH 120/277 VAC, 20A, MOUNTED AT 46" AFF UNLESS OTHERWISE NOTED
	SNAP SWITCH, 20A, 208V MINIMUM RATING, LARGER AS REQUIRED BY EQUIPMENT, MOUNTED AT 46" AFF UNLESS OTHERWISE NOTED
	HEAVY DUTY LINE VOLTAGE DIMMER,1500W @ 120 VAC AND 4000W @ 277 VAC, 0-10V (IF REQUIRED) SINGLE POLE, 20A, MOUNTED AT 46" AFF UNLESS OTHERWISE NOTED LOWER CASE LETTER INDICATES FIXTURE SWITCHING (WHEN INDICATED)
	THREE WAY HEAVY DUTY LINE VOLTAGE DIMMER,1500W @ 120 VAC AND 4000W @ 277 VAC, 0-10V (IF REQUIRED) SINGLE POLE, 20A, MOUNTED AT 46" AFF UNLESS OTHERWISE NOTED LOWER CASE LETTER INDICATES FIXTURE SWITCHING (WHEN INDICATED)
	ADJUSTABLE FAN CONTROL, 120/277VAC, SINGLE POLE, 20A, MOUNTED AT 46" AFF UNLESS OTHERWISE NOTED (SEE ELECTRICAL MOUNTING HEIGHT DETAIL). LOWER CASE LETTER INDICATES FIXTURE SWITCHING (WHEN INDICATED)
	MANUAL MOTOR STARTER (SENTINEL)TOGGLE SWITCH
	CEILING MOUNTED DUAL TECHNOLOGY OCCUPANCY SENSOR, 360° COVERAGE 2 = SECOND CONTACT TO BE PROVIDED FOR CONNECTION TO BUILDING MANAGEMENT
	CEILING MOUNTED OCCUPANCY SENSOR, LONG RANGE COVERAGE 2 = SECOND CONTACT TO BE PROVIDED FOR CONNECTION TO BUILDING MANAGEMENT
	WALL MOUNTED OCCUPANCY SENSOR, 180° COVERAGE 2 = SECOND CONTACT TO BE PROVIDED FOR CONNECTION TO BUILDING MANAGEMENT
	WALL MOUNTED OCCUPANCY SENSOR, PIR TECHNOLOGY OCCUPANCY SENSOR, LOW VOLTAGE (24VDC) 19mA DRAW, WATTSTOPPER CX100-1, LONG RANGE SENSOR. INSTALL WHERE FREE OF OBSTRUCTIONS.
	WALL MOUNTED OCCUPANCY SENSOR, PIR TECHNOLOGY OCCUPANCY SENSOR, LOW VOLTAGE (24VDC) 19mA DRAW, WATTSTOPPER CX100-3, TWO SIDED AISLEWAY. INSTALL WHERE FREE OF OBSTRUCTIONS.
	WALL MOUNTED OCCUPANCY SENSOR, SINGLE BUTTON ON/OFF CONTROL, 180° COVERAGE, MOUNTED AT 46" AFF UNLESS OTHERWISE NOTED.
	WALL MOUNTED DUAL TECH OCCUPANCY SENSOR, DUAL BUTTON ON/OFF CONTROL WITH 0-10V DIMMING, 180° COVERAGE, MOUNTED AT 46" AFF UNLESS OTHERWISE NOTED. WATTSTOPPER DW-311 OR EQUAL.
	WALL MOUNTED DUAL TECHNOLOGY OCCUPANCY SENSOR, DUAL BUTTON ON/OFF CONTROL, 180° COVERAGE, ADDITIONAL POWER SUPPLY FOR FAN OPERATION, MOUNTED AT 46" AFF UNLESS OTHERWISE NOTED.

SYMBOL	DESCRIPTION
	RECESSED GANG BOX WITH BLANK COVER PLATE, MOUNTED 16" AFF, UNLESS OTHERWISE NOTED
	RECESSED SINGLE OUTLET, 120VAC, 20A, MOUNTED AS INDICATED ON DRAWING.
	RECEPTACLE, DUPLEX, 120VAC, 20A, MOUNTED 16" AFF, UNLESS OTHERWISE NOTED.
	RECEPTACLE, DUPLEX, 120VAC, 20A, MOUNTED 6" ABOVE COUNTER TOP OR BACK SPLASH.
	RECEPTACLE, QUADPLEX, 120VAC, 20A MOUNTED 16"AFF UNLESS OTHERWISE NOTED
	RECEPTACLE, QUADPLEX, 120VAC, 20A, MOUNTED 6" ABOVE COUNTER TOP OR BACK SPLASH.
	RECEPTACLE, DUPLEX, GROUND FAULT CIRCUIT INTERRUPTER TYPE, 120VAC, 20A, MOUNTED 16" AFF, UNLESS OTHERWISE NOTED.
	RECEPTACLE, DUPLEX, GROUND FAULT CIRCUIT INTERRUPTER TYPE, 120VAC, 20A, MOUNTED 6" ABOVE COUNTER TOP OR BACK SPLASH.
	RECEPTACLE, QUADPLEX, GROUND FAULT CIRCUIT INTERRUPTER TYPE, 120VAC, 20A MOUNTED 16"AFF UNLESS OTHERWISE NOTED
	RECEPTACLE, QUADPLEX, GROUND FAULT CIRCUIT INTERRUPTER TYPE, 120VAC, 20A, MOUNTED 6" ABOVE COUNTER TOP OR BACK SPLASH.
	RECEPTACLE, 208VAC, 2 POLE, 3 WIRE, WALL MOUNTED, NEMA6-15R, UON
	RECEPTACLE, DUPLEX, 120VAC, 20A CEILING MOUNTED (LAY-IN / GYPBOARD / SUSPENDED)
	RECEPTACLE, DUPLEX, 120VAC, 20A FLOOR BOX, SIMILAR TO HUBBELL AFB10G55 WITH MOUNTING CUP HUBBELL CFB81R4CUP AND COVER CFB81R4CVRBRS. POWER BY CONTRACTOR.
**FOR ALL RECEPTACLE TYPES ABOVE: +XX"- INDICATES MOUNTING HEIGHT OF DEVICE IN INCHES AFF (IF GIVEN). SEE ELECTRICAL MOUNTING HEIGHT DETAIL WP - LISTED WEATHER-RESISTANT TYPE DEVICE WITH WEATHERPROOF IN USE COVER TR - TAMPER RESISTANT	
	SAFETY SWITCH, FUSED, HEAVY DUTY, SIZE AS INDICATED ON MECHANICAL EQUIPMENT CONNECTIONS SCHEDULE. SHEET E0.5, PROVIDE NEUTRAL BAR AS REQUIRED ##A = DISCONNECT SIZE / # = NUMBER OF POLES / # = NEMA RATING, / ##AF = FUSE SIZE
	ENCLOSED CIRCUIT BREAKER, SIZE AS INDICATED ON DRAWINGS ##A = BREAKER SIZE / # = POLES / #W = WIRES / # = NEMA RATING / # = KAIC RATING
	VARIABLE FREQUENCY DRIVE (VFD)
	COMBINATION STARTER WITH CIRCUIT BREAKER DISCONNECT, FULL VOLTAGE, SIZE AS INDICATED ON DRAWINGS
	MANUAL MOTOR STARTER, ELECTRICAL CONTRACTOR SHALL COORDINATE POLES AND SIZE WITH EQUIPMENT, 120V, 20A, SINGLE POLE, UON ## = AMPERAGE RATING WHEN INDICATED ON DRAWING
	3 UP/STOP/DN PUSHBUTTON CONTROLLER
	PANELBOARD, SURFACE OR RECESSED MOUNTED AS SHOWN. SIZE, RATINGS, AND MOUNTING AS INDICATED ON PANEL SCHEDULE. CONTRACTOR IS RESPONSIBLE FOR REQUIRED CLEARANCE IN FRONT OF ELECTRICAL PANEL. SEE NEC TABLE 110.26 WORKING SPACES FOR ADDITIONAL CLEARANCE CONDITIONS.
	UTILITY REVENUE METER
	MODULAR FURNITURE SERVICE POLE PROVIDED AND INSTALLED BY MODULAR FURNITURE VENDOR.
	ELECTRICAL MOTOR
	GROUND BUS, "E" INDICATES ELECTRICAL GROUND BAR, "TG" INDICATES TELECOMMUNICATIONS GROUND BAR

SYMBOL	DESCRIPTION
	WIRELESS ACCESS POINT, DUAL GANG BOX WITH A SINGLE GANG PLASTER RING, SURGE PROTECTOR, WAP DEVICE & DATA CABLE BY OWNER. IF INSTALLED IN A NON-ACCESSIBLE CEILING AREA, PROVIDE 1-1/4" CONDUIT WITH PULL STRING TO THE DATA CLOSET OR UNTIL IT REACHES AN ACCESSIBLE CEILING OR AN AREA OPEN TO THE CEILING STRUCTURE COMMUNICATING WITH THE DATA CLOSET. ONCE IN AN ACCESSIBLE CEILING AREA, SUPPORT CABLES USING J-HOOKS TO THE DATA CLOSET. SEE 2/E0.9. WP - LISTED WEATHER-RESISTANT TYPE DEVICE
	DUAL DATA OUTLET, TWO GANG BOX WITH A SINGLE GANG PLASTER RING MOUNTED 18" AFF UON. PROVIDE 1-1/4" CONDUIT W/ PULL STRING TO THE ACCESSIBLE CEILING ABOVE OR TO THE DATA CLOSET. IF OUTLET IS INSTALLED IN A NON-ACCESSIBLE CEILING AREA, EXTEND CONDUIT TO THE DATA CLOSET OR UNTIL IT REACHES AN ACCESSIBLE CEILING OR AN AREA OPEN TO THE CEILING STRUCTURE COMMUNICATING WITH THE DATA CLOSET. ONCE IN AN ACCESSIBLE CEILING AREA, SUPPORT CABLES USING J-HOOKS TO THE DATA CLOSET. SEE 2/E0.9. DATA CABLE BY OWNER.
	WALL TELEPHONE OUTLET, TWO GANG BOX WITH A SINGLE GANG PLASTER RING MOUNTED 18" AFF UON. PROVIDE 1-1/4" CONDUIT W/ PULL STRING TO THE ACCESSIBLE CEILING ABOVE OR TO THE DATA CLOSET. IF OUTLET IS INSTALLED IN A NON-ACCESSIBLE CEILING AREA, EXTEND CONDUIT TO THE DATA CLOSET OR UNTIL IT REACHES AN ACCESSIBLE CEILING OR AN AREA OPEN TO THE CEILING STRUCTURE COMMUNICATING WITH THE DATA CLOSET. ONCE IN AN ACCESSIBLE CEILING AREA, SUPPORT CABLES USING J-HOOKS TO THE DATA CLOSET. SEE 2/E0.9. DATA CABLE BY OWNER.
	DUAL DATA OUTLET, RECESSED CEILING MOUNTED. IF INSTALLED IN A NON-ACCESSIBLE CEILING AREA, PROVIDE 1-1/4" CONDUIT WITH PULL STRING TO THE DATA CLOSET OR UNTIL IT REACHES AN ACCESSIBLE CEILING OR AN AREA OPEN TO THE CEILING STRUCTURE COMMUNICATING WITH THE DATA CLOSET. ONCE IN AN ACCESSIBLE CEILING AREA, SUPPORT CABLES USING J-HOOKS TO THE DATA CLOSET. SEE 2/E0.9. DATA CABLE BY OWNER.
	COMBINATION POWER/DATA/TELEPHONE FLOOR BOX, SIMILAR TO HUBBELL AFB10G55 WITH MOUNTING CUP HUBBELL CFB81R4CUP AND COVER CFB81R4CVRBRS. PROVIDE 1-1/4" CONDUIT WITH PULL STRING TO THE ACCESSIBLE CEILING ABOVE OR TO THE DATA CLOSET. IF OUTLET IS INSTALLED IN A NON-ACCESSIBLE CEILING AREA, EXTEND CONDUIT TO THE DATA CLOSET OR UNTIL IT REACHES AN ACCESSIBLE CEILING OR AN AREA OPEN TO THE CEILING STRUCTURE COMMUNICATING WITH THE DATA CLOSET. ONCE IN AN ACCESSIBLE CEILING AREA, SUPPORT CABLES USING J-HOOKS TO THE DATA CLOSET. SEE 2/E0.9. DATA CABLE BY OWNER. POWER BY CONTRACTOR.
	JUNCTION BOX - WALL MOUNTED +##" - INDICATES MOUNTING HEIGHT OF DEVICE IN INCHES AFF (if given)
	JUNCTION BOX - CEILING/ABOVE CEILING MOUNTED
	JUNCTION BOX - FLOOR MOUNTED
	WALL MOUNTED DOUBLE GANG BOX FOR TELEVISION MOUNTED AT 72" AFF UNLESS NOTED OTHERWISE. BOX SHALL HAVE DUPLEX RECEPTACLE AND DATA CONNECTIONS FOR TELEVISION AS DIRECTED BY OWNER. BOX SHALL BE PASS & SEYMOUR TV2MW OR APPROVED EQUIVALENT. PROVIDE 1-1/4" CONDUIT WITH PULL STRING TO THE ACCESSIBLE CEILING ABOVE OR TO THE DATA CLOSET. IF OUTLET IS INSTALLED IN A NON-ACCESSIBLE CEILING AREA, EXTEND CONDUIT TO THE DATA CLOSET OR UNTIL IT REACHES AN ACCESSIBLE CEILING OR AN AREA OPEN TO THE CEILING STRUCTURE COMMUNICATING WITH THE DATA CLOSET. ONCE IN AN ACCESSIBLE CEILING AREA, SUPPORT CABLES USING J-HOOKS TO THE DATA CLOSET, SEE 2/E0.9. DATA CABLE BY OWNER. POWER BY CONTRACTOR.

TYPICAL ABBREVIATIONS:

A, AMP	AMPERE
AFF	ABOVE FINISHED FLOOR
AFG	ABOVE FINISHED GRADE
AHU	AIR HANDLING UNIT
AIC	AMPERE INTERRUPTING CAPACITY
ATS	AUTOMATIC TRANSFER SWITCH
AWG	AMERICAN WIRE GAUGE
BOF	BOTTOM OF FIXTURE
BRKR	BREAKER
C, CND	CONDUIT
CAB	CABINET
CAT	CATALOG
CL	CHLORINE
CB	CIRCUIT BREAKER
CCTV	CLOSED CIRCUIT TELEVISION
CKT	CIRCUIT
CLG	CEILING
CP	CONTROL PANEL
CR	CONTROL RELAY, CORROSION RESISTANT
CS	CONTROL SWITCH
CV	CONTROL VALVE
CT	CURRENT TRANSFORMER
CU	COPPER
EF	EXHAUST FAN
EMER	EMERGENCY
EMT	ELECTRICAL METALLIC TUBING
ERGB	ELECTRICAL ROOM GROUND BAR
ENCL	ENCLOSURE
EQUIP	EQUIPMENT
EWC	ELECTRIC WATER COOLER
EW	ELECTRIC WATER HEATER
EPRF	EXPLOSION PROOF
FA	FIRE ALARM
FAAP	FIRE ALARM ANNUNCIATOR PANEL
FACP	FIRE ALARM CONTROL PANEL
FBO	FURNISHED BY OTHERS
FLA	FULL LOAD AMPS
FLUOR	FLUORESCENT
FLR	FLOOR
FWE	FURNISHED WITH EQUIPMENT
GEN	GENERATOR
G, GND	GROUND
GFCI	GROUND FAULT CURRENT INTERRUPTER
HH	HANDHOLE
HID	HIGH INTENSITY DISCHARGE
HOA	HAND-OFF-AUTO
HP	HORSE POWER
HPF	HIGH POWER FACTOR
HPS	HIGH PRESSURE SODIUM
HTR	HEATER
HV	HIGH VOLTAGE
HZ	HERTZ
IMC	INTERMEDIATE METALLIC CONDUIT
INCAND	INCANDESCENT
JB	JUNCTION BOX
K	THOUSAND
KCMIL	THOUSAND CIRCULAR MILLS
KVA	KILOVOLT AMPERE
KW	KILOWATT
KWH	KILOWATT-HOURS
LP	LIGHTING PANEL, LIGHT POLE
LTG	LIGHTING
MCB	MAIN CIRCUIT BREAKER
MCC	MOTOR CONTROL CENTER
MCP	MOTOR CIRCUIT PROTECTOR
MDS	MAIN DISTRIBUTION SWITCHBOARD
MDP	MAIN DISTRIBUTION PANEL
MFR	MANUFACTURER
MH	MANHOLE
MLO	MAIN LUGS ONLY
MTD	MOUNTED
MTG	MOUNTING
MTS	MANUAL TRANSFER SWITCH
MV	MEDIUM VOLTAGE
N, NEUT	NEUTRAL
NA	NOT APPLICABLE
NC	NORMALLY CLOSED
NEC	NATIONAL ELECTRIC CODE
NIC	NOT IN CONTRACT
NL	NIGHT LIGHT
NO	NORMALLY OPEN
NTS	NOT TO SCALE
P	POLE
PA	PUBLIC ADDRESS
PB	PULL BOX, PUSH-BUTTON
PF	POWER FACTOR
PH,	PHASE
PLC	PROGRAMMABLE LOGIC CONTROLLER
PNL	PANEL
PP	POWER PANEL, POWER POLE
PT	POTENTIAL TRANSFORMER
PWR	POWER
RECPT, RCP	RECEPTACLE
REQ'D	REQUIRED
RGS	RIGID GALVANIZED STEEL CONDUIT
RM	ROOM
RTU	REMOTE TELEMETRY UNIT
SCR	DC MOTOR DRIVE
SH	SHEET
SPEC	SPECIFICATION
SS	SELECTOR SWITCH
SST	STAINLESS STEEL
SW	SWITCH
SWBD	SWITCHBOARD
SWGR	SWITCH GEAR
TEL	TELEPHONE
TGB	TELECOMMUNICATIONS GROUND BAR
TMGB	TELECOMMUNICATIONS MAIN GROUND BAR
TPS	TWISTED PAIR SHIELDED
TVSS	TRANSIENT VOLTAGE SURGE SUPPRESSER
TYP	TYPICAL
UGND	UNDERGROUND
UH	UNIT HEATER
UON	UNLESS OTHERWISE NOTED
UTIL	UTILITY
V	VOLTS
VFD	VARIABLE FREQUENCY DRIVE
W	WIRE, WATT
WH	WATT-HOUR
WP	WEATHERPROOF
XFMR	TRANSFORMER

CBHF
Engineers, PLLC

2246 Yaupon Drive
Wilmington, NC 28401
Phone: 910.791.4000
www.cbhfengineers.com

© Copyright 2026 CBHF Engineers, PLLC NCH P-0506

NOT FINAL. SUBJECT TO REVISION. NOT FOR PERMITTING, FABRICATION, MATERIAL OR EQUIPMENT PURCHASE, INSTALLATION, OR CONSTRUCTION. PRICING SHALL STATE ALL ASSUMPTIONS, EXCLUSIONS, ALLOWANCES, AND CONTINGENCES AND SHALL BE RECONCILED WITH THE FINAL SIGNED AND SEALED DOCUMENTS.

PRELIMINARY
PRICING ONLY
NOT FOR
CONSTRUCTION

DAVID R. POLSTON
ARCHITECT

120 BED
NURSING FACILITY
ELECTRICAL
ABBREV. & LEGEND

DAVID R. POLSTON - Architect
3806 Park Ave. Suite C, Wilmington, NC 28403
Architecture Planning Design

PRINCIPLE HEALTH CARE
WAKE COUNTY


Holly Springs, North Carolina

EO.1

GENERAL NOTES:

1. THE CONTRACTOR SHALL REVIEW THE ARCHITECTURAL DRAWINGS AND SPECIFICATIONS FOR WORK REQUIREMENTS, THE AMOUNT OF SPACE AVAILABLE FOR ELECTRICAL EQUIPMENT, AND LAYOUT HIS WORK IN A COMPATIBLE AND COMPLEMENTARY MANNER.
 2. THE CONTRACTOR SHALL BE RESPONSIBLE FOR THOROUGHLY FAMILIARIZING HIMSELF WITH ANY CONTRACTUAL REQUIREMENTS AS MAY BE SET FORTH IN THE OTHER DIVISIONS OF THE PROJECT SPECIFICATIONS.
 3. UNLESS SPECIFICALLY NOTED OTHERWISE, SYSTEMS PROVIDED OR INSTALLED BY THE ELECTRICAL CONTRACTOR SHALL BE COMPLETE AND FULLY FUNCTIONING AFTER INSTALLATION. INCIDENTAL EQUIPMENT MAY NOT BE SHOWN, AND ALL WORK WHICH MAY BE REASONABLY IMPLIED AS BEING INCIDENTAL TO THIS WORK, BUT REQUIRED FOR THE PROPER OPERATION OF THE EQUIPMENT OR SYSTEM, SHALL BE PROVIDED AT NO ADDITIONAL COST TO THE OWNER. ADDITIONAL CIRCUITS SHALL BE INSTALLED WHEREVER NEEDED TO CONFORM TO THE SPECIFIC REQUIREMENTS OF EQUIPMENT.
 4. BIDDERS SHALL HAVE A WORKING KNOWLEDGE OF LOCAL CODES AND ORDINANCES AND SHALL INCLUDE IN THEIR BIDS THE COSTS FOR ALL WORK INSTALLED IN STRICT ACCORDANCE WITH GOVERNING CODES, THE CONSTRUCTION DOCUMENTS NOTWITHSTANDING.
 5. TEMPORARY POWER CONNECTIONS AS REQUIRED SHALL BE PROVIDED BY THE CONTRACTOR AT NO ADDITIONAL EXPENSE TO THE OWNER. ALL TEMPORARY EQUIPMENT WIRING SHALL BE IN ACCORDANCE WITH THE NATIONAL ELECTRICAL CODE. THE CONTRACTOR SHALL PROVIDE DETAILS, MATERIALS, ETC. TO THE ARCHITECT/ENGINEER PRIOR TO MAKING TEMPORARY CONNECTIONS. FURNISH AND INSTALL ALL EQUIPMENT AND MATERIALS INCLUDING CONTROL EQUIPMENT, MOTOR STARTERS, BRANCH AND FEEDER CIRCUIT BREAKERS, PANELBOARDS, TRANSFORMERS, ETC. FOR TEMPORARY POWER. COORDINATE WITH THE ELECTRICAL UTILITY COMPANY AS REQUIRED.
 6. THE WORK SHALL INCLUDE COMPLETE TESTING OF ALL EQUIPMENT AND WIRING AT THE COMPLETION OF WORK AND ANY MINOR CORRECTIONS, CHANGES OR ADJUSTMENTS NECESSARY FOR THE PROPER FUNCTIONING OF THE SYSTEM AND EQUIPMENT.
 7. ALL EQUIPMENT SHOWN DOTTED OR DASHED IS BY OTHERS.
 8. DO NOT SCALE ELECTRICAL DRAWINGS. REFER TO THE ARCHITECTURAL DRAWINGS FOR DIMENSIONS.
 9. CIRCUIT ARRANGEMENTS AND CONFIGURATIONS ARE NOT INTENDED TO SHOW THE NUMBER OF FITTINGS, OR OTHER INSTALLATION DETAILS. UNLESS NOTED OTHERWISE, THE EXACT ROUTING OF FEEDER AND BRANCH CIRCUIT RACEWAYS AND CABLES IS THE RESPONSIBILITY OF THE CONTRACTOR. FEEDER AND BRANCH CIRCUIT ARRANGEMENTS ARE SHOWN SCHEMATICALLY/DIAGRAMMATICALLY ONLY. THE CONTRACTOR SHALL ROUTE CONDUITS AS REQUIRED BY THE CONDITIONS OF THE INSTALLATION.
 10. UNLESS DIMENSIONED, DEVICE LOCATIONS SHOWN ON THE DRAWINGS ARE APPROXIMATE. ADJUST EXACT LOCATIONS AS REQUIRED TO SERVE THE INTENDED PURPOSE AND TO AVOID CONFLICTS AND INTERFERENCES WITH OTHER TRADES. EXACT DEVICE LOCATIONS SHALL BE AS INDICATED ON THE ARCHITECTURAL DRAWINGS OR AS DIMENSIONED. IF NOT SHOWN ON THE ARCHITECTURAL DRAWINGS OR DIMENSIONED ON THE ELECTRICAL DRAWINGS, VERIFY EXACT LOCATION WITH THE ARCHITECT/ENGINEER PRIOR TO ROUGH-IN.
 11. CONDUIT TERMINATING IN PRESSED STEEL BOXES SHALL HAVE DOUBLE LOCKNUTS AND INSULATED BUSHINGS. CONDUITS TERMINATING IN GASKETED ENCLOSURES SHALL BE TERMINATED WITH GROUNDING TYPE CONDUIT HUBS.
 12. DEVICE BOXES SHOWN BACK-TO-BACK SHALL BE OFFSET A MINIMUM OF TWELVE (12) INCHES TO REDUCE SOUND TRANSMISSION BETWEEN ROOMS.
 13. THE DRAWINGS INDICATE THE NUMBER OF BRANCH CIRCUIT HOMERUN PHASE CONDUCTORS VIA ARROWHEADS. PROVIDE NEUTRAL AND EQUIPMENT GROUND CONDUCTORS AS REQUIRED. ADDITIONAL CONDUCTORS REQUIRED FOR CONTROL SHALL BE INCLUDED EVEN IF NOT EXPLICITLY SHOWN.
 14. SEAL ALL CONDUIT OPENINGS THROUGH EXTERIOR BUILDING WALLS WATERTIGHT.
 15. ALL EXTERIOR WIRING DEVICES, BOXES, ETC. SHALL BE WEATHERPROOF. LIGHTING FIXTURES SHALL BE APPROPRIATELY RATED AND LISTED FOR THE ENVIRONMENT.
 16. MAINTAIN CEILING FRIESES WITH ALL NECESSARY LIGHTING FIXTURE TRIM, ACCESSORIES, OPTIONS AND/OR FIELD FABRICATED SHROUDS COMPLYING WITH ALL APPLICABLE CODES.
 17. RACEWAYS AND CABLES PENETRATING FLOORS, CEILINGS OR WALLS SHALL BE PROPERLY SEALED SMOKE/TIGHT.
 18. RACEWAYS AND CABLES PENETRATING RATED FLOOR, CEILING OR WALL ASSEMBLIES SHALL BE PROPERLY SEALED IN ACCORDANCE WITH THE CORRESPONDING UNDERWRITERS LABORATORIES (OR OTHER APPROVED THIRD PARTY TESTING AGENCY) APPROVED AND LISTED FIRESTOPPING MATERIALS AND MANUFACTURER APPROVED INSTALLATION TECHNIQUES COMPLYING WITH ALL APPLICABLE CODES. SEE ARCHITECTURAL DRAWINGS FOR IDENTIFICATION OF RATED WALLS AND CEILINGS.
 19. LIGHTING FIXTURES MOUNTED IN FIRE-RATED CEILINGS SHALL BE PROVIDED WITH ACCESSORIES NECESSARY TO MAINTAIN THE CEILING FIRE RATING.
 20. ALL RACEWAYS AND CABLES SHALL BE CONCEALED EXCEPT THOSE SHOWN ON DRAWINGS TO BE EXPOSED. IF APPLICABLE, MATCH EXISTING RACEWAY INSTALLATION METHODS AND ROUTINGS AT OR NEAR EXISTING FACILITIES.
 21. INSTALL EXPOSED RACEWAYS PARALLEL TO OR AT RIGHT ANGLES TO NEARBY SURFACES OR STRUCTURAL MEMBERS, AND FOLLOW THE SURFACE CONTOURS AS MUCH AS POSSIBLE. NO DIAGONAL RUNS WILL BE ALLOWED. ALL CONDUITS SHALL BE RUN STRAIGHT AND TRUE. RUN PARALLEL OR BANKED RACEWAYS TOGETHER ON COMMON SUPPORTS WHERE PRACTICAL. MAKE BENDS IN PARALLEL OR BANKED RUNS FROM SAME CENTERLINE TO MAKE BENDS PARALLEL.
 22. PROVIDE AND PLACE ALL SLEEVES FOR CONDUITS PENETRATING WALLS, FLOORS, PARTITIONS, ETC. LOCATE ALL NECESSARY SLOTS FOR ELECTRICAL WORK AND FORM BEFORE CONCRETE IS POURED.
 23. PATCHING OF WATERPROOFED SURFACES SHALL RENDER THE AREA OF THE PATCHING COMPLETELY WATERPROOF.
 24. ALL MOTORS AND OTHER VIBRATING EQUIPMENT SHALL BE CONNECTED TO THE CONDUIT SYSTEM BY MEANS OF A SHORT SECTION (18 INCH MINIMUM) OF FLEXIBLE CONDUIT UNLESS OTHERWISE INDICATED. AN EQUIPMENT GROUNDING CONDUCTOR SHALL BE INSTALLED INSIDE THE FLEXIBLE CONDUIT AND TERMINATE AT THE LOAD END WITH AN APPROVED GROUNDING CLAMP OR LUG.
 25. SURFACE MOUNTED PANELBOARDS, JUNCTION, OUTLET AND PULL BOXES, RACEWAYS, ETC., INSTALLED ON EXTERIOR SURFACES OR INSIDE ON EXTERIOR WALLS SHALL BE SUPPORTED BY SPACERS TO PROVIDE A 1/4" MINIMUM CLEARANCE BETWEEN THE WALL AND EQUIPMENT.
 26. CEILING MOUNTED DEVICES INSTALLED IN ACOUSTICAL TILE CEILING AREAS SHALL BE SUPPORTED FROM THE STRUCTURE ABOVE WITH RODS OF SUFFICIENT SIZE TO PREVENT VERTICAL MOVEMENT OF THE OUTLET BOX. BULBS ALONE ARE NOT ADEQUATE UNLESS SPECIFICALLY APPROVED. CEILING MOUNTED EXIT LIGHT FIXTURES SHALL BE INSTALLED LEVEL. DO NOT SUPPORT DEVICES FROM ACOUSTICAL CEILING TILE.
 27. EXCAVATION AND TRENCHING REQUIRED FOR THE INSTALLATION OF ELECTRICAL POWER AND TELECOMMUNICATIONS RACEWAYS SHALL BE PROVIDED BY THE CONTRACTOR IN ACCORDANCE WITH THE REQUIREMENTS OF DIVISION 26 OF THE PROJECT SPECIFICATIONS.
 28. PRIOR TO TRENCHING IN ANY AREA, THE CONTRACTOR SHALL CONTACT ELECTRICAL, COMMUNICATIONS/DATA/FIBER, CABLE TELEVISION, GAS AND WATER UTILITY PROVIDERS AND HAVE ALL UTILITIES IN THE AREA IDENTIFIED. DAMAGE TO ANY UNDERGROUND UTILITIES OR STRUCTURES SHALL BE REPAIRED BY THE CONTRACTOR AT NO ADDITIONAL COST TO THE PROJECT.
 29. ALL UNDERGROUND RACEWAYS SHALL BE IDENTIFIED BY UNDERGROUND LINE MARKING TAPE LOCATED DIRECTLY ABOVE THE RACEWAY AT 6 TO 8 INCHES BELOW FINISHED GRADE. SEE SPECIFICATIONS SECTION 260553.
 30. FINAL TYPE PANELBOARD DIRECTORIES INSTALLED IN THE PANELBOARD DOOR POCKET SHALL INCLUDE FINAL ACTUAL ROOM NAMES AND NUMBERS IN ADDITION TO THE GENERAL DESCRIPTION SHOWN ON THE PANEL SCHEDULES ON THE DRAWINGS.
 31. CONDUCTOR SIZING IS BASED ON 75 DEGREE C, COPPER NEC RATINGS, UNLESS NOTED OTHERWISE. THE CONTRACTOR SHALL VERIFY, PRIOR TO INSTALLATION OF CONDUCTORS OR CONDUIT FEEDING ANY EQUIPMENT, THE ELECTRICAL EQUIPMENT IS RATED FOR USE WITH 75 DEGREE C WIRING. IF ANY EQUIPMENT IS RATED FOR USE WITH LESS THAN 75 DEGREE C CONDUCTORS, THE CONTRACTOR SHALL NOTIFY THE ARCHITECT/ENGINEER IMMEDIATELY FOR EVALUATION/CORRECTION.
 32. DO NOT PULL CONDUCTORS UNTIL THE CONDUIT SYSTEM IS COMPLETE IN EVERY DETAIL. IN THE CASE OF CONCEALED WORK, "COMPLETE" MEANS UNTIL ALL ROUGH PLASTERING OR MASONRY HAS BEEN COMPLETED.
 33. WHERE SIZE IS NOT SHOWN ON THE DRAWINGS, BRANCH CIRCUITS SHALL CONSIST OF #12 OR #10 AWG MINIMUM PHASE, NEUTRAL AND EQUIPMENT GROUND CONDUCTORS IN 1/2" MINIMUM RACEWAY. REFER TO THE MINIMUM CONDUCTOR SIZE CHART ON THE DRAWINGS AND INCREASE CONDUCTORS SIZES AS REQUIRED TO MAINTAIN A MAXIMUM OF 3% VOLTAGE DROP.
 34. COMMON NEUTRAL BRANCH CIRCUITS ARE NOT PERMITTED. PROVIDE SEPARATE, INDIVIDUAL NEUTRAL CONDUCTORS FOR ALL RECEPTACLE AND LIGHTING BRANCH CIRCUITS.
 35. KEEP CONDUCTOR SPLICES TO A MINIMUM. INSTALL SPLICES AND TAPES THAT POSSESS EQUIVALENT OR BETTER MECHANICAL STRENGTH AND INSULATION RATINGS THAN CONDUCTORS BEING SPLICED. USE SPLICE AND TAP CONNECTORS COMPATIBLE WITH CONDUCTOR MATERIAL. INSTALL CONDUCTORS AT EACH OUTLET WITH AT LEAST 6 INCHES OF SLACK. CONNECT OUTLETS AND COMPONENTS TO WIRING AND TO GROUND AS INDICATED AND INSTRUCTED BY THE MANUFACTURER.
 36. DO NOT SPLICE BRANCH CIRCUIT HOMERUNS WITHOUT THE PERMISSION OF THE ARCHITECT/ENGINEER. HOMERUNS SHALL BE CONTINUOUS FROM THE LAST OUTLET BOX TO THE SERVING PANELBOARD.
 37. DO NOT COMBINE BRANCH CIRCUIT HOMERUNS UNLESS SPECIFICALLY INDICATED ON THE DRAWINGS.
 38. DO NOT CHANGE CIRCUITING SHOWN WITHOUT PERMISSION OF THE ARCHITECT/ENGINEER.
 39. THROUGH TAPS SHALL BE AT SWITCH/CIRCUIT BREAKER AMPACITY, UNLESS NOTED OTHERWISE.
 40. INSTALL WIRING DEVICES AT HEIGHTS AS SHOWN ON THE DRAWINGS. ALSO COORDINATE MOUNTING HEIGHTS WITH THE ARCHITECTURAL DRAWINGS AND CASEWORK DETAILS. IF CONFLICTING, ARCHITECTURAL DRAWINGS AND DETAILS SHALL GOVERN.
 41. PROVIDE GROUND FAULT CIRCUIT-INTERRUPTER (GFCI) PROTECTION FOR PERSONNEL IN ACCORDANCE WITH THE NEC INCLUDING ALL ELECTRIC WATER COOLERS, EXTERIOR RECEPTACLES AND RECEPTACLES IN AREAS SUBJECT TO POSSIBLE WET CONDITIONS. ALL RECEPTACLES INSTALLED WITHIN 6 FEET OF A SINK SHALL BE GFI PROTECTED. ALL RECEPTACLES IN NON-RESIDENTIAL KITCHENS SHALL BE GFI PROTECTED.
 42. GFCI RECEPTACLES SHALL BE READILY ACCESSIBLE AFTER INSTALLATION. IF CONDITIONS OF THE INSTALLATION DO NOT ALLOW FOR READY ACCESS, PROVIDE A STANDARD RECEPTACLE AND PROVIDE A GFCI CIRCUIT BREAKER TO FEED THE CIRCUIT. IN LIEU OF GFCI CIRCUIT BREAKERS, BLANK FACE GFCI DEVICES ARE ACCEPTABLE IF INSTALLED IN AN ACCESSIBLE LOCATION.
 43. IN AREAS IN WHICH DUAL LEVEL SWITCHING IS INDICATED (TYPICALLY BY 2 OR MORE ADJACENT, GANGED SWITCHES), PROVIDE THE APPROPRIATE NUMBER OF CONDUCTORS TO FACILITATE THIS FUNCTION (AS TYPICALLY SHOWN).
 44. CONNECT BATTERY PACK TYPE EMERGENCY AND EXIT LIGHTING FIXTURES AND EMERGENCY BATTERY (BODINE TYPE) DRIVERS TO THE UNSWITCHED LIGHTING CIRCUIT SERVING THE SPACE LIGHTED BY THE EMERGENCY AND EXIT FIXTURES. THESE CONNECTIONS ARE INTENTIONALLY NOT SHOWN TO MAINTAIN DRAWING CLARITY.
 45. COORDINATE LIGHTING FIXTURE LOCATIONS WITH THE ARCHITECTURAL REFLECTED CEILING PLAN. IF CONFLICTS ARE NOTED, REQUEST CLARIFICATION FROM THE ARCHITECT/ENGINEER BEFORE PROCEEDING.
 46. ADJACENT SWITCHES SHALL BE GANGED.
 47. ADJACENT RECEPTACLES AND DATA/TELEPHONE OUTLETS SHALL BE INSTALLED 6 INCHES CENTER TO CENTER AND SHALL BE AT THE SAME ELEVATION.
 48. SEPARATE NEUTRALS ARE REQUIRED FOR ALL LINE VOLTAGE DIMMED LIGHTING CIRCUITS.
 49. WHERE THE DRAWINGS INDICATE A LIGHTING FIXTURE IS TO BE PROVIDED WITH SPECIAL FEATURES/SWITCHING (DIMMING, EMERGENCY, BATTERY, MULTILEVEL, ETC), THE CONTRACTOR SHALL PROVIDE THESE FIXTURES WITH THE APPROPRIATE OPTIONS TO ACCOMMODATE THE SPECIAL FEATURES. THE CONTRACTOR SHALL PROVIDE THE FIXTURES AS INDICATED IN THE LIGHTING FIXTURE SCHEDULE WITH MODIFICATIONS AS REQUIRED BY DRAWING NOTES.
 50. COORDINATE LOCATIONS OF PLUMBING, MECHANICAL, DATA, TELEPHONE, NURSE CALL, PAGING, ACCESS CONTROL, AUDIOVISUAL EQUIPMENT, ETC. AND OF OWNER PROVIDED EQUIPMENT WITH THE RESPECTIVE CONTRACTORS AND VENDORS AND THE OWNER BEFORE ROUGH-IN. ADJUST LIGHTING FIXTURES, RECEPTACLES AND ELECTRICAL EQUIPMENT TO ACCOMMODATE THIS EQUIPMENT. ADVISE THE ARCHITECT/ENGINEER OF CONFLICTS BEFORE ROUGH-IN. SEE SPECIFICATIONS SECTION 16XXX FOR ADDITIONAL DETAIL INVOLVING WORK WITH OTHER TRADES.
 51. LIGHTING FIXTURES ARE, IN SOME INSTANCES, SHOWN TO BE INSTALLED ON THE BOTTOM OF THE EXPOSED STRUCTURE. THE CONTRACTOR SHALL NOT INSTALL FIXTURES ABOVE DUCTWORK WHICH BLOCKS LIGHTING FROM REACHING THE FLOOR. FIELD ADJUST FIXTURE LOCATIONS TO AVOID DUCTWORK AND OTHER EQUIPMENT WHICH INTERFERES WITH INTENDED LIGHTING OF THE SPACE. INSTALL FIXTURES ON WALLS IN SPACES WHERE FIXTURE OUTPUT WOULD OTHERWISE BE BLOCKED. COORDINATE RELOCATIONS WITH THE ARCHITECT/ENGINEER.
 52. THE LOCATIONS OF ELECTRICAL EQUIPMENT SERVING MECHANICAL, PLUMBING, FOOD SERVICE EQUIPMENT, ETC. MAY NOT BE SHOWN PRECISELY ON THE ELECTRICAL DRAWINGS DUE TO THE VARIABILITY OF SPACE AND EQUIPMENT ROOM ARRANGEMENTS AND THE EQUIPMENT PROVIDED. LOCATIONS OF ELECTRICAL EQUIPMENT, PANELBOARDS, WIRING TROUGHS, LOCAL DISCONNECTING MEANS, ETC. SHALL BE COORDINATED WITH THE RESPECTIVE CONTRACTORS PRIOR TO ROUGH-IN. ADVISE AND/OR ADJUST EQUIPMENT LOCATIONS SHOWN IN CONSULTATION WITH OTHER TRADES TO MAINTAIN VISIBILITY OF THE EQUIPMENT FROM DISCONNECTING MEANS AND PROVIDE ACCESS AND WORKING SPACE IN COMPLIANCE WITH CODES.
 53. BEFORE COMMENCING WORK OR ORDERING MATERIALS, THE CONTRACTOR SHALL COORDINATE WITH OTHER TRADES AND VERIFY THE NAMEPLATE RATINGS OF ALL EQUIPMENT (MOTORS, HEATERS, COMPRESSORS, ETC.) AND ADJUST THE RATINGS OF THE ELECTRICAL EQUIPMENT (SWITCHES, FUSES, CIRCUIT BREAKERS, CONDUCTORS, RACEWAYS, ETC.) AS APPROPRIATE TO SERVE THIS EQUIPMENT.
 54. ENERGIZE EQUIPMENT ONLY AFTER OBTAINING PERMISSION FROM THE ENTITY PROVIDING THE EQUIPMENT.
 55. THE ELECTRICAL CONTRACTOR SHALL COORDINATE ALL EQUIPMENT TERMINATIONS, PLUGS AND CORDSETS WITH VENDOR EQUIPMENT AND VERIFY ALL DEVICE LOCATIONS FOR SPECIALTY EQUIPMENT WITH CASEWORK PRIOR TO ROUGH-IN.
 56. THE ARRANGEMENT OF ELECTRICAL DISTRIBUTION EQUIPMENT IN ELECTRICAL

68. TELECOMMUNICATIONS AND DATA CABLES WILL BE PROVIDED AND INSTALLED BY THE OWNER. LEAVE PULL WIRES OR ROPES OF ADEQUATE TENSILE STRENGTH IN ALL EMPTY CONDUITS.
59. PROVIDE TELEPHONE, CABLE TELEVISION, FIBER AND DATA SERVICE ENTRANCE CONDUIT IN SIZES AND LOCATIONS AS SHOWN ON THE DRAWINGS AND AS REQUIRED BY THE OWNER AND THE SERVICE UTILITIES. UTILITY SERVICE ENTRANCE CABLES WILL BE PROVIDED AND INSTALLED BY THE OWNER'S SERVICE UTILITIES. LEAVE PULL WIRES OR ROPES OF ADEQUATE TENSILE STRENGTH IN ALL EMPTY CONDUITS.
60. EXACT SPACING OF SMOKE AND HEAT DETECTORS AND A/V DEVICES SHALL BE FOLLOWED AS CLOSELY AS POSSIBLE WITH POSITIONS SHOWN ON THE DRAWINGS. DETECTOR SPACING IS BASED UPON NFPA 72 INSTALLATION CRITERIA. A SLIGHT ADJUSTMENTS MAY BE MADE IN SPACING IF REQUIRED BY FIELD CONDITIONS, BUT SPACING SHALL NOT EXCEED AIA NFPA AND EQUIPMENT MANUFACTURERS SPACING CRITERIA. DO NOT INSTALL SMOKE DETECTORS WITHIN 3 FEET OF SUPPLY AIR DIFFUSERS OR RETURN GRILLES. PROVIDE FLEX CONDUIT CONNECTION TO SMOKE AND HEAT DETECTORS OF ADEQUATE LENGTH TO ALLOW HORIZONTAL ADJUSTMENT OF FOUR FEET FROM POSITION INDICATED ON DRAWINGS.
61. SAFETY: COMPLY WITH OSHA AND NEC ARC FLASH PROTECTION REQUIREMENTS.
62. FOOD SERVICE EQUIPMENT ELECTRICAL NOTES
- A. SEE SPECIFICATIONS SECTION 16049 FOR ADDITIONAL REQUIREMENTS.
- B. THE ELECTRICAL CONTRACTOR SHALL MAKE FINAL ELECTRICAL CONNECTIONS TO ALL FOOD SERVICE AND RELATED KITCHEN EQUIPMENT.
- C. THE CIRCLE OR ELONGATED BUBBLE SYMBOL WITH NUMBER IDENTIFIES FOOD SERVICE EQUIPMENT AS IT IS SHOWN ON THE FOOD SERVICE EQUIPMENT DRAWINGS. SEE FOOD SERVICE EQUIPMENT DRAWINGS FOR ADDITIONAL INFORMATION.
- D. SEE FOOD SERVICE EQUIPMENT DRAWINGS FOR EXACT EQUIPMENT LOCATIONS, DIMENSIONS, CONNECTION TYPE, POWER AND CIRCUIT REQUIREMENTS, CIRCUIT BREAKER SIZE, WIRING DEVICE TYPE, RATING AND CONFIGURATION AND ROUGH-IN LOCATIONS AND PROVIDE SUITABLE ELECTRICAL EQUIPMENT, DEVICES, CONNECTIONS, CIRCUITS AS REQUIRED BY THE FOOD SERVICE EQUIPMENT DRAWINGS.
- E. THE ELECTRICAL CONTRACTOR SHALL VERIFY ROUGH-IN REQUIREMENTS, LOCATIONS, MOUNTING HEIGHTS, ORIENTATION, VOLTAGE, PHASE, AMPS, HP, KW, ETC. FOR ALL FOOD SERVICE EQUIPMENT PRIOR TO ROUGH-IN.
- F. PROVIDE LOCAL DISCONNECTING MEANS FOR EQUIPMENT AS REQUIRED BY CODES AND THE AHJ.
- G. THE ELECTRICAL CONTRACTOR SHALL FURNISH AND INSTALL DISCONNECT SWITCHES. INTERLOCKS, CABLE TIE WIRING AND INSTALLATION AS SPECIFICALLY OUTLINED ON THE FOOD SERVICE EQUIPMENT DRAWINGS.
- H. FINAL CONNECTION TO HARD WIRED FOOD SERVICE EQUIPMENT SHALL BE MADE WITH LIQUIDTIGHT FLEXIBLE CONDUIT.
- I. COORDINATE ALL CONNECTIONS TO EQUIPMENT WITH THE FOOD SERVICE EQUIPMENT CONTRACTOR.
- J. ENERGIZE EQUIPMENT ONLY AFTER OBTAINING PERMISSION FROM THE CONTRACTOR PROVIDING THE EQUIPMENT.
- K. ALL CONVENIENCE OUTLETS IN THE KITCHEN SHALL BE INSTALLED HORIZONTALLY AND RATED 20 AMPS UNLESS NOTED OTHERWISE OR REQUIRED BY EQUIPMENT. ALL 125 VOLT RECEPTACLES MOUNTED IN THE KITCHEN SHALL BE GFCI TYPE. RECEPTACLES SHALL BE OF STANDARD NEMA CONFIGURATIONS.
- L. ALL FLOORS SHALL BE CONCEALED IN WALLS WHERE POSSIBLE, OTHERWISE, STUB UP THROUGH FLOORS. EQUIPMENT APPROX. 6" ABOVE FLOOR TO CLEAR EQUIPMENT BASE.
- M. HOODS WILL BE FURNISHED BY THE OWNER. THE FOOD SERVICE EQUIPMENT CONTRACTOR WITH LIGHT FIXTURES AND SWITCHES/CONTROLS FOR LIGHTS AND FANS. THE ELECTRICAL CONTRACTOR SHALL MAKE FINAL CONNECTIONS TO THE ELECTRICAL TERMINAL BOX PROVIDED WITH THE HOOD AND MAKE CONNECTIONS FROM THE TERMINAL BOX TO THE EXHAUST AND MAKE UP AIR FANS AS SHOWN.
- N. FURNISH SHUNT TRIP CIRCUIT BREAKERS FOR ELECTRICAL FOOD SERVICE EQUIPMENT INSTALLED UNDER HOODS. CONTRACTOR TO DE-ENERGIZE THESE UNITS UPON ACTIVATION OF THE EXHAUST HOOD FIRE SUPPRESSION SYSTEM. COORDINATE CONNECTIONS WITH THE FOOD SERVICE EQUIPMENT CONTRACTOR.
- O. THE DISH MACHINE WILL BE FURNISHED BY THE FOOD SERVICE EQUIPMENT CONTRACTOR. PREWIRED TO AN INTEGRAL CONTROL PANEL READY FOR FINAL CONNECTION BY THE ELECTRICAL CONTRACTOR.
- P. PROVIDE SEAL-OFF FITTINGS FOR ALL CONDUITS ENTERING OR LEAVING REFRIGERATED WALK-IN BOXES.
63. LOW VOLTAGE SYSTEMS ELECTRICAL COORDINATION NOTES
- A. THE ELECTRICAL CONTRACTOR SHALL COORDINATE ELECTRICAL WORK REQUIRED BY THE LOW VOLTAGE SYSTEMS DRAWINGS THE LOW VOLTAGE SYSTEMS VENDORS, THE OWNER AND THE GENERAL CONTRACTOR.
- B. THE LOW VOLTAGE SYSTEMS DRAWINGS, OBTAINED BY THE CONTRACTOR FROM THE OWNER'S LOW VOLTAGE SYSTEMS VENDORS, SHALL BE CONSIDERED AN ESSENTIAL COMPONENT OF THE CONTRACTOR DOCUMENTS. SOME ELECTRICAL WORK SHOWN ON THESE DRAWINGS IS INTENTIONALLY NOT DUPLICATED ON THE ELECTRICAL DRAWINGS. THE CONTRACTOR SHALL PROVIDE, AS PART OF THIS CONTRACT, SOURCES OF POWER: POWER, RECEPTABLES, CONTROL AND COMMUNICATIONS CONDUCTORS, CABLES AND RACEWAYS; EMPTY RACEWAYS; JUNCTION, OUTLET AND PULL BOXES; MOUNTING HARDWARE; FINAL CONNECTIONS; CONNECTION HARDWARE; TESTING AND TESTING SUPPORT, ETC. FOR THE LOW VOLTAGE SYSTEMS AS SHOWN ON THE CONTRACT DRAWINGS AND THE LOW VOLTAGE SYSTEMS DRAWINGS. IF NOT SHOWN ON THE ELECTRICAL DRAWINGS, USE SPARE CIRCUIT BREAKERS IN ELECTRICAL PANELBOARDS FOR ADDITIONAL CIRCUITS SHOWN ON THE REFERENCE DRAWINGS AND MARK AS-BUILT DRAWINGS ACCORDINGLY.
- C. SEE SPECIFICATIONS SECTIONS 16041 - PAGING SYSTEM, 16042 - NURSE CALL SYSTEM, 16043 - TELEPHONE AND DATA RACEWAY SYSTEM, 16044 - ACCESS CONTROL SPECIAL LOCKING (MAG-LOCK) RACEWAYS SYSTEM, 16045 - CABLE TELEVISION RACEWAY SYSTEM, 16046 - SECURITY CAMERA RACEWAY SYSTEM, 16047 - AIPHONE SYSTEM RACEWAY SYSTEM AND 16049 - ELECTRICAL WORK IN CONNECTION WITH OTHER CONTRACTS FOR ADDITIONAL REQUIREMENTS AND CONTRACTOR RESPONSIBILITIES WITH REGARD TO THESE SYSTEMS.
- D. THE CONTRACTOR IS CAUTIONED TO THOROUGHLY REVIEW BOTH THE CONTRACT DRAWINGS AND THE LOW VOLTAGE SYSTEMS REFERENCE DRAWINGS PRIOR TO SUBMITTING A BID. ELECTRICAL WORK SHOWN ON EITHER DRAWING OR THESE DRAWINGS TO BE PROVIDED BY THE ELECTRICIAN OR SIMILAR TERM SHALL BE PROVIDED BY THE CONTRACTOR AND SHALL BE CONSIDERED AS BINDING AS MATERIAL, EQUIPMENT AND LABOR SHOWN ON THE CONTRACT DRAWINGS. NO EXTRAS WILL BE CONSIDERED OR APPROVED FOR ITEMS SHOWN ON EITHER DRAWINGS TO BE PROVIDED BY THE ELECTRICAL CONTRACTOR.
64. ATTIC LOW VOLTAGE SYSTEMS CABLE INSTALLATION NOTES
- A. ALL LOW VOLTAGE SYSTEM CABLE INSTALLED FREE RUN IN THE ATTIC SHALL BE INSTALLED ON J HOOKS. CABLES SHALL BE INSTALLED IN A MANNER TO PROTECT THE CABLES FROM DAMAGE DURING INSTALLATION, FACILITATE CABLE MANAGEMENT AND IDENTIFICATION, AND PROVIDE A NEAT GROOMED APPEARANCE.
- B. EACH CABLE SYSTEM SHALL BE INSTALLED AND SUPPORTED INDEPENDENTLY.
- C. CABLING SHALL BE INSTALLED IN STRAIGHT PATHS IN A NEAT AND ORDERLY FASHION FOLLOWING MAINTENANCE ACCESS ROUTE. CABLES SHALL BE PROTECTED BY DIAGONAL BELTLINE AND OR NON-SUPPORTED CABLING ARE UNACCEPTABLE. CABLING SHALL BE ROUTED AS HIGH AS POSSIBLE AND ABOVE OTHER BUILDING FACILITIES IN THE PATH WITH THE LEAST OBSTRUCTIONS IN THE SPACE. PATHWAYS SHALL BE AT LEAST 2 FEET AWAY FROM ALL LIGHTING FIXTURES AND OTHER POTENTIAL EMF SOURCES. CABLES SHALL NOT BE STRAPPED TO ELECTRICAL POWER CONDUITS, PIPING OR OTHER SYSTEMS. HORIZONTAL CABLES SHALL BE BUNDLED USING HOOK AND LOOP STRAPS. PLASTIC CABLE TIES ARE NOT PERMITTED.
- D. THE CABLE SUPPORT STRUCTURE SHALL UTILIZE APPROVED J HOOK CABLE SUPPORTS AND BE SIZED TO ACCOMMODATE CHANGE. J HOOK TYPE CABLE SUPPORTS SHALL BE SECURELY FASTENED TO THE BUILDING STRUCTURE AND BE SPACED AT A MAXIMUM DISTANCE OF FOUR (4) FEET SO THAT SAG BETWEEN SUPPORTS DOES NOT EXCEED 12 INCHES. ALL J HOOKS SHALL BE SIZED WITH 20% SPARE CAPACITY. ALL ATTACHMENT HARDWARE SHALL BE APPROVED FOR THE TYPE OF INSTALLATION AND MAXIMUM LOAD RATING OF THE PRODUCTS INSTALLED.
- E. ALL PENETRATIONS THROUGH WALLS AND CEILINGS SHALL BE SLEEVED. ALL CABLES SHALL HAVE PERMANENTLY ATTACHED PLASTIC BUSHINGS. SLEEVES SHALL BE SIZED TO ACCEPT 50% GROWTH. ALL SLEEVES SHALL BE FIRE-STOPPED USING THIRD PARTY TESTING AGENCY APPROVED METHODS AND SHALL MAINTAIN ASSEMBLY FIRE RATINGS.

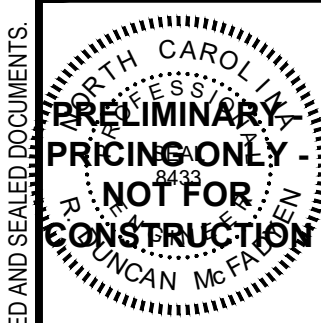

PRINCIPLE HEALTH CARE
WAKE COUNTY
Holly Springs, North Carolina


David R. Polston - Architect
3806 Park Ave. Suite C, Wilmington, NC 28403
Architecture Planning Design

120 BED
NURSING FACILITY
ELECTRICAL
GENERAL NOTES

E0.2

NOT FINAL; SUBJECT TO REVISION. NOT FOR PERMITTING, FABRICATION, MATERIAL OR EQUIPMENT PURCHASE, INSTALLATION, OR CONSTRUCTION. PRICING SHALL STATE AT ASSUMPTIONS, EXCLUSIONS, ALLOWANCES, AND CONTINGENCIES AND SHALL BE RECONCILED WITH THE FINAL SIGNED AND SEALED DOCUMENTS.


SITE LIGHTING FIXTURE SCHEDULE										
SYMBOL	DESCRIPTION	LIGHT ENGINE					MFG.	MODEL	MOUTNING	REMARKS
		WATTS	TYPE	COLOR TEMP	LUMENS	VOLTS				
SP3B	SINGLE LANTERN POLE LIGHT, TYPE 3 DISTRIBUTION & SIDE SHIELDS	129	LED	4000K	12402	120	SUN VALLEY LIGHTING	COL21/VLED-III/120LED 350MA NW/PT/RAL-9005-T/HS	POST TOP	SEE NOTE 1
SP4A	SINGLE LANTERN POLE LIGHT, TYPE 4 DISTRIBUTION	129	LED	4000K	11539	120	SUN VALLEY LIGHTING	COL21/VLED-III/120LED 350MA NW/PT/RAL-9005-T/HS	POST TOP	SEE NOTE 1
SP4B	DOUBLE LANTERN POLE LIGHT, TYPE 4 DISTRIBUTION	258	LED	4000K	-	120	SUN VALLEY LIGHTING	COL21/VLED-III/120LED 350MA NWW-180/RAL-9005-T	POST TOP	SEE NOTE 1
SB	BOLLARD LIGHT	7	LED	3000K	425	120	LANDSCAPE FORMS INC.	AP401-T40035F-30K-UV1-SM-NMG	CONC. BASE SEE 2/E0.3	
NOTES:										
1. HEIGHT OF OPTICS TO BE +18'0" ABOVE SURROUNDING GRADE. PROVIDE 'SUN VALLEY LIGHTING' 4200SB SPLITBASE, ROUND POLE WITH BASE PLATE AND XBW-2-180 ARM MOUNT (DOUBLE LANTERN ONLY.) COORDINATE FINAL SELECTION OF SPLIT BASE, POLE, AND ARM WITH OWNER AND 'SUN VALLEY LIGHTING' REPRESENTATIVE. SELECTION OF POLE GAUGE AND DIAMETER WILL BE SUBJECTION TO WIND LOAD RATING OF SITE LOCATION.										
2. FIELD SET THE LIGHT DISTRIBUTION OF PARKING AREA FIXTURES AS DIRECTED.										
3. PROVIDE BUSSMAN HEB FUSEHOLDERS IN EACH PHASE CONDUCTOR AT EACH POLE BASE AND BOLLARD. FUSE WITH KTK FUSES AS RECOMMENDED BY THE FIXTURE MANUFACTURER OR 150% OF FIXTURE FULL LOAD CURRENT, WHICHEVER IS LESS.										

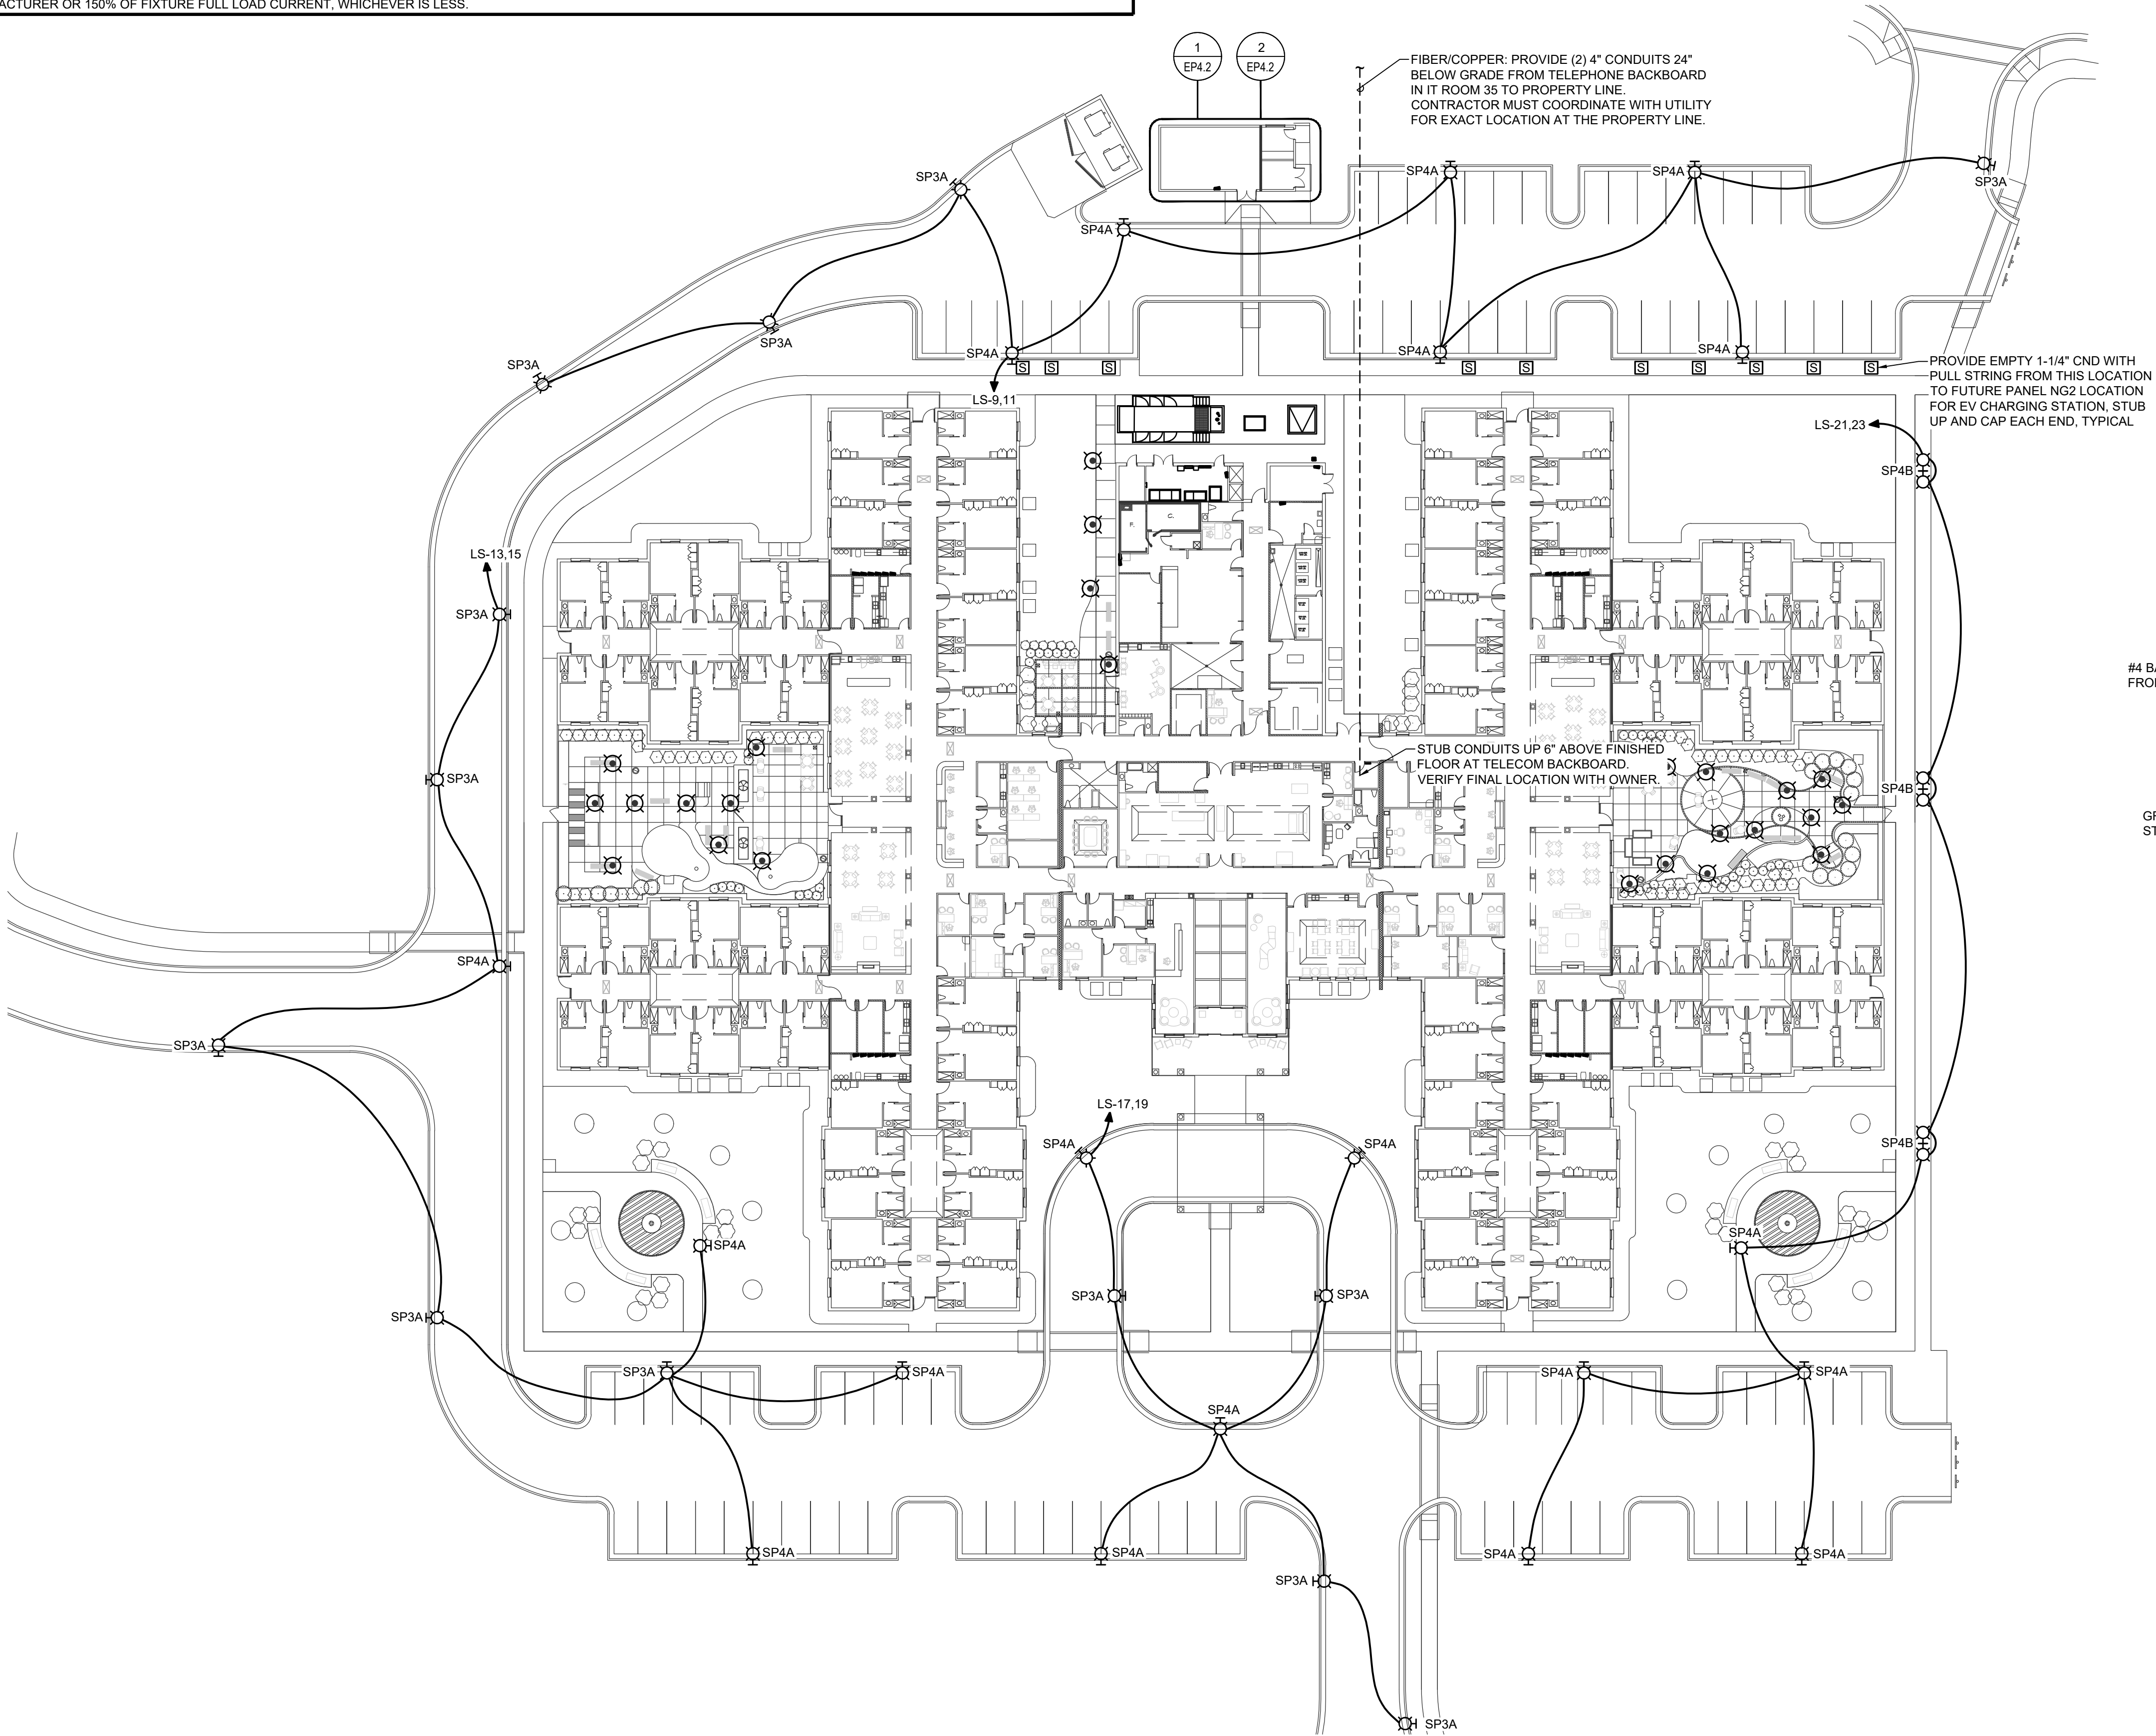


1 ELECTRICAL SITE LIGHTING PLAN
1" = 30'-0"

PLAN NORTH

SEE MINIMUM CONDUCTOR SIZE CHART SHEET E0.5 FOR SITE LIGHTING CONDUCTOR SIZING.

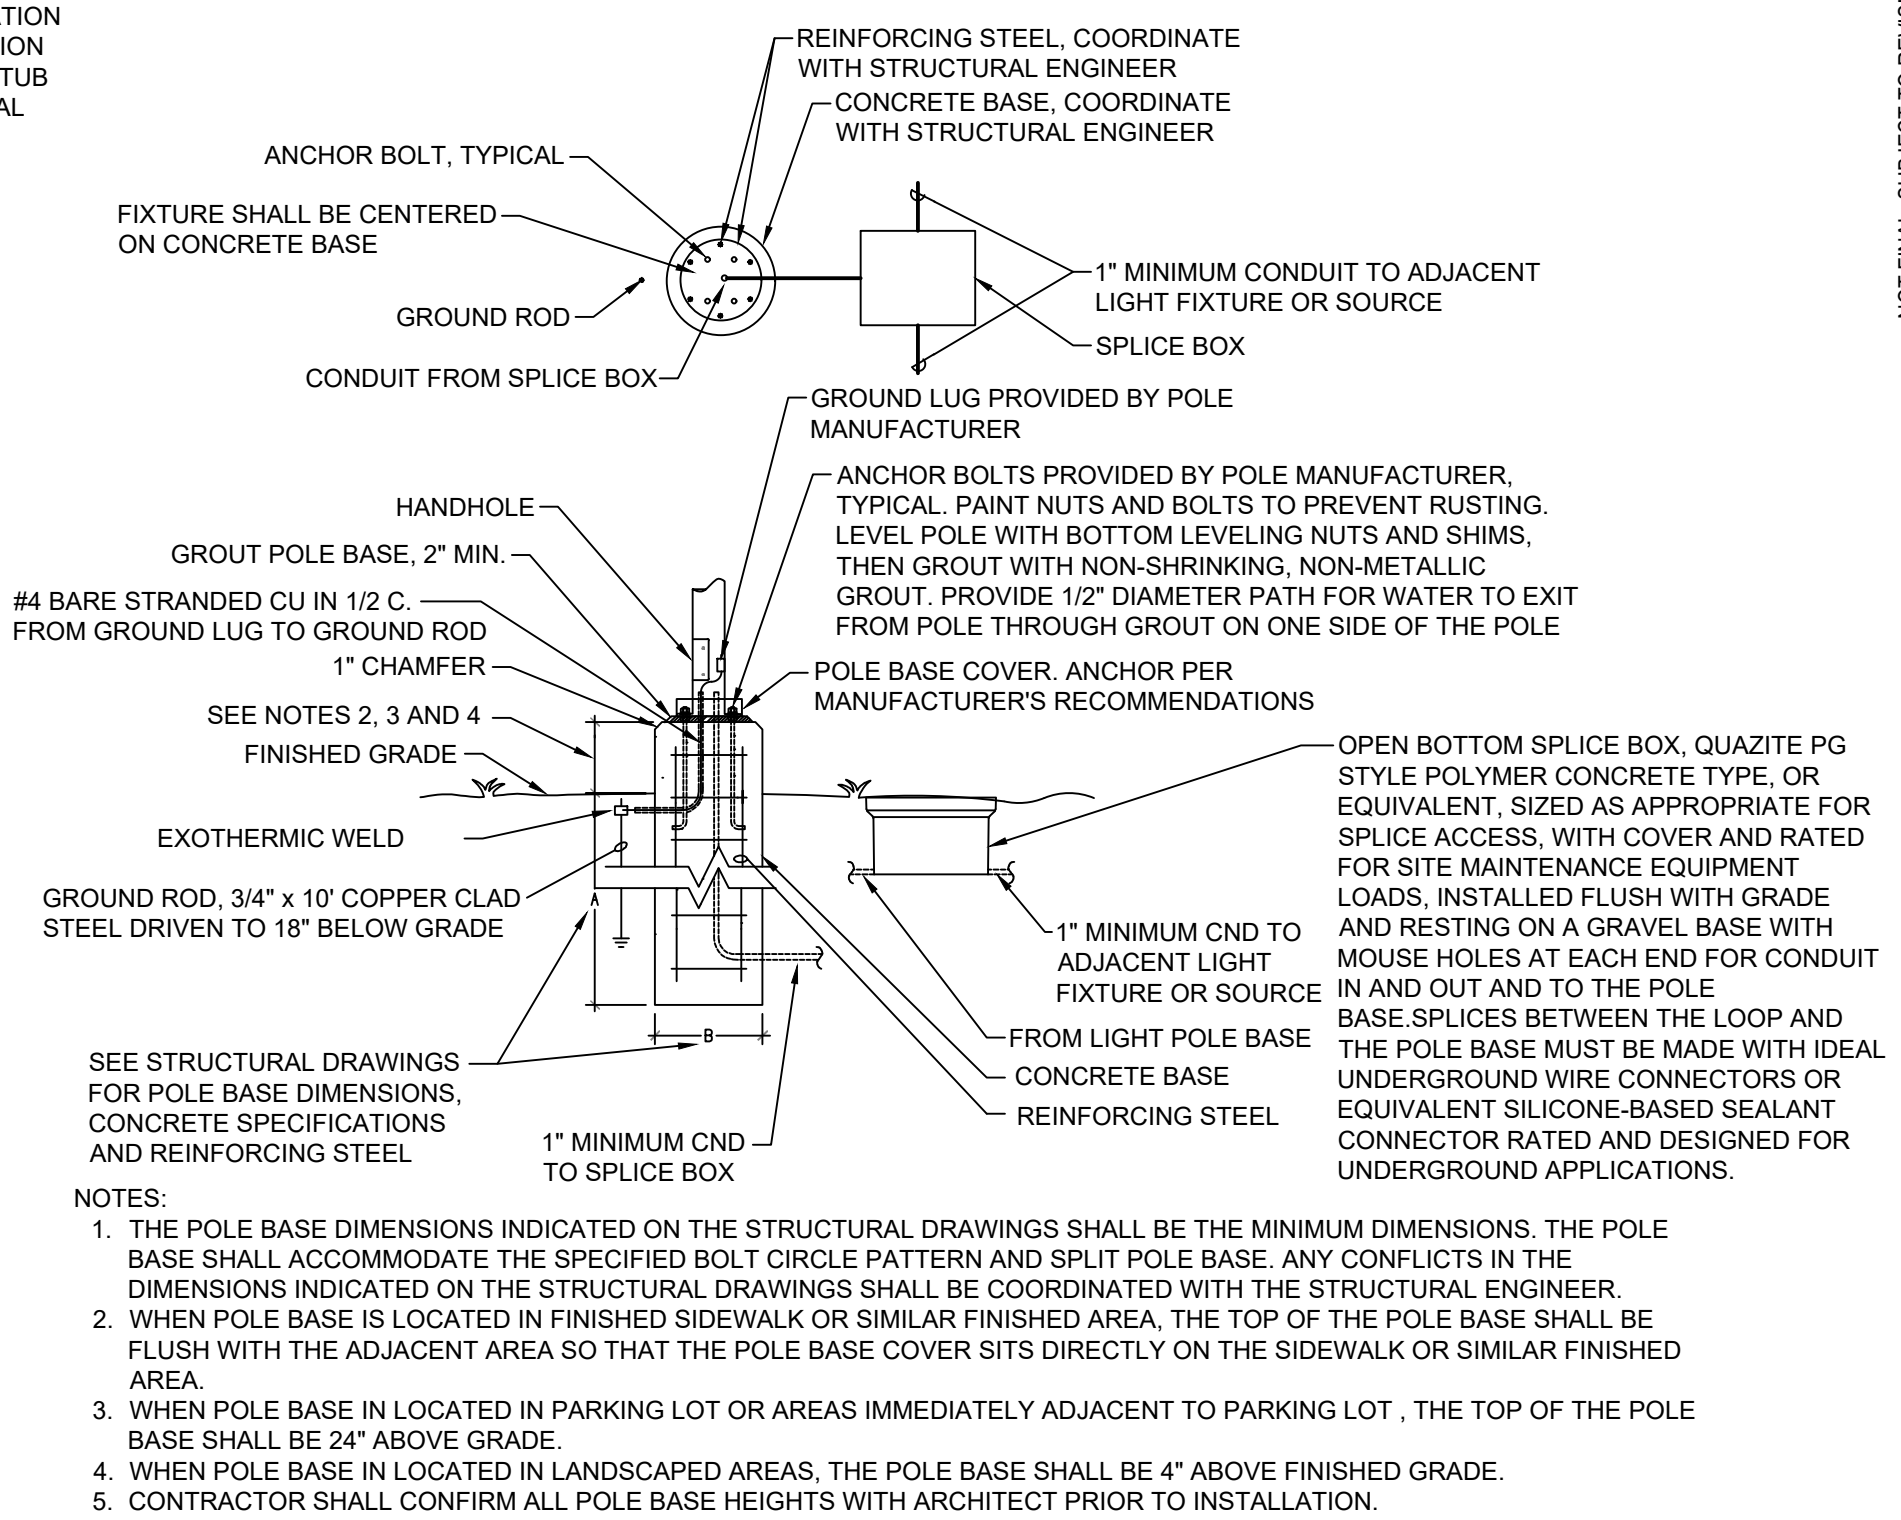

3 LIGHT POLE BASE DETAIL
NOT TO SCALE

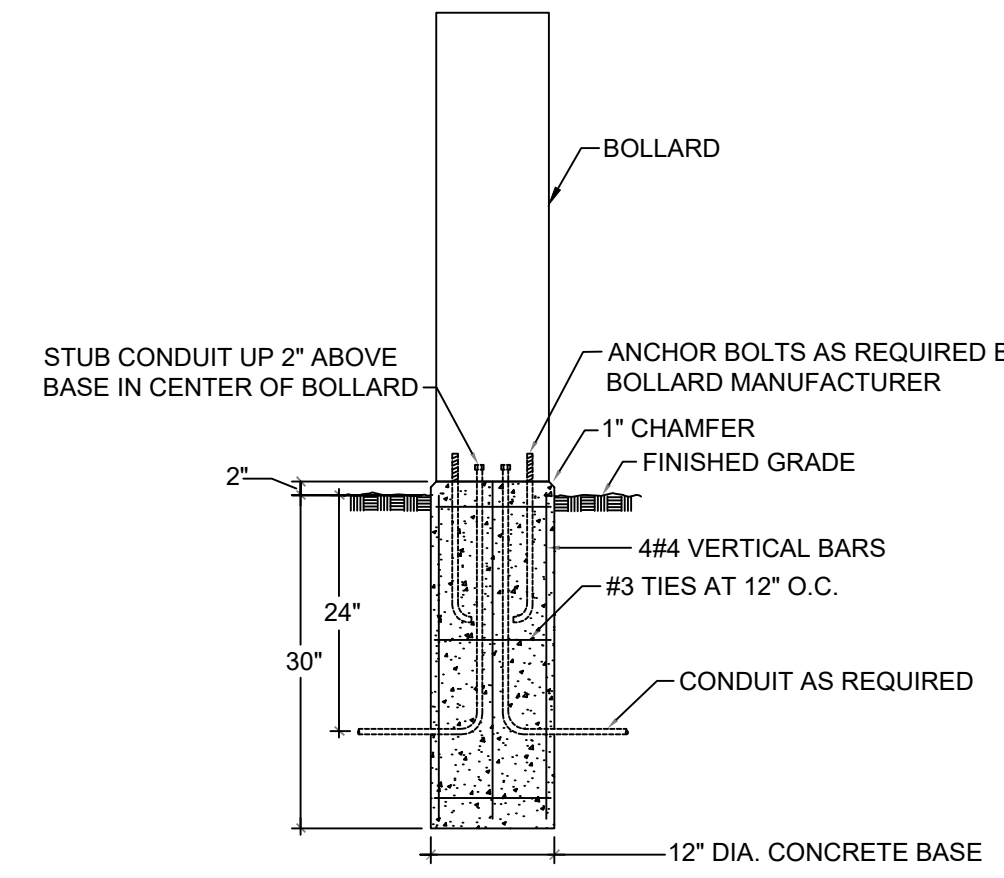

2 TYPE "SB" BOLLARD BASE DETAIL
NOT TO SCALE

NOTE: ALL CONCRETE WORK SHALL CONFORM TO SPECIFICATIONS AND SHALL BE 3000 PSI MINIMUM COMPRESSIVE STRENGTH AT 28 DAYS

CBHF
Engineers, PLLC
2246 Yaupon Drive
Wilmington, NC 28401
Phone: 910.791.4000
www.cbhfenr.com
© Copyright 2026 CBHF Engineers, PLLC NC# P-0506

PRELIMINARY
PRICING ONLY
NOT FOR
CONSTRUCTION

NORTH CAROLINA
REGISTERED PROFESSIONAL ENGINEER
EXPIRATION DATE 12/31/2026

David R. Polston
Professional Engineer
No. 10000
Exp. 12/31/2026

PRINCIPLE HEALTH CARE
WAKE COUNTY
Holly Springs, North Carolina

David R. Polston - Architect
3806 Park Ave. Suite C, Wilmington, NC 28403
Architecture Planning Design

120 BED
NURSING FACILITY
ELECTRICAL
SITE PLAN

E0.3

ENGINE-GENERATOR FUEL CONSUMPTON AND STORAGE CALCULATION

BASIS OF DESIGN ENGINE-GENERATOR SET: CAT C18
RATING: 600 KW / 750 KVA, STANDBY
FUEL: FUEL OIL, 35" API (60°F) GRAVITY, LHV 42,780 KJ/KG, AT 85°F, 7.001 LBS/GAL
FUEL CONSUMPTION FULL LOAD 42.1 GALS/HR
DEMAND LOAD 39.0 GALS/HR INTERPOLATED
75% LOAD 33.8 GALS/HR
FUEL STORAGE CAPACITY REQ'D. FOR 96 HOURS RUN TIME AT FULL LOAD 4042 GALS
DEMAND LOAD 3773 GALS
FUEL STORAGE CAPACITY REQ'D. FOR 96 HOURS RUN TIME AT CALCULATED DEMAND LOAD X 133% = 5018 GALS.

NOTES:
1. SUB-BASE FUEL STORAGE TANK SPECIFIED FOR NO LESS THAN 5,018 GALLONS. THE GENERATOR FUEL STORAGE SYSTEM MUST BE SIZED TO PROVIDE A MINIMUM OF 96 HOURS OF OPERATION AT THE CALCULATED EMERGENCY DEMAND LOAD, WITH STORAGE CAPACITY INCREASED TO 133% OF THE CALCULATED FUEL CONSUMPTION TO ENSURE ADEQUATE OPERATIONAL MARGIN IN ACCORDANCE WITH HEALTHCARE EMERGENCY PREPAREDNESS PRACTICES. SEE SPECS SECTION 16035, PARAS. K, AND M.
2. SET LOW FUEL ALARM AT 54 HOURS USABLE FUEL REMAINING AT FULL LOAD. SEE SPECS SECTION 16035, PARA. W.
3. DEMAND LOAD USED IN CALCULATION DOES NOT CONSIDER POWER FACTOR, WHICH IS LESS THAN UNITY.

AUTOMATIC TRANSFER SWITCH SCHEDULE

EQUIPMENT DESCRIPTION	TYPE	TRIP TYPE	RATING/ TRIP	V	PHASE	WIRES	IC RATING	ENCLOSURE
LIFE SAFETY BRANCH ATS-1	AUTOMATIC TRANSFER SWITCH	N/A	100A	208/120	3	4	-	NEMA-1 SURFACE
CRITICAL BRANCH ATS-2	AUTOMATIC TRANSFER SWITCH	N/A	400A	208/120	3	4	-	NEMA-1 SURFACE
EQUIPMENT SYSTEM ATS-3	AUTOMATIC TRANSFER SWITCH	N/A	1600A	208/120	3	4	-	NEMA-1 FREE STANDING

NOTES:
1. AUTOMATIC TRANSFER SWITCHES ARE SOLID NEUTRAL. SEE SPECS SECTION 16036.
2. CONTRACTOR IS RESPONSIBLE FOR NEC ART. 110.26 WORKING SPACES FOR EQUIPMENT.

ESTIMATED ENGINE-GENERATOR SET LOAD SUMMARY

LOAD	LOAD DESCRIPTION	DEMAND LOAD				EST. POWER FACTOR	EST. TOTAL KW
		PHASE A (VA)	PHASE B (VA)	PHASE C (VA)	TOTAL (VA)		
ATS-1	LIFE SAFETY LOADS	4,722	5,047	2,558	12,327	0.98	12
ATS-2	CRITICAL LOADS	28,245	34,622	33,877	96,744	0.98	95
ATS-3	EQUIPMENT LOADS	161,257	154,749	157,978	473,984	0.92	436
TOTAL ESSENTIAL LOADS		583,055					
TOTAL ENGINE-GENERATOR SET LOAD (VA)		194,224	194,418	194,413			
TOTAL ENGINE-GENERATOR SET LOAD (KW)		543					
TOTAL ENGINE-GENERATOR SET LOAD (KVA)		583					

NOTES:
1. E-G SET RATING IS AT 80% PF.
2. SEE SPECIFICATIONS SECTION 16035, PARA. K, FOR SIZING REQUIREMENTS.
3. SEE MAIN DISTRIBUTION SWBD LOAD SUMMARY FOR UTILITY SERVICE ESTIMATED DEMAND LOADS.

CBHF
Engineers, PLLC

2246 Yaupon Drive
Wilmington, NC 28401
Phone: 910.791.4000
www.cbhngineers.com
© Copyright 2026 CBHF Engineers, PLLC NCH P-0506


PRELIMINARY
PRICING ONLY
NOT FOR
CONSTRUCTION

PRINCIPLE HEALTH CARE
WAKE COUNTY
Holly Springs, North Carolina

David R. Polston - Architect
3806 Park Ave. Suite C, Wilmington, NC 28403
Architecture Planning Design

120 BED
NURSING FACILITY
ELECTRICAL POWER
RISER DIAGRAM

EO
.4

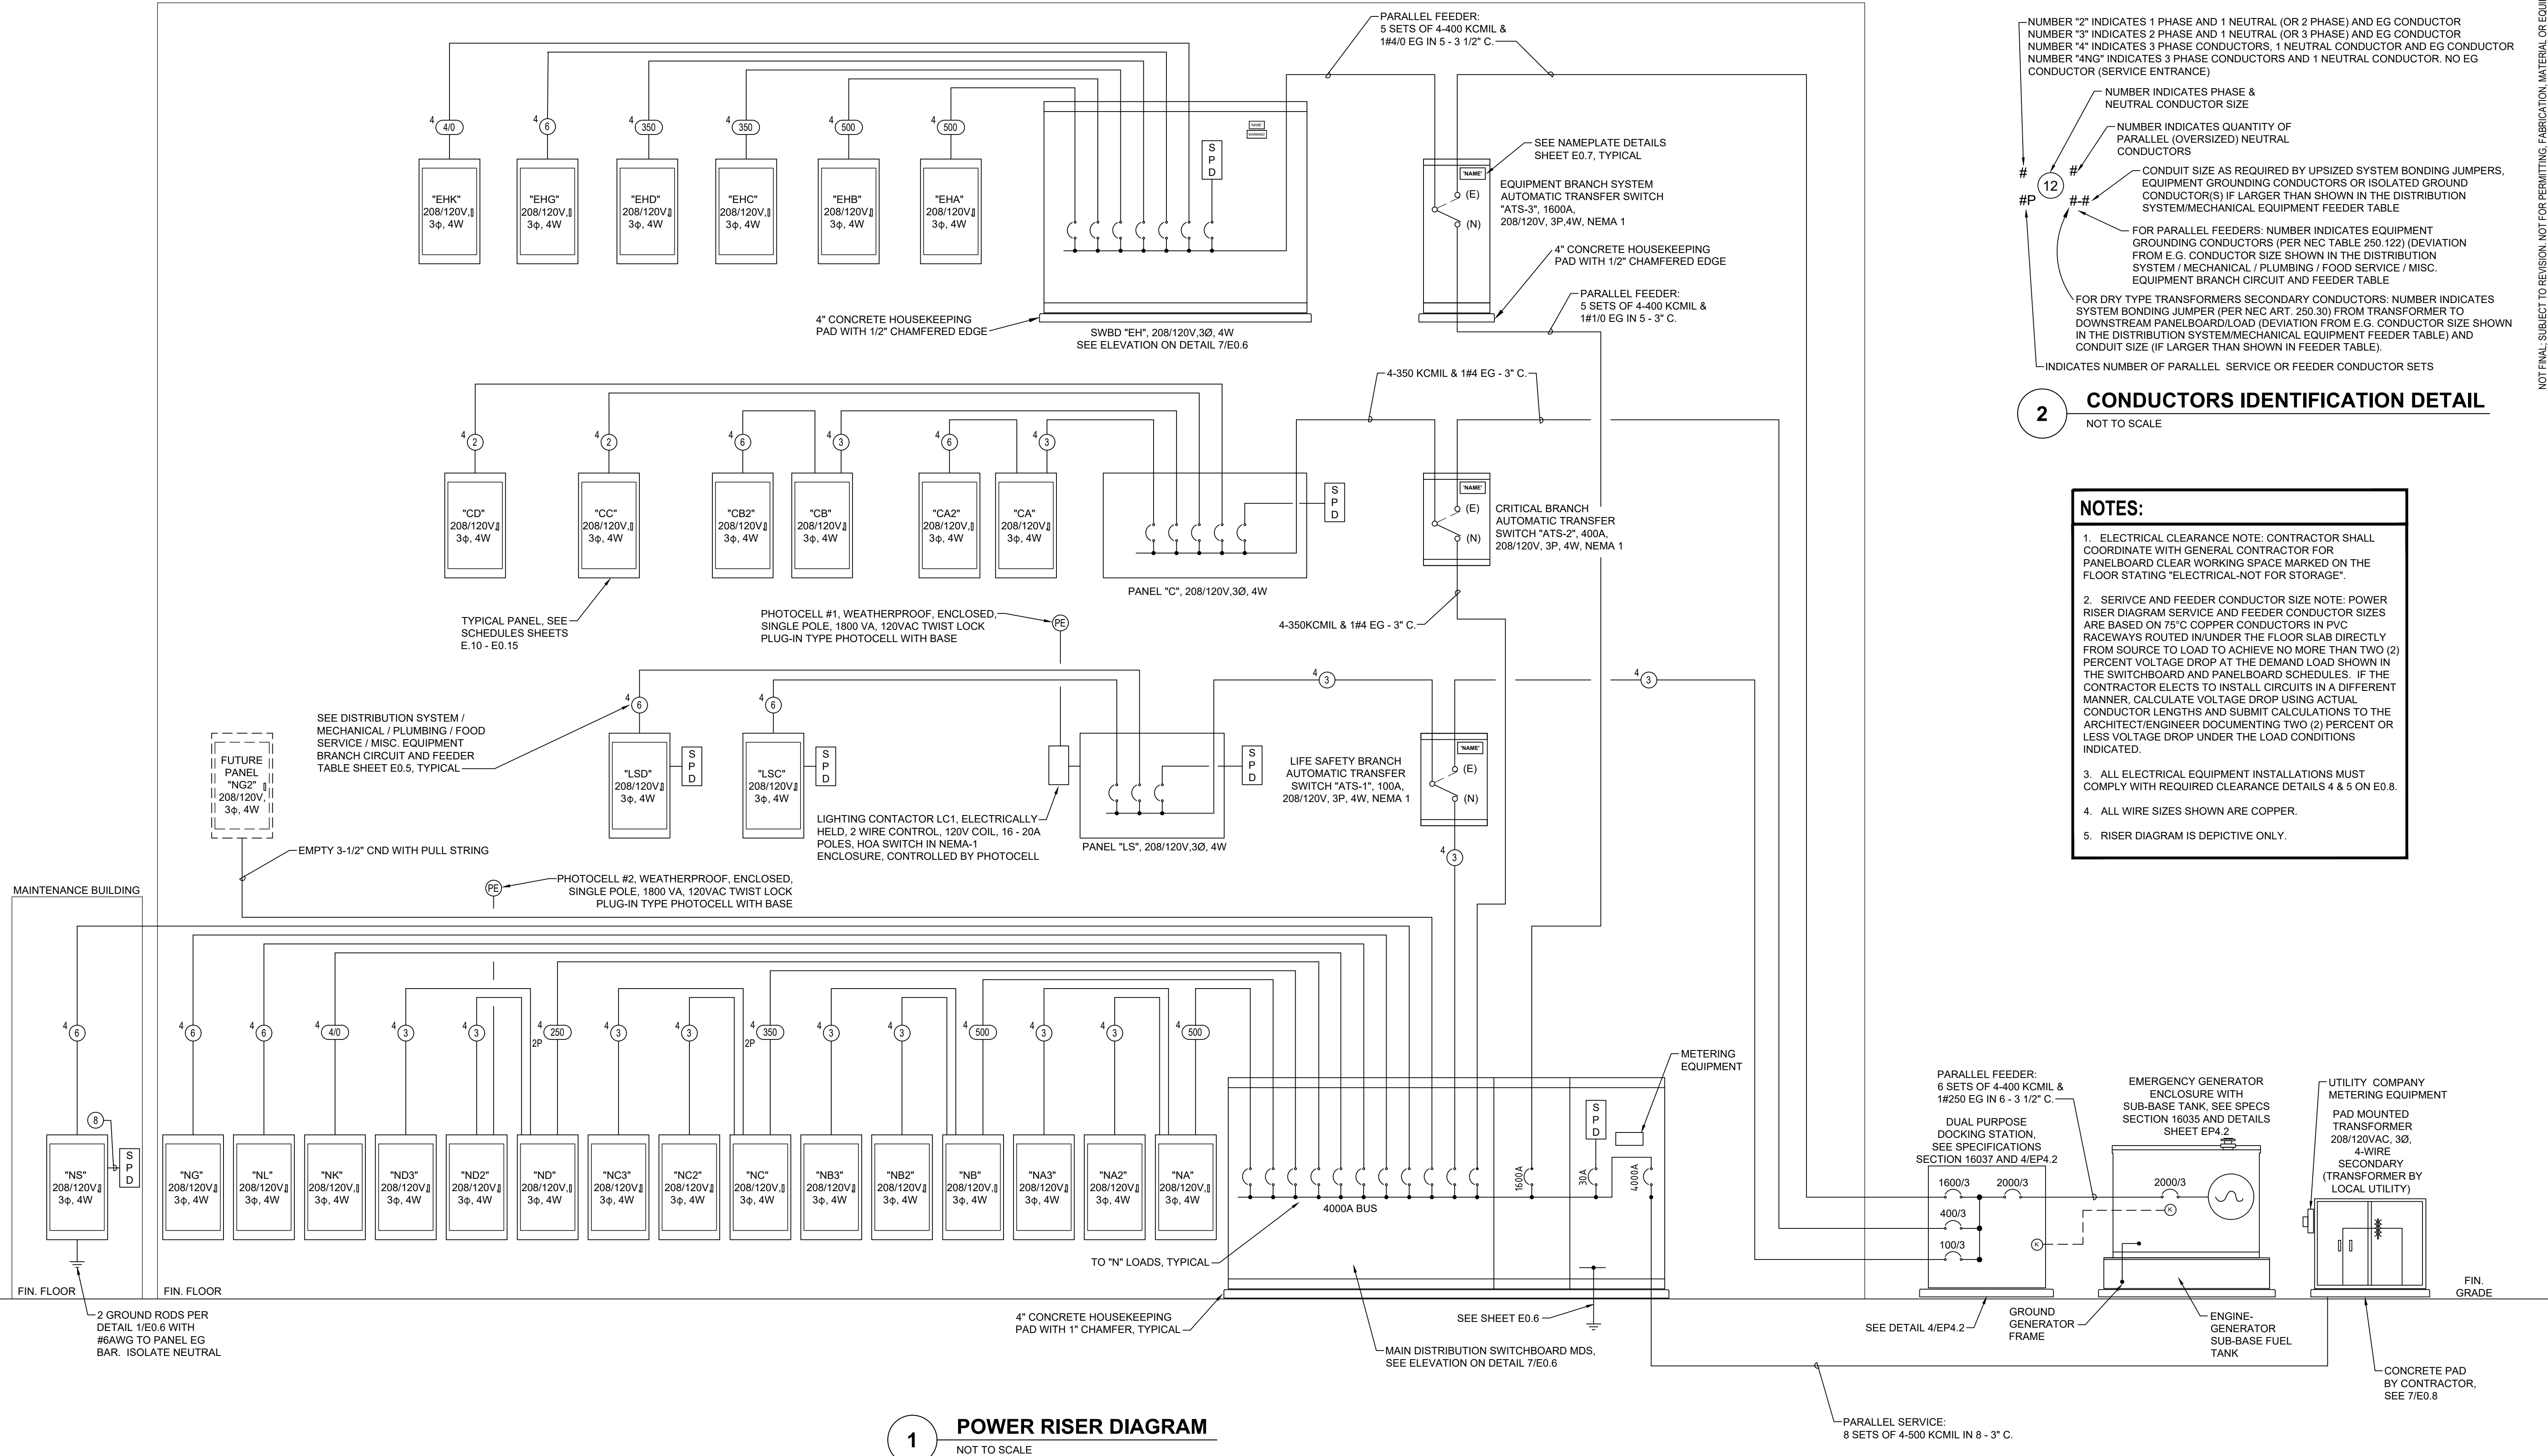



NOT FINAL; SUBJECT TO REVISION. NOT FOR PERMITTING, FABRICATION, MATERIAL OR EQUIPMENT PURCHASE, INSTALLATION, OR CONSTRUCTION. PRICING SHALL STATE ALL ACCUMULATING EVOLVING ALLOWANCES AND CONTINGENCES AND SHALL BE RECONCILED WITH THE FINAL BIDDING AND ORDERED DOCUMENTS.

David R. Polston - Architect
3806 Park Ave. Suite C, Wilmington, NC 28403
Architecture Planning Design

120 BED
NURSING FACILITY
ELECTRICAL
SCHEDULES

E0.5

NOTES:

1. CONDUCTOR SIZES SHOWN ARE COPPER.
2. CORD SETS PROVIDED WITH EQUIPMENT. VERIFY WIRING DEVICE CONFIGURATION.
3. SEE FOOD SERVICE ELECTRICAL EQUIPMENT NOTES, SHEET EQ.2

NOTES:


1. CONDUCTOR LENGTHS ARE BASED ON SINGLE & THREE PHASE, 90% POWER FACTOR LOADS USING 75°C COPPER CONDUCTORS IN EMT RACEWAYS TO ACHIEVE NO MORE THAN 3 PERCENT VOLTAGE DROP.
2. CALCULATIONS ASSUME LOAD OF 80% OF CIRCUIT BREAKER TRIP (12A, 16A & 24A, 32A, 40A & 48A, RESPECTIVELY) ARE CONCENTRATED AT THE END OF THE CIRCUITS.
3. IF LOAD CHARACTERISTICS DIFFER FROM ABOVE, CALCULATE USING KNOWN CHARACTERISTICS AND SUBMIT CALCULATIONS TO THE ARCHITECT/ENGINEER DOCUMENTING 3% OR LESS VOLTAGE DROP UNDER THE ACTUAL LOAD CONDITIONS.
4. WHEN A DEDICATED SINGLE LOAD LESS THAN NOTED ABOVE IS KNOWN, THE CONTRACTOR MAY UTILIZE SMALLER CONDUCTORS UPON SUBMISSION OF VOLTAGE DROP CALCULATIONS DOCUMENTING 3% OR LESS VOLTAGE DROP. THE MINIMUM LOAD SHALL BE ASSUMED TO BE 60% OF THE CB TRIP RATING REGARDLESS OF ACTUAL DEDICATED LOAD.
5. USE THE LARGER OF THE CONDUCTORS INDICATED ON THE DRAWINGS OR THIS TABLE.

NOTES:


1. GDSS = GENERAL DUTY SAFETY SWITCH, NEMA-1 ENCLOSURE.
2. DHSS = HEAVY DUTY SAFETY SWITCH, NEMA-3R ENCLOSURE.
3. SEE PANEL SCHEDULES FOR CIRCUITS.
4. PROVIDE LOCAL DISCONNECT IF NOT PROVIDED WITH EQUIPMENT.
5. SEE MINIMUM BRANCH CIRCUIT SIZE CHART ON SHEET E0.5 AND INCREASE CONDUCTOR SIZES AS REQUIRED TO ACCOMMODATE CIRCUIT LENGTH.
6. SEE MECHANICAL DRAWINGS FOR ADDITIONAL INFORMATION.
7. CONDUCTOR COLUMN IS PHASE AND NEUTRALS (WHERE APPLICABLE).
REFER TO DISTRIBUTION SYSTEM / MECH. / PLUMB. / FS / MISC. EQUIP.
BRANCH CIRCUIT & FEEDER TABLE, SHEET E0.5 FOR FULL CIRCUIT
DESCRIPTION. SIZES SHOWN ARE COPPER, AWG UNO.

TABLE NOTES:


1. TABLE IS FOR SINGLE THWN CONDUCTORS IN EMT ONLY. OTHER INSULATIONS, RACEWAY TYPES OR CABLE CONFIGURATIONS MAY REQUIRE LARGER RACEWAYS OR DIFFERENT CABLE CONFIGURATIONS AND ARE THE RESPONSIBILITY OF THE CONTRACTOR.
2. DRY TYPE TRANSFORMER SECONDARY CONDUCTORS AND PARALLEL FEEDERS REQUIRE UPSIZED SYSTEM BONDING JUMPERS AND EQUIPMENT GROUNDING CONDUCTORS AND RACEWAYS THAN SHOWN IN THIS TABLE. UPSIZE AS REQUIRED.
3. ALL CONDUCTOR RATINGS ARE FOR 75 DEGREES C.
4. ALL NEUTRALS ARE FULL SIZE.
5. CONTRACTOR MAY USE DIFFERENT COMBINATIONS OF CONDUCTORS TO ACHIEVE THE REQUIRED AMPACITY, UPON APPROVAL OF THE ARCHITECT/ENGINEER.
6. "3" REPRESENTS A 3 SURROUNDED BY A CIRCLE (OR ELIPSE FOR MULTI-DIGIT CONDUCTOR SIZES) ON THE DRAWINGS, TYPICAL. SEE DETAIL 5/E-006. "2X", "3 X" AND "4 X" (2, 3 & 4 PARALLEL SETS OF CONDUCTORS) REPRESENT "2P", "3P" AND "4P" TERMINOLOGY USED ON THE DRAWINGS.
7. THE NUMBER OF PARALLEL RACEWAYS IS TYPICALLY SHOWN AS "2 X 3", INDICATING 2 - 3" RACEWAYS.
8. SEE SPECS SECTION 16025 REGARDING ALLOWED USE OF ALUMINUM CONDUCTORS.

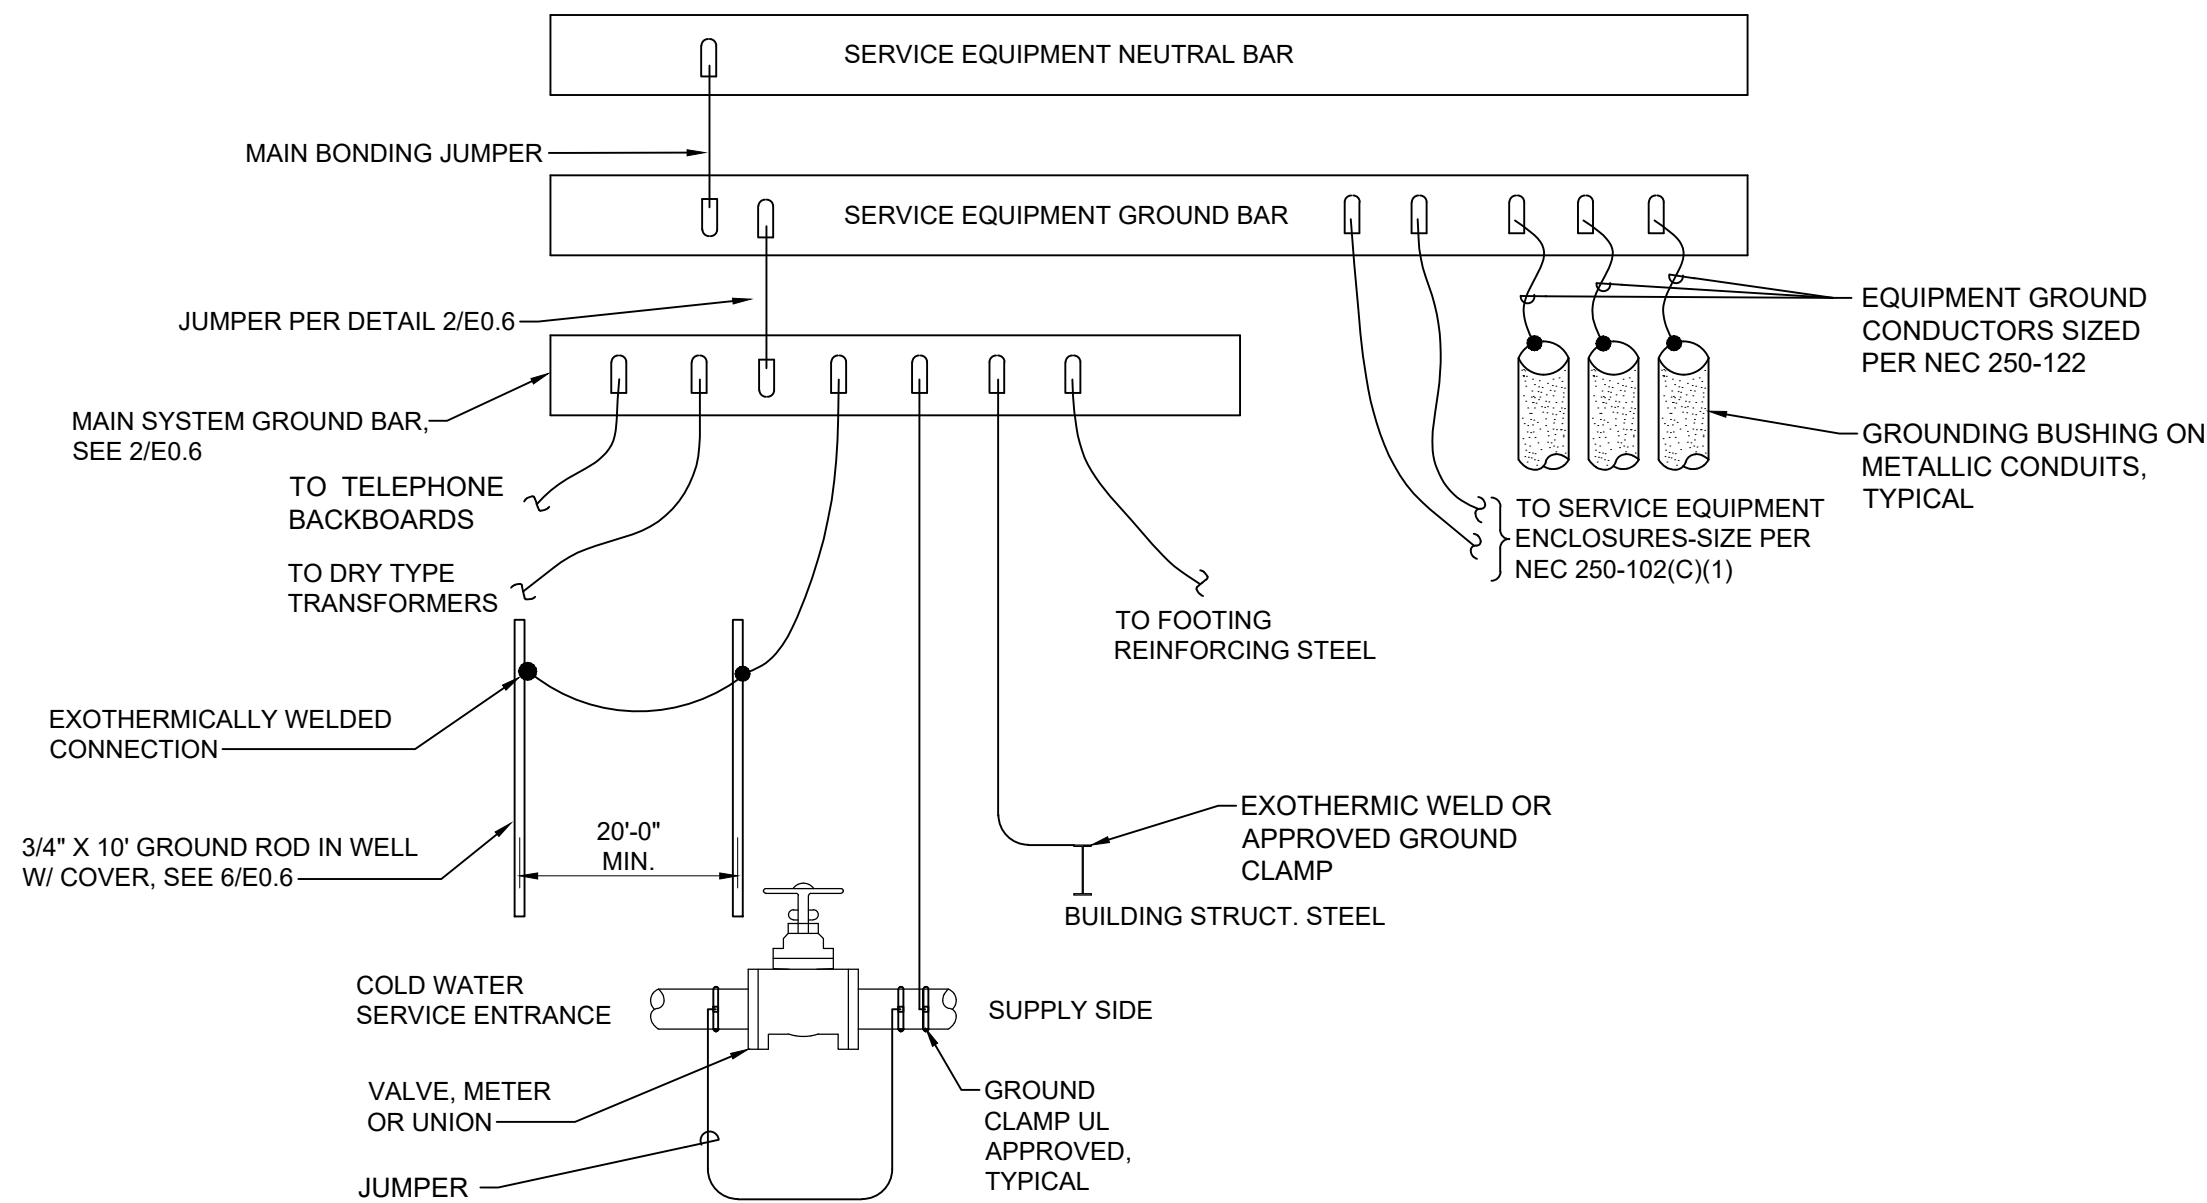


1 SERVICE GROUNDING DETAIL
NOT TO SCALE

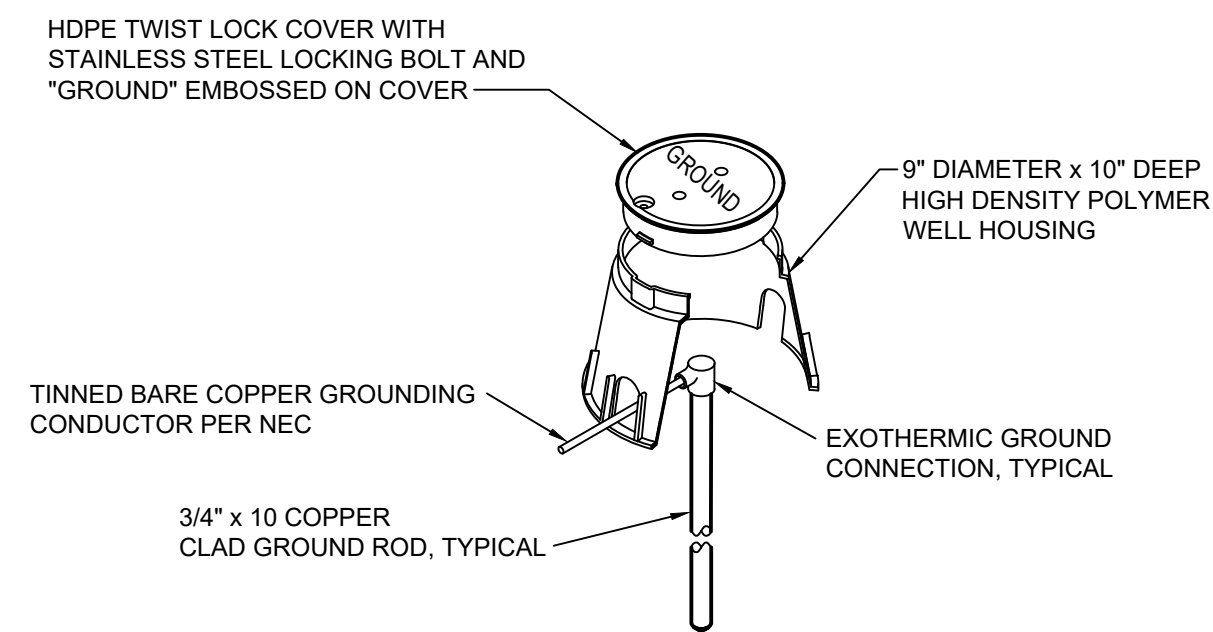


6 GROUNDING INSPECTION WELL DETAIL
NOT TO SCALE

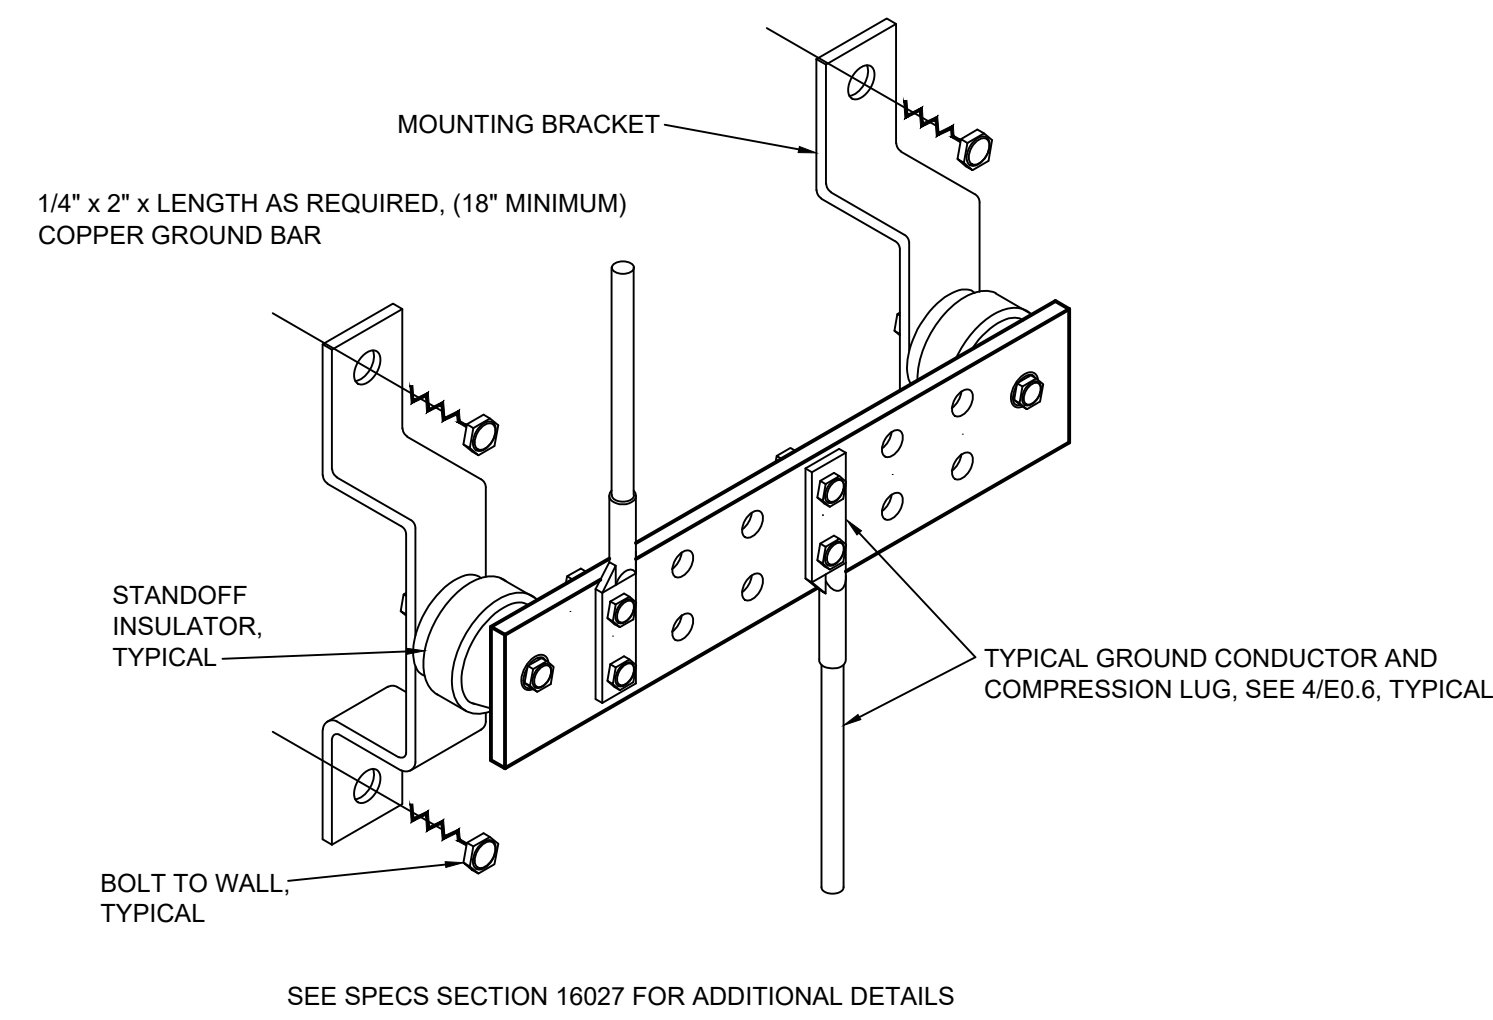


3 TYPICAL GROUNDING BAR MOUNTING DETAIL
NOT TO SCALE

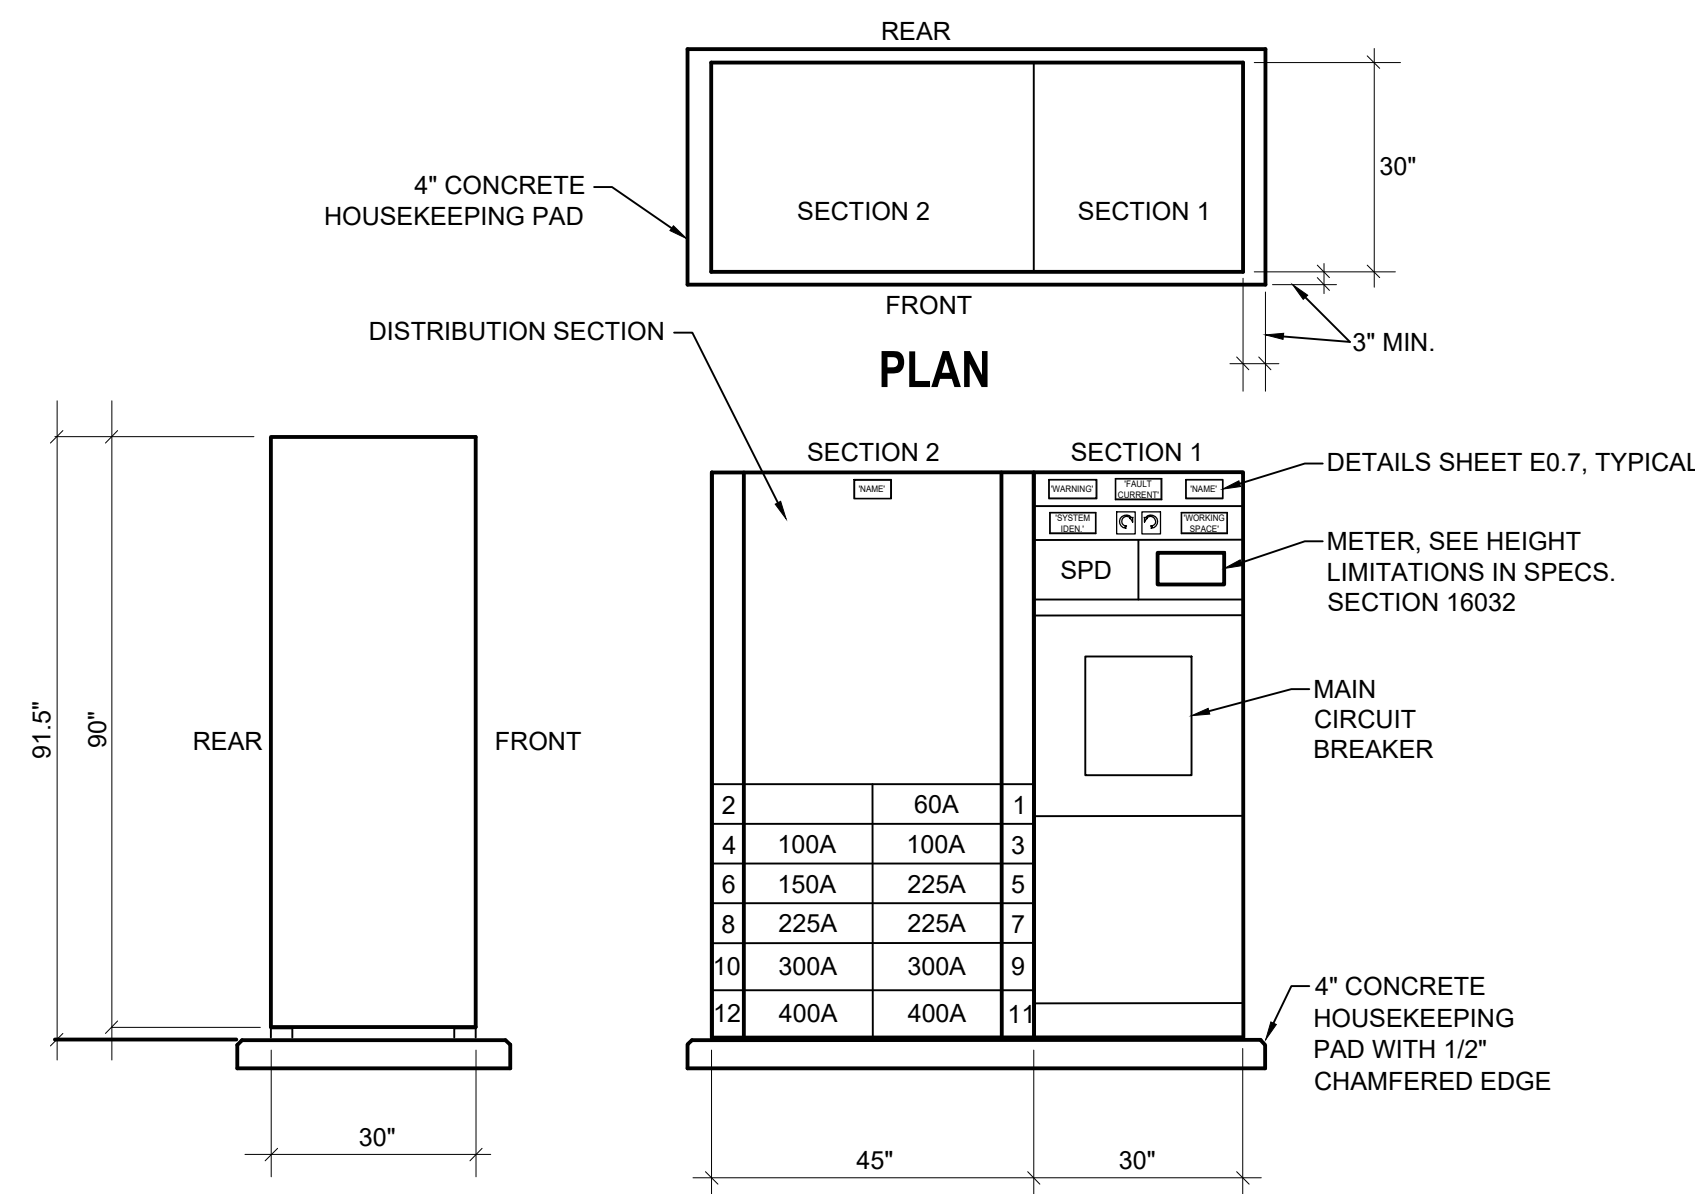


8 SWITCHBOARD "EH" ELEVATION
NOT TO SCALE

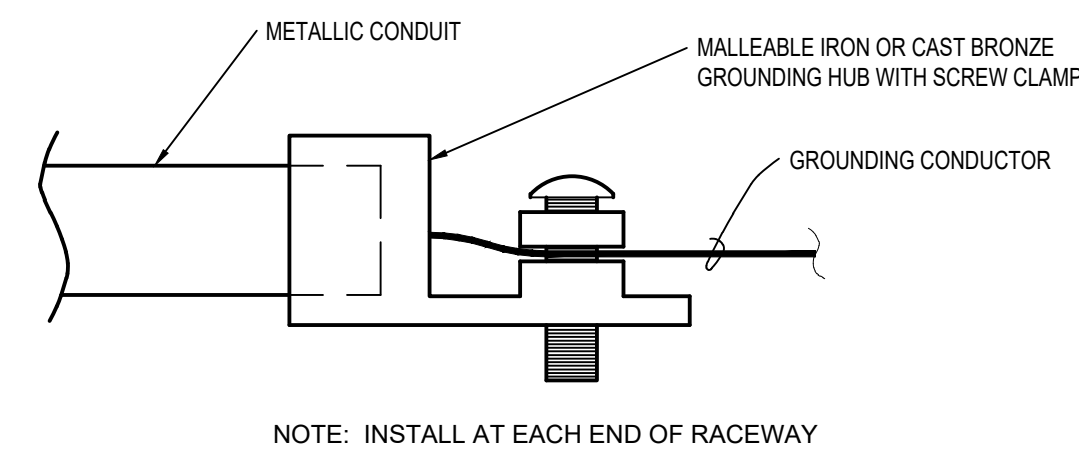


5 CONDUIT HUB AND GROUNDING CONDUCTOR DETAIL
NOT TO SCALE

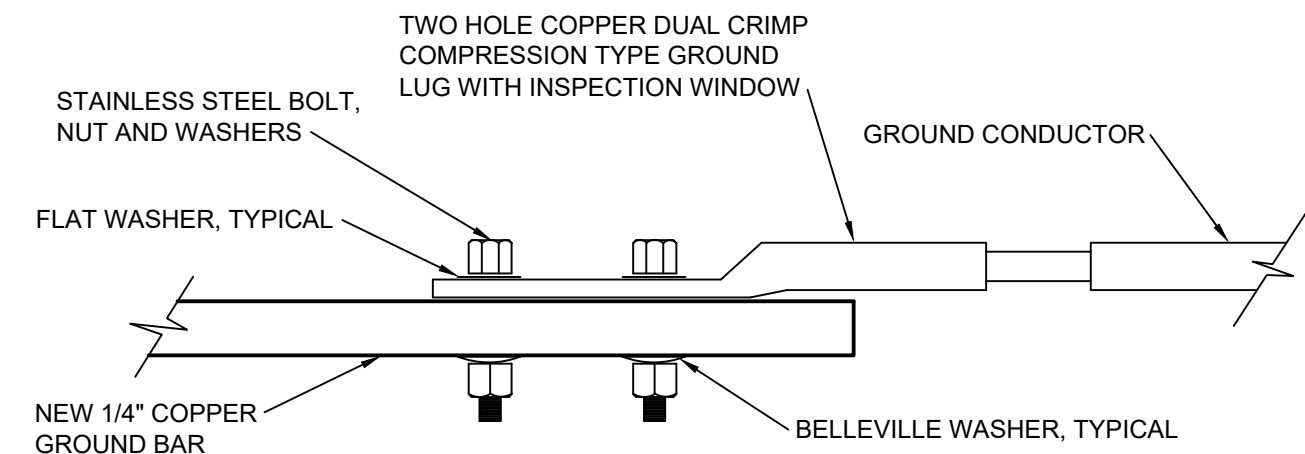

4 TYPICAL GROUND BAR CONNECTION DETAIL
NOT TO SCALE

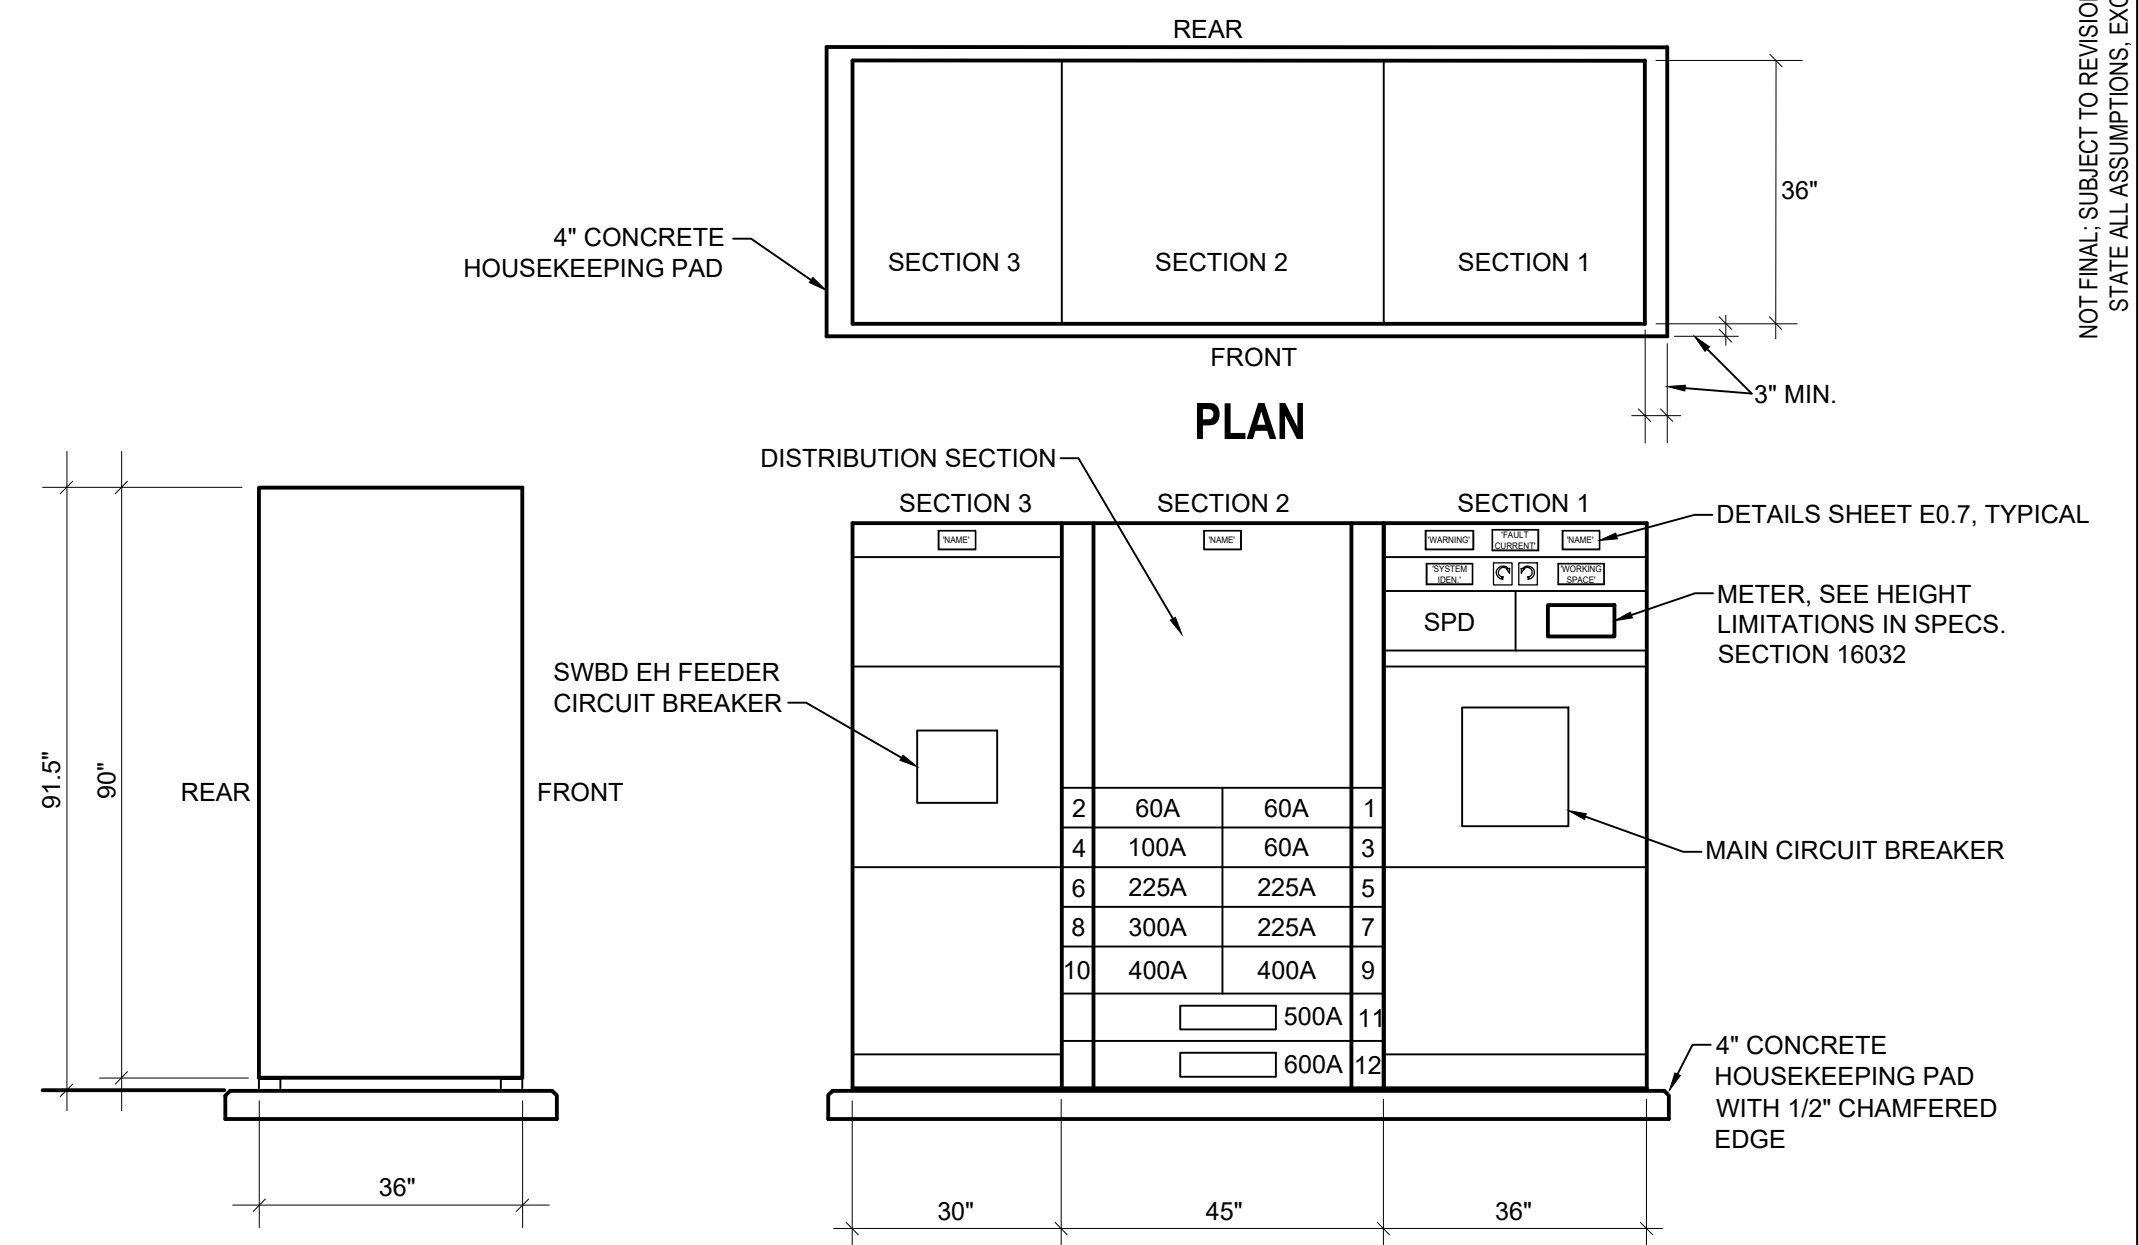


7 MAIN DISTRIBUTION SWITCHBOARD "MDS" ELEVATION
NOT TO SCALE

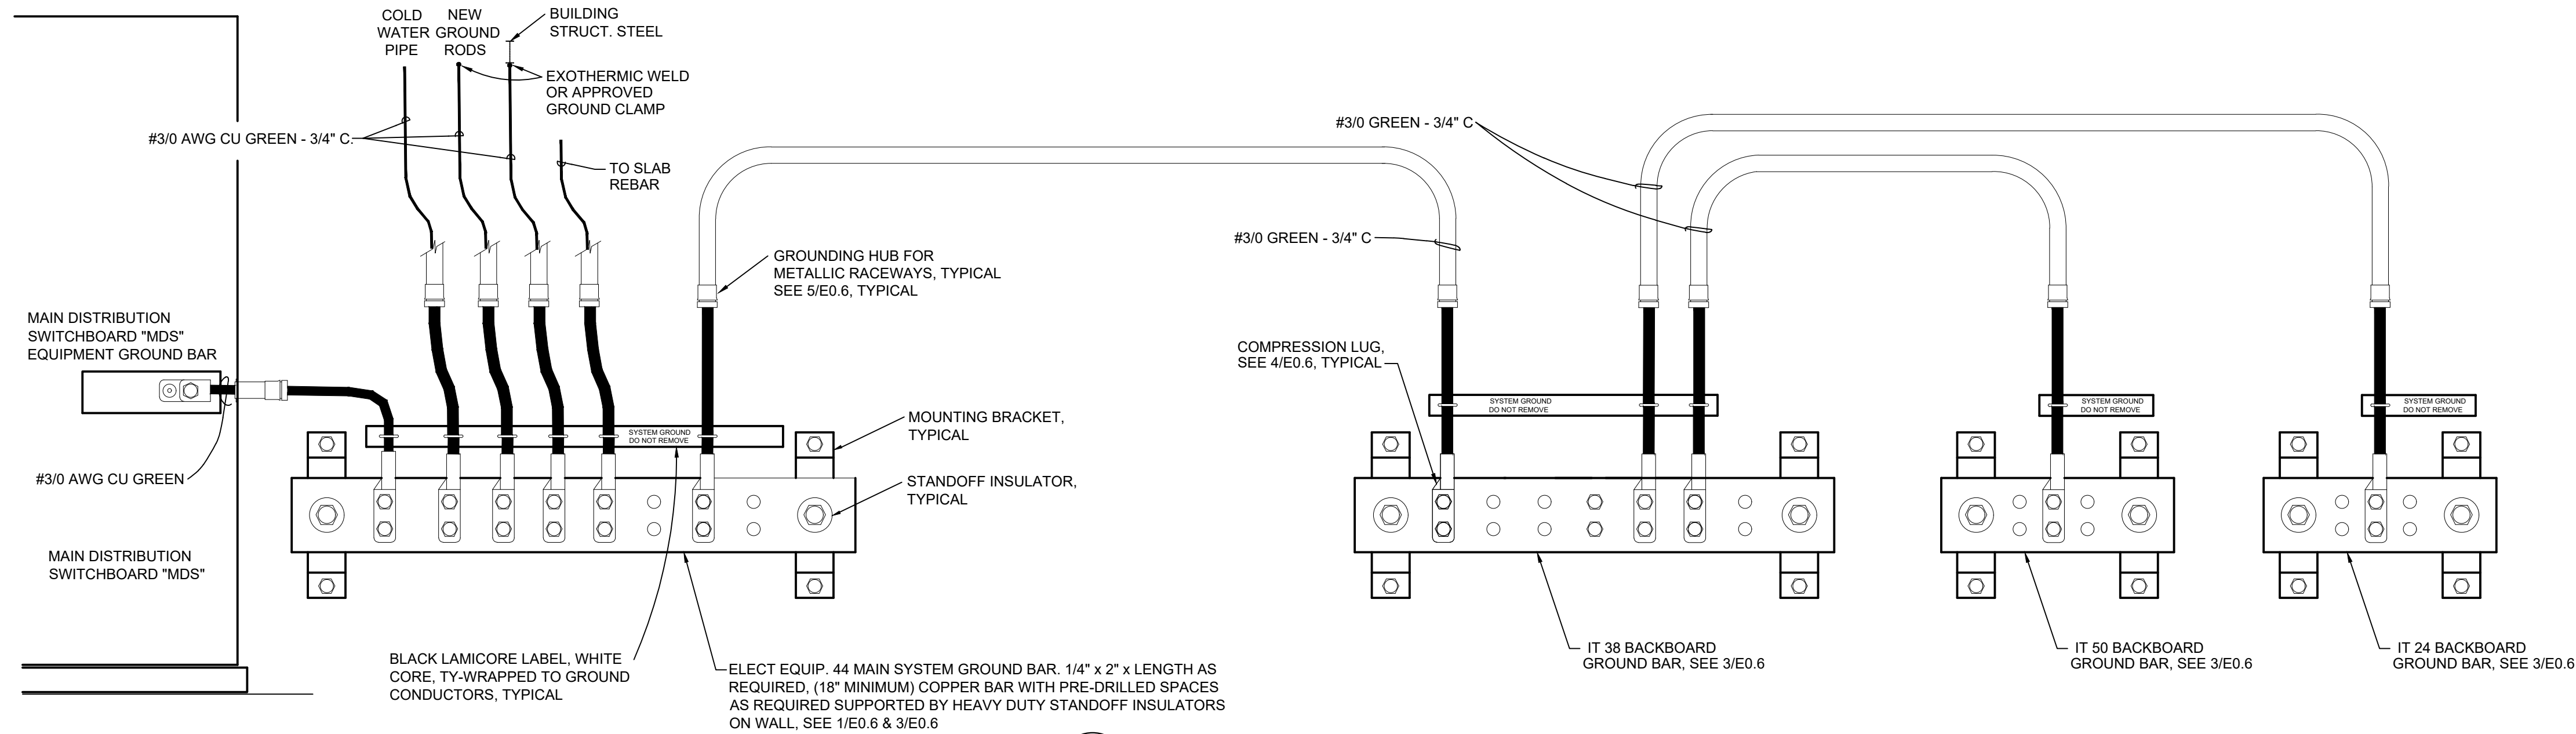


2 SYSTEM GROUND DETAIL
NOT TO SCALE


NOT FINAL SUBJECT TO REVISION. NOT FOR PERMITTING, FABRICATION, MATERIAL OR EQUIPMENT PURCHASE, INSTALLATION, OR CONSTRUCTION. PRICING SHALL STATE ALL ASSUMPTIONS, EXCLUSIONS, ALLOWANCES, AND CONTINGENCIES AND SHALL BE RECONCILED WITH THE FINAL SIGNED AND SEALED DOCUMENTS.

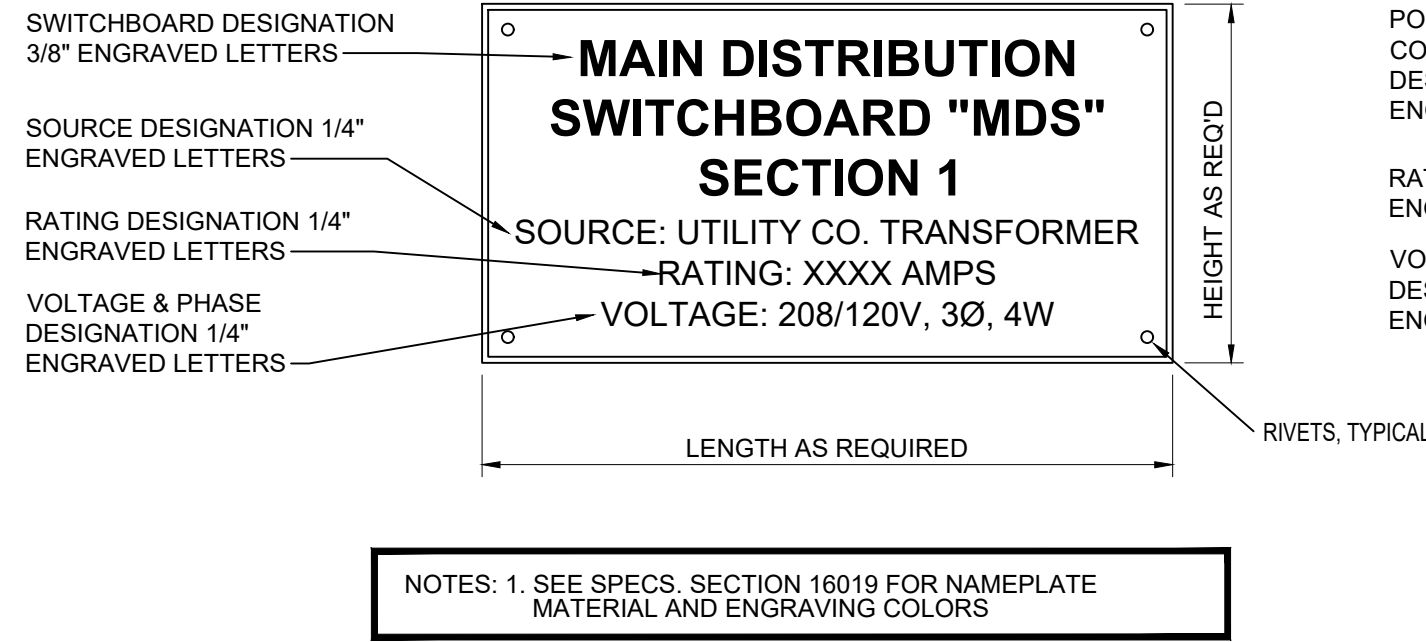


1 MAIN DISTRIBUTION SWITCHBOARD "MDS" NAMEPLATE DETAIL
NOT TO SCALE

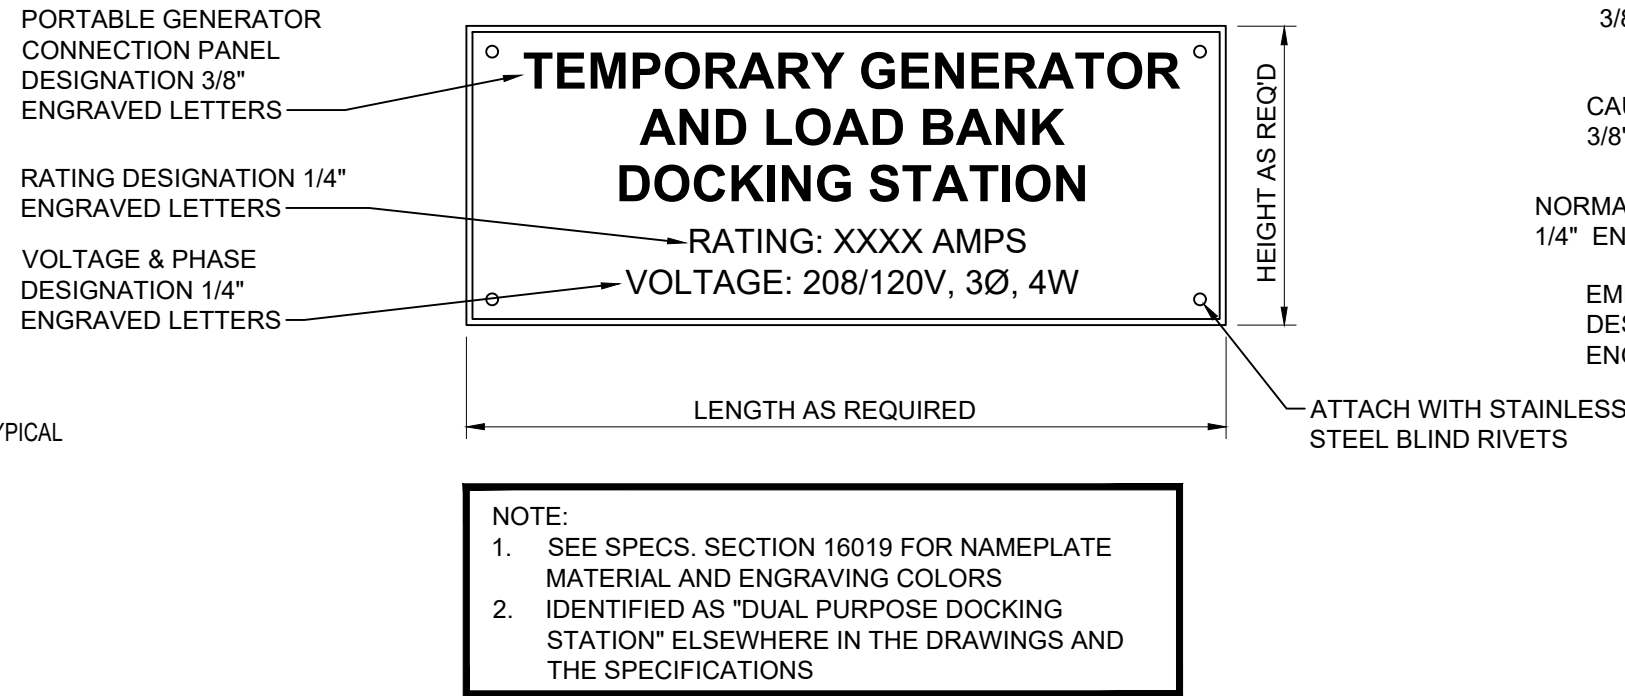


2 TEMPORARY GENERATOR AND LOAD BANK DOCKING STATION NAMEPLATE DETAIL
NOT TO SCALE

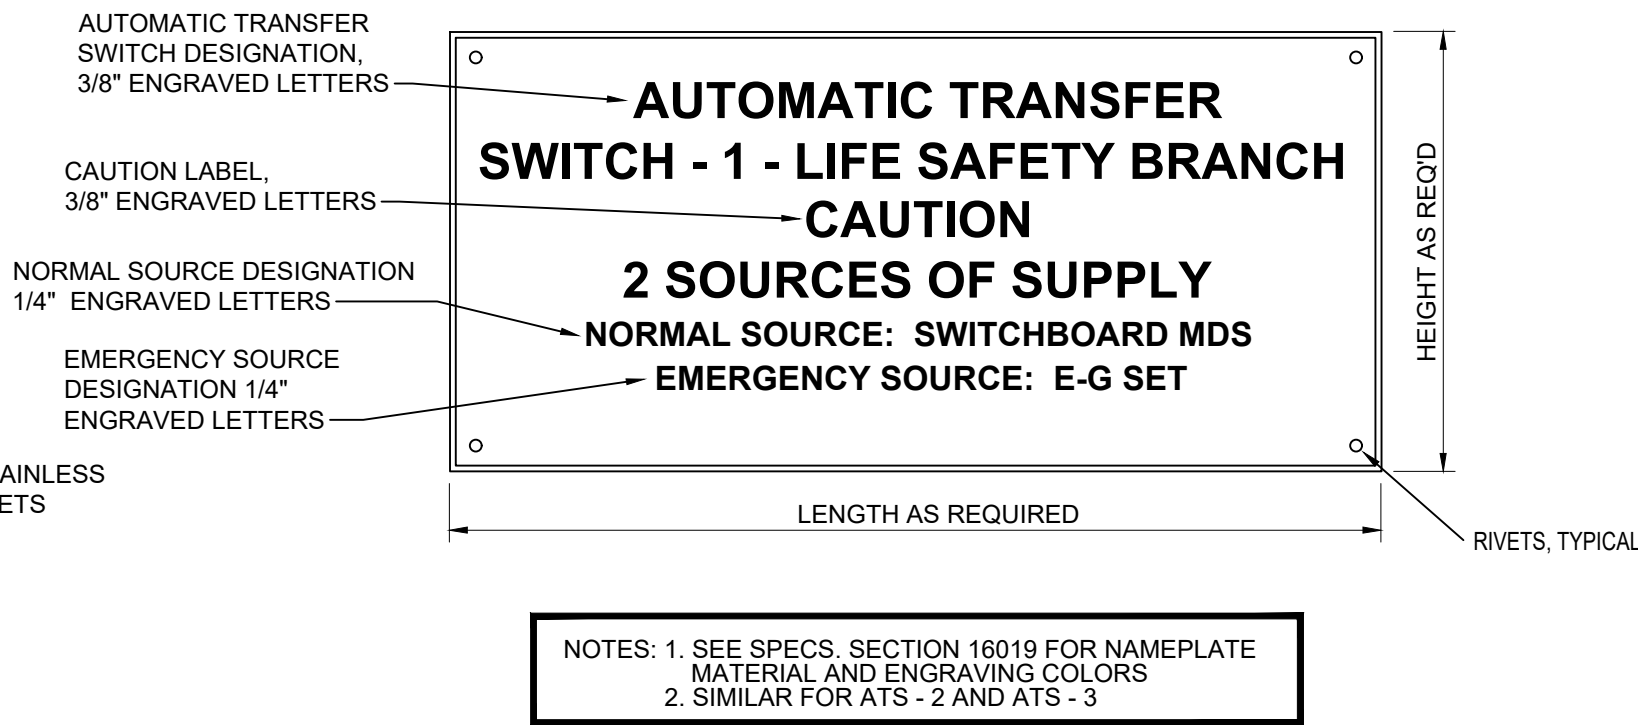


3 TYPICAL AUTOMATIC TRANSFER SWITCH NAMEPLATE DETAIL
NOT TO SCALE

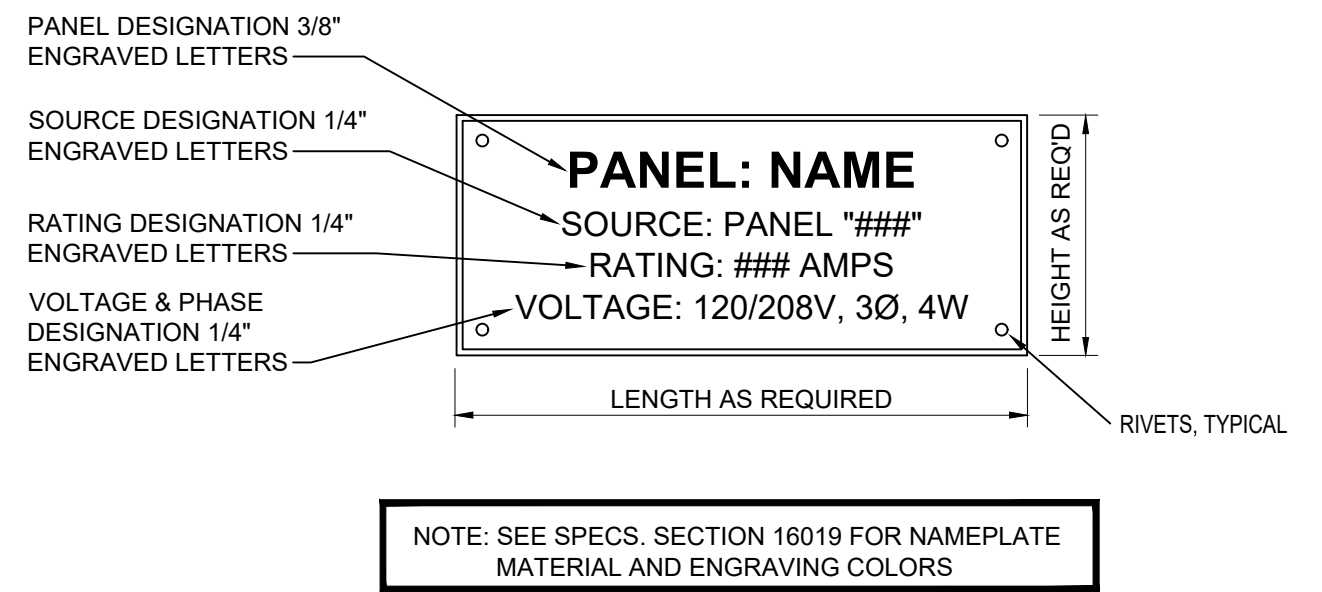


4 TYPICAL PANELBOARD NAMEPLATE DETAIL
NOT TO SCALE

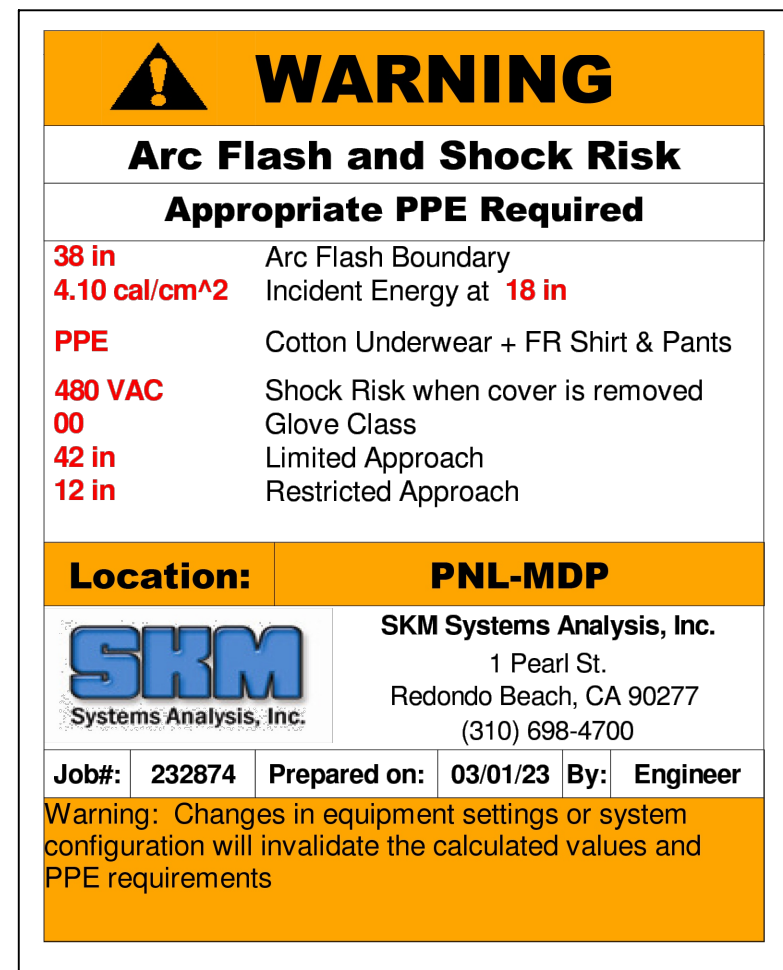


5 TYPICAL ARC FLASH LABEL
NOT TO SCALE

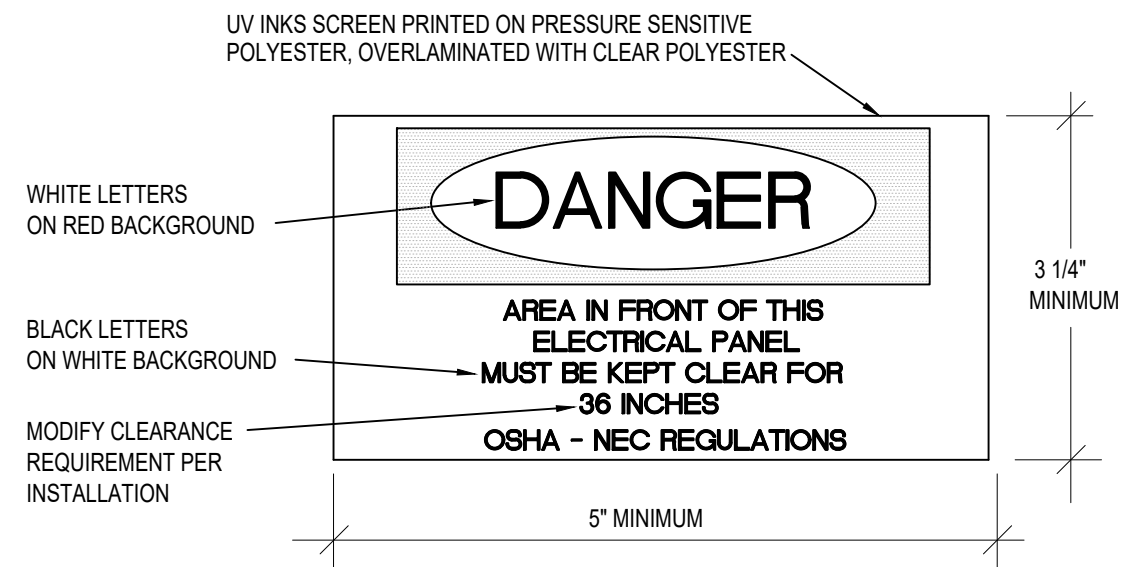


6 NEC WORKING SPACE LABEL DETAIL
NOT TO SCALE

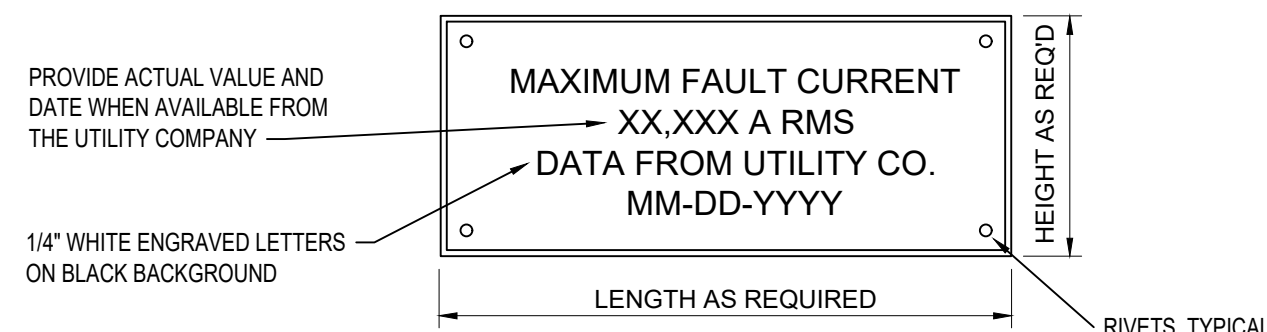


7 FAULT CURRENT NAMEPLATE DETAIL
NOT TO SCALE

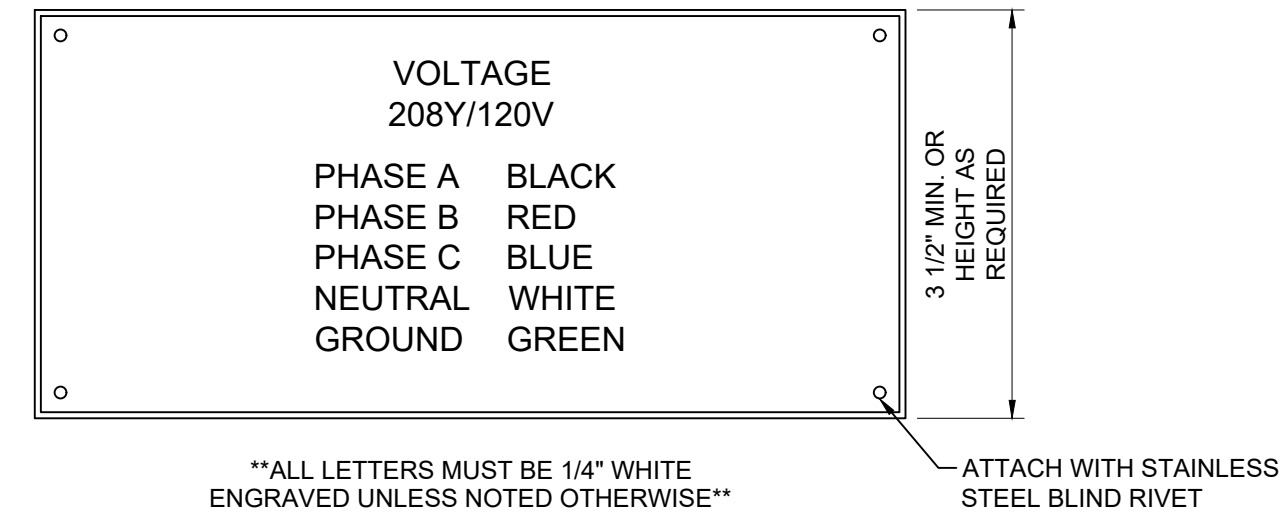


8 SYSTEM IDENTIFICATION LABEL
NOT TO SCALE

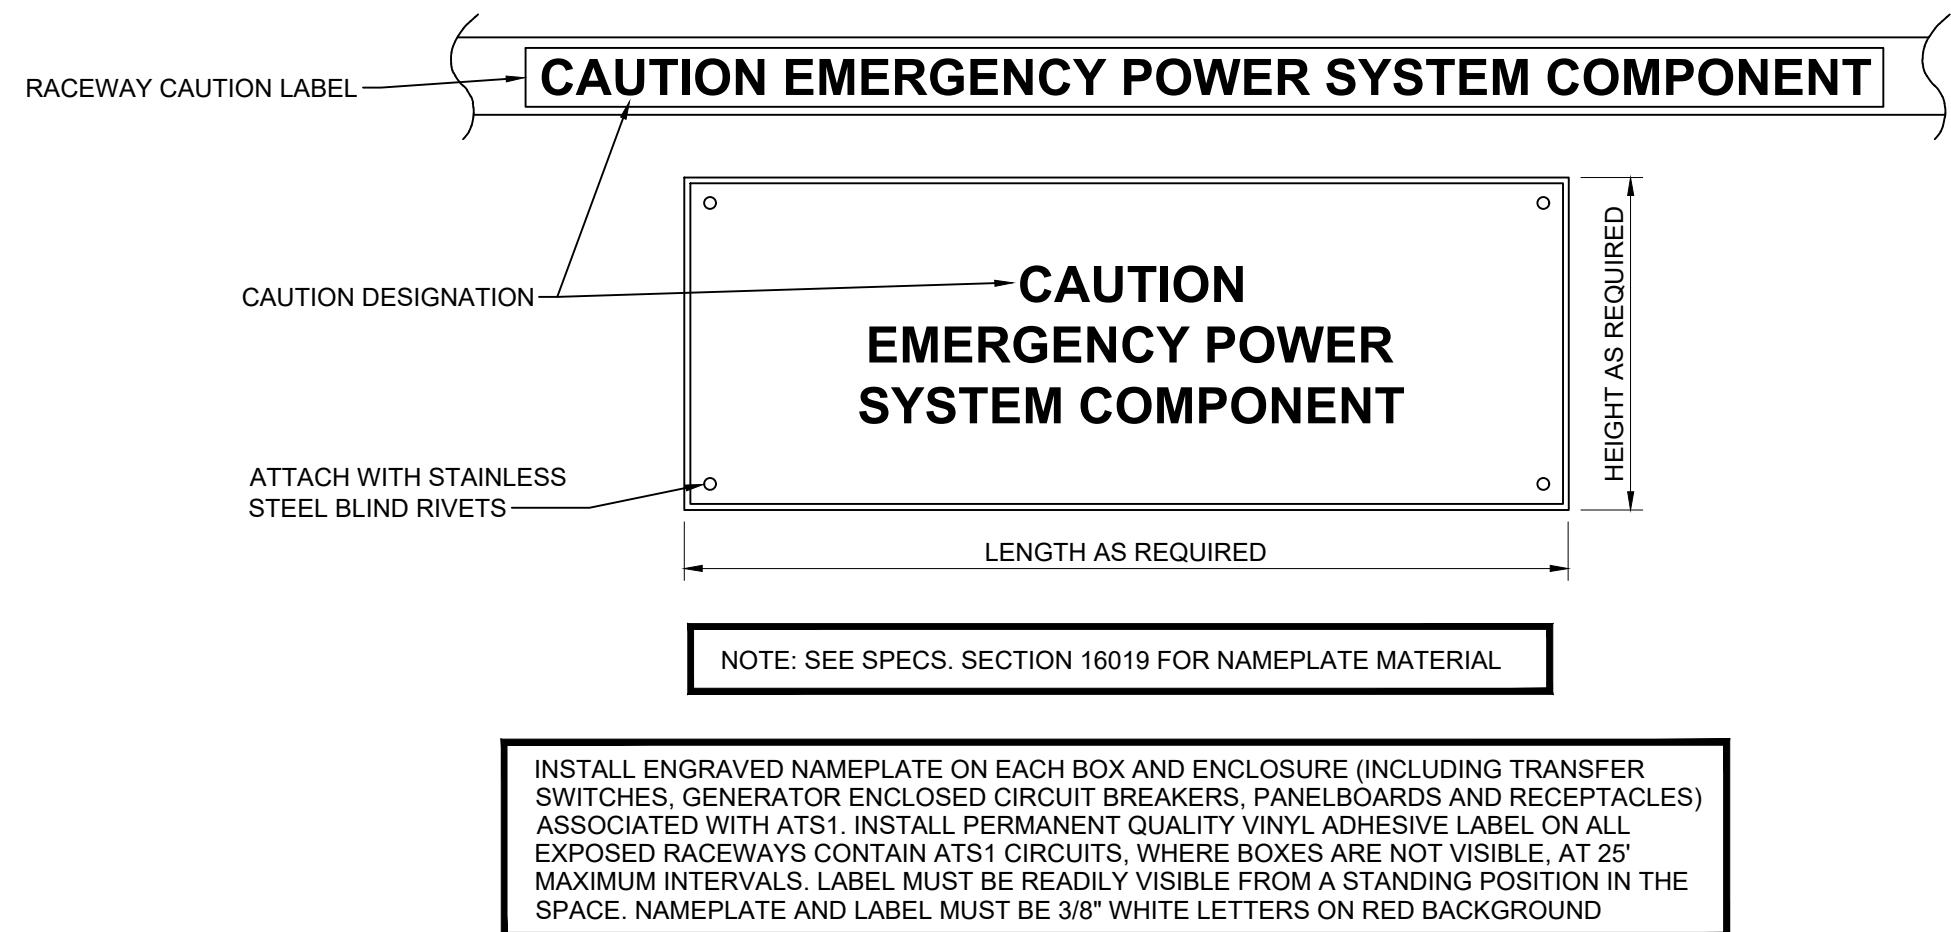


9 EMERGENCY POWER SYSTEM COMPONENT AND RACEWAY NAMEPLATE AND LABEL
NOT TO SCALE

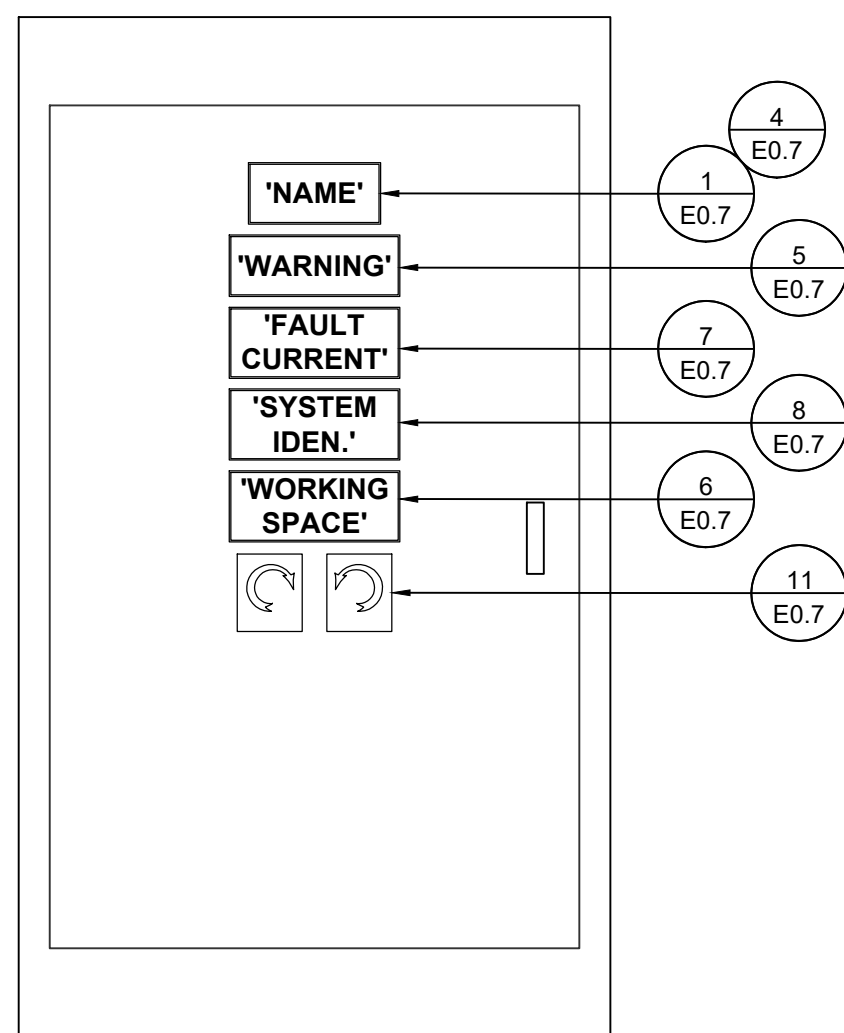


10 REQUIRED SWITCHBOARD & PANELBOARD NAMEPLATE & LABELS DETAIL
NOT TO SCALE

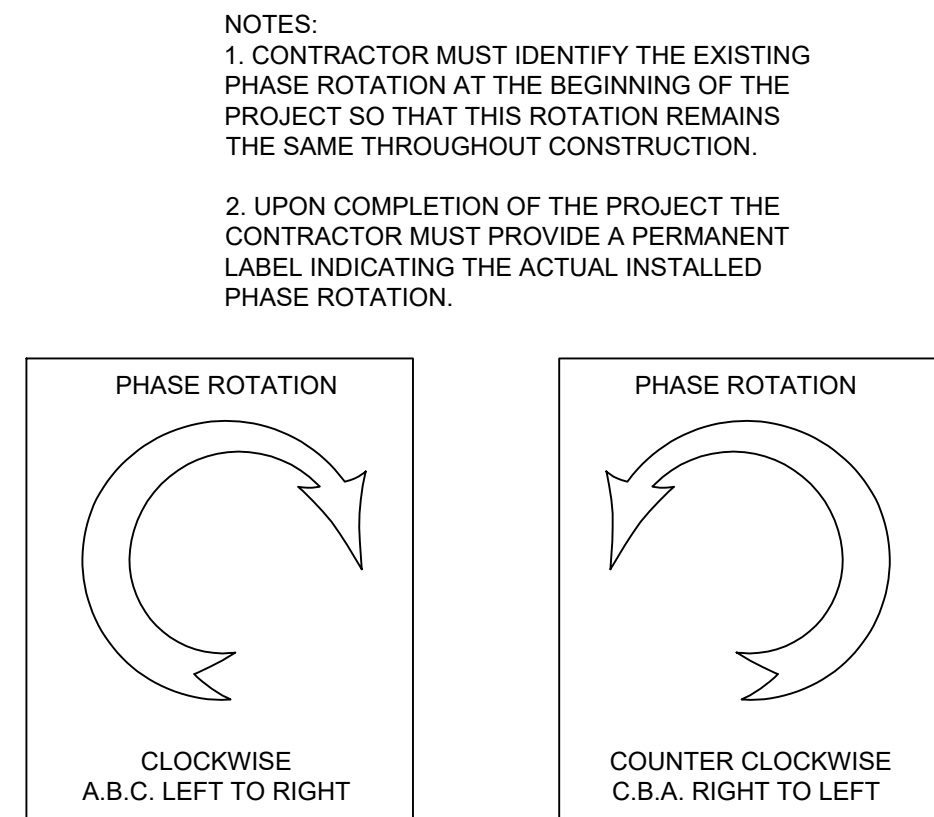


11 PHASE ROTATION LABEL
NOT TO SCALE

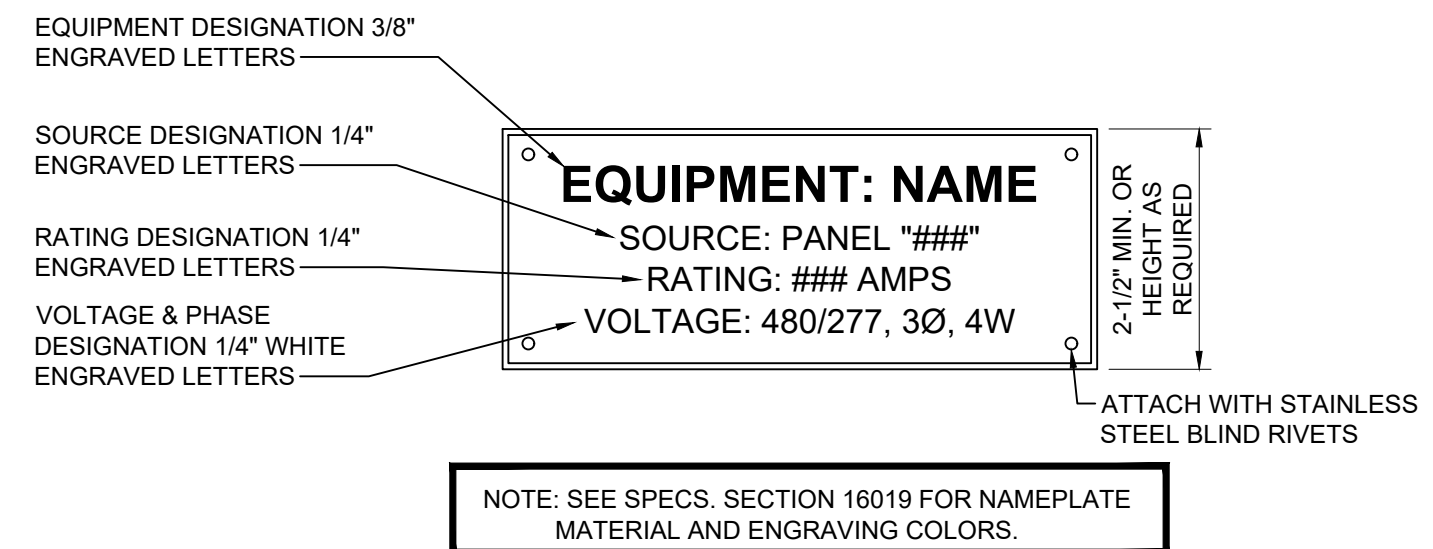


12 TYPICAL EQUIPMENT NAMEPLATE DETAIL
NOT TO SCALE

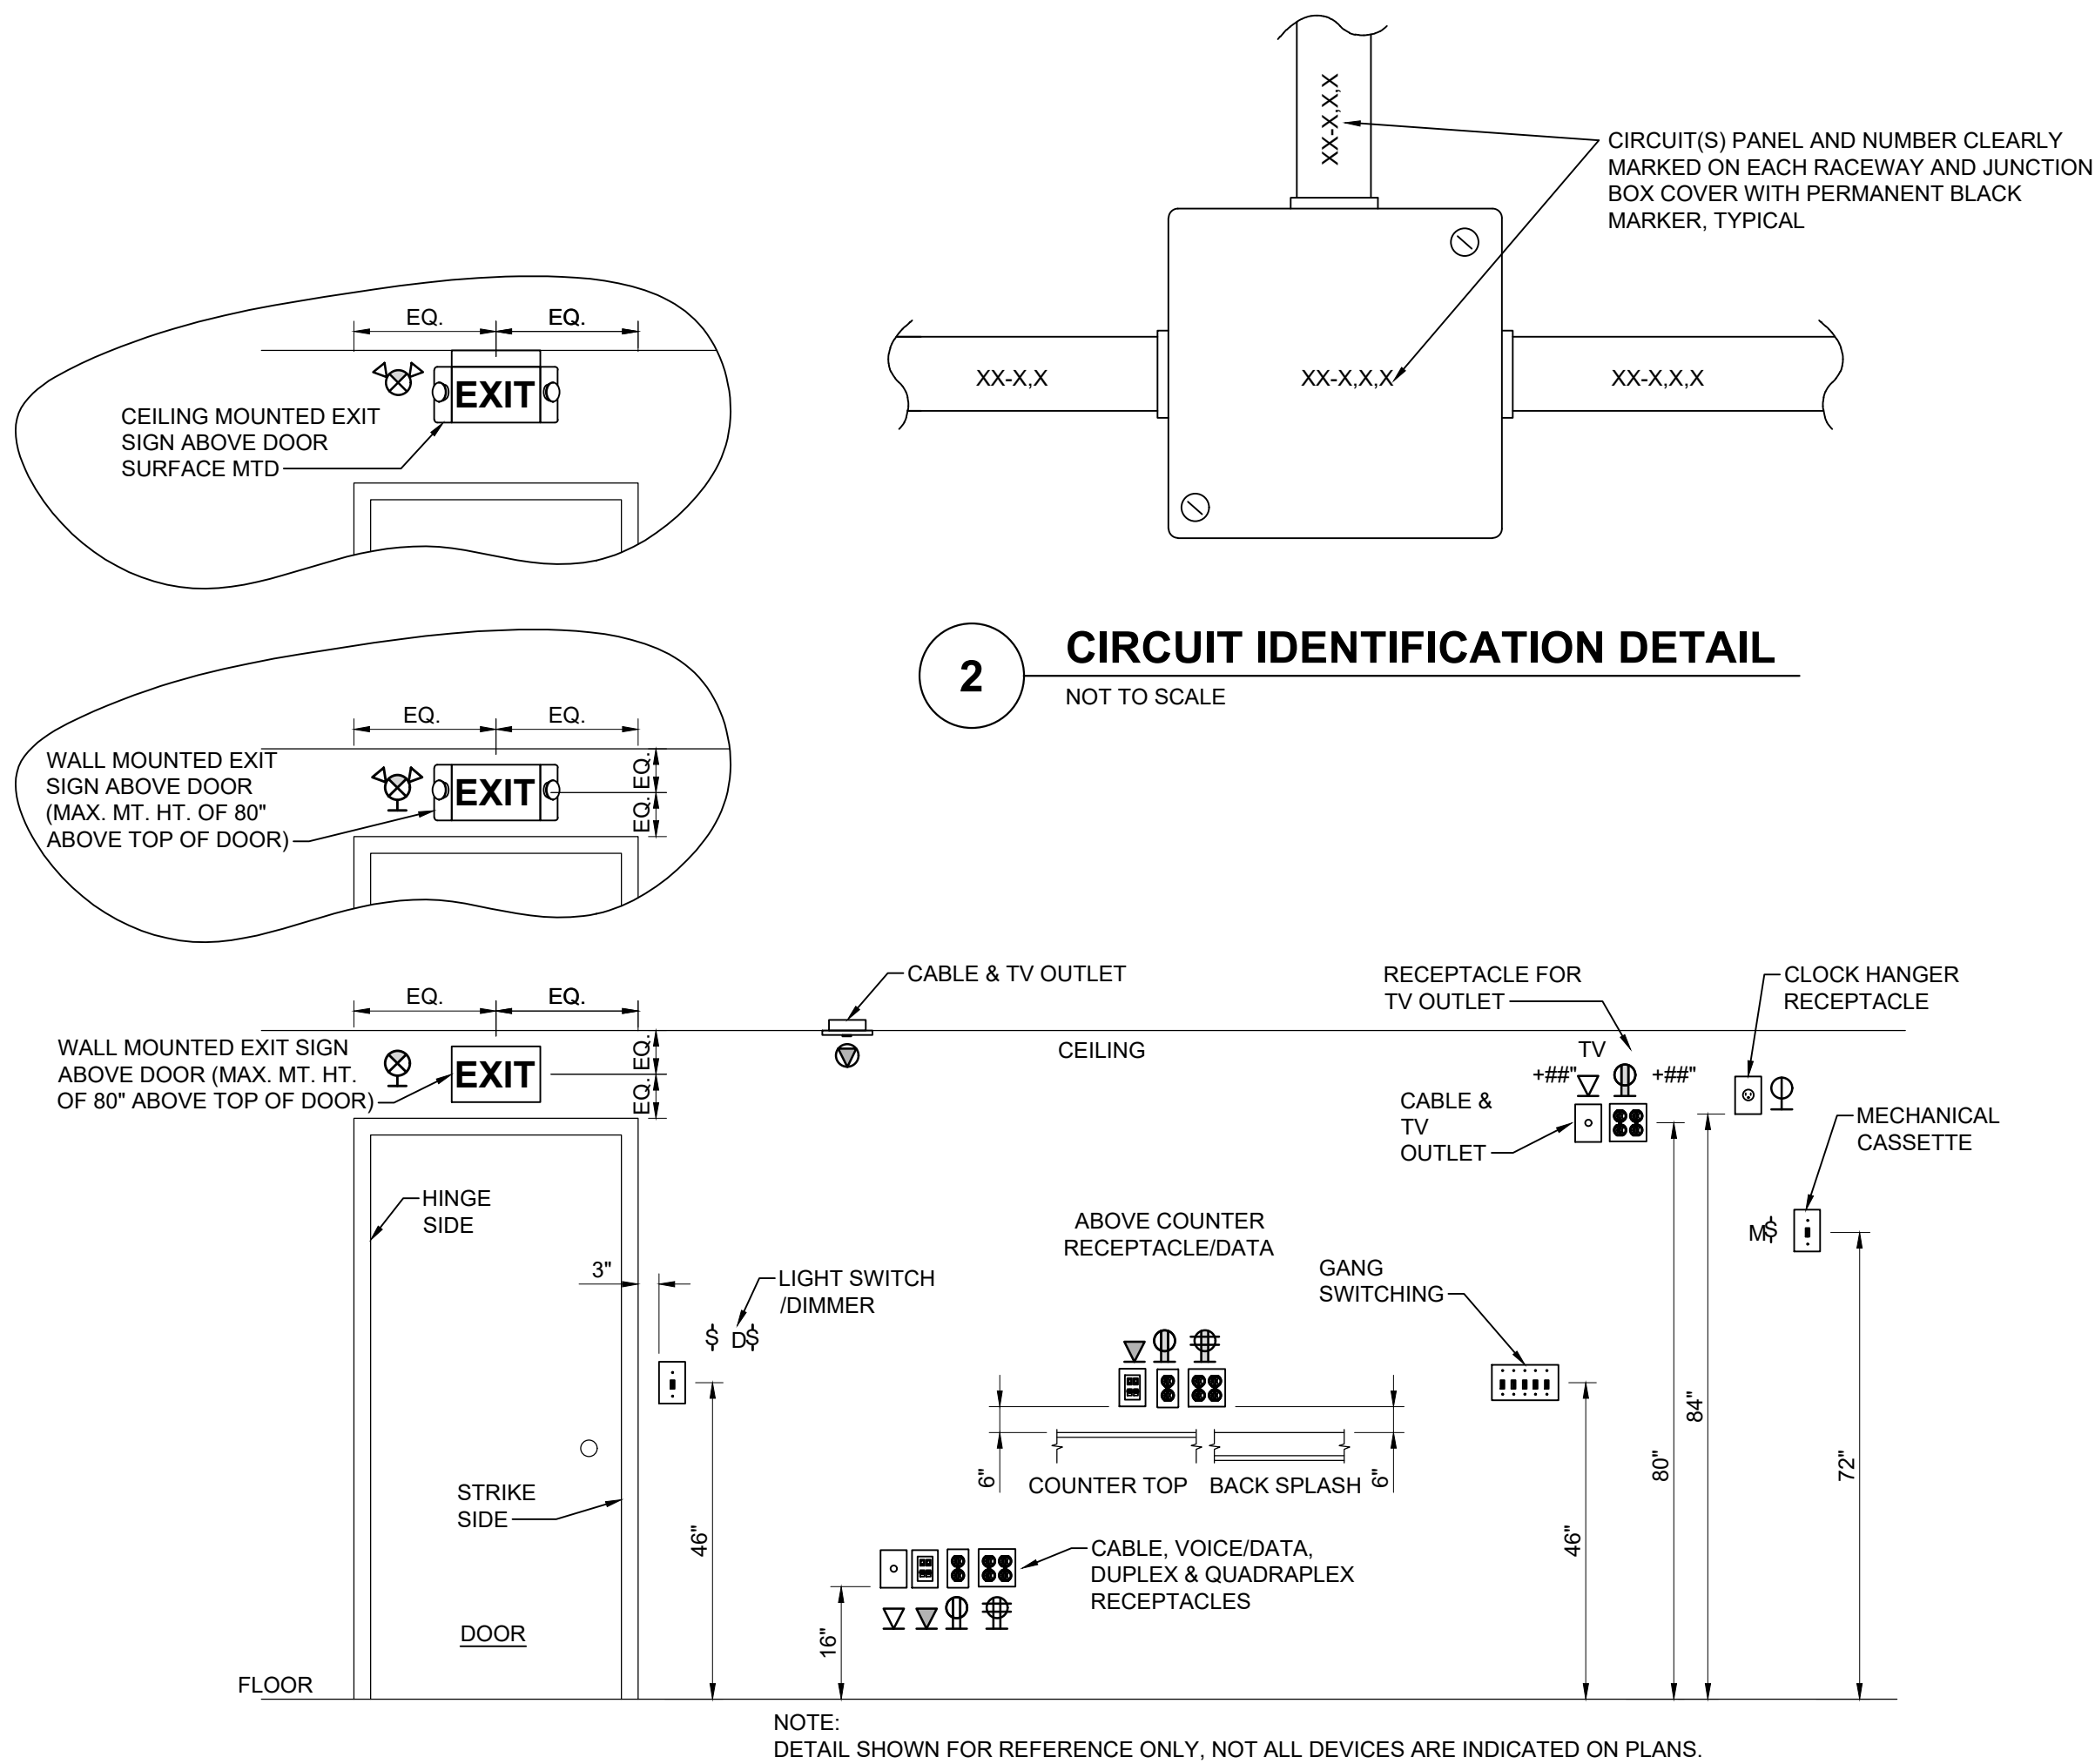

2 CIRCUIT IDENTIFICATION DETAIL
NOT TO SCALE

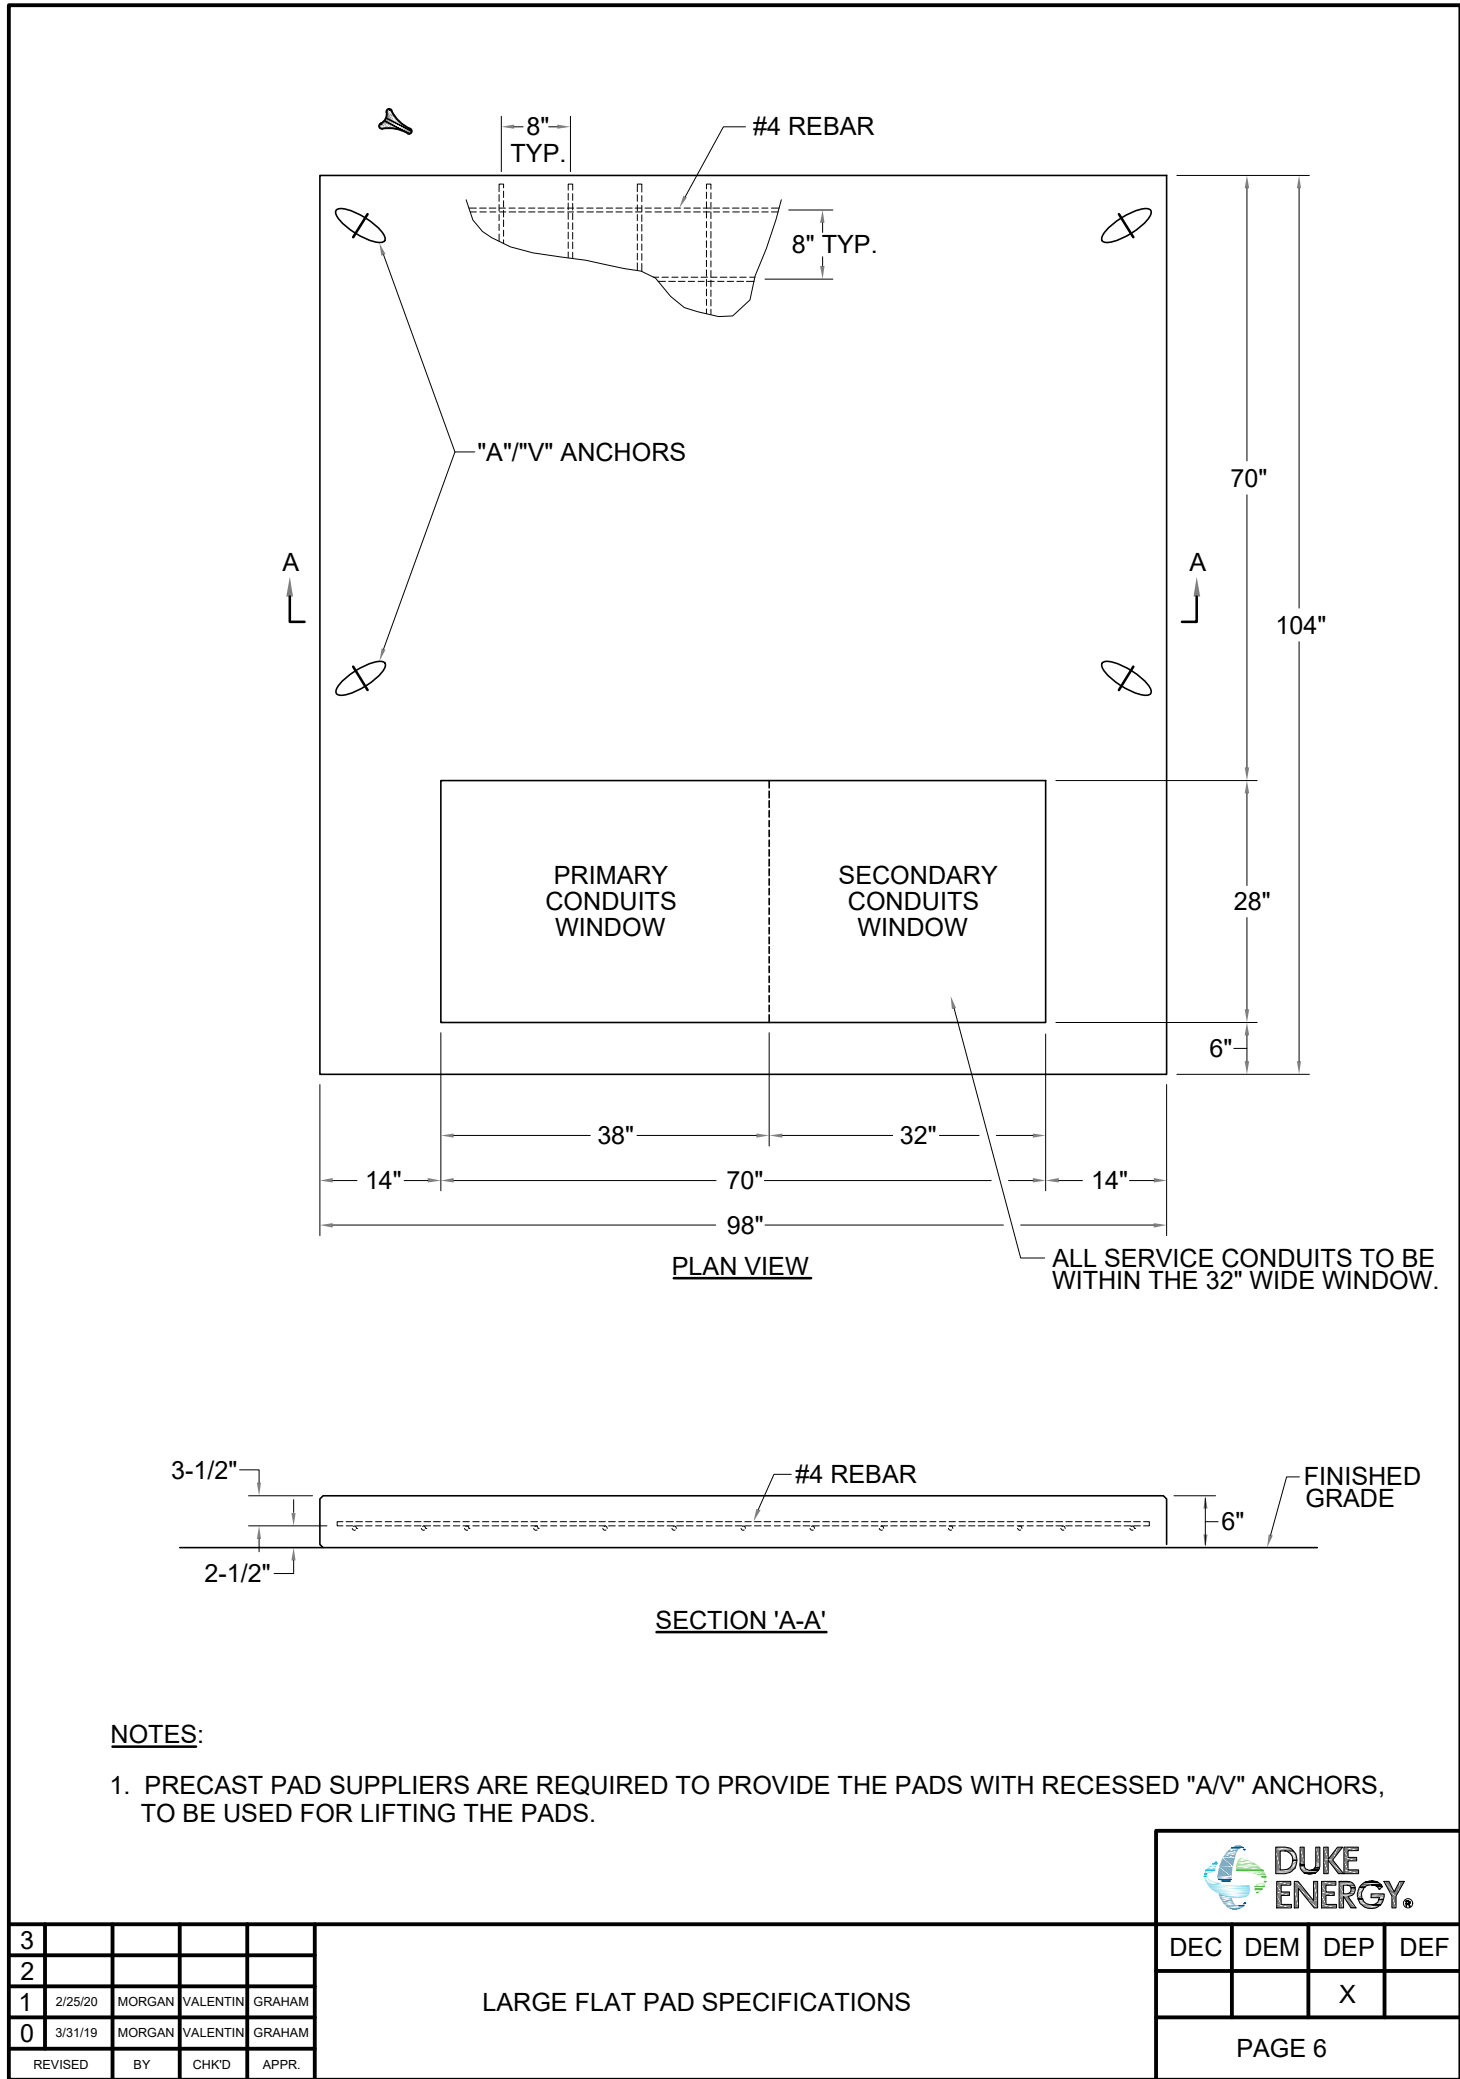

7 DUKE ENERGY LARGE FLAT PAD DETAIL
NOT TO SCALE

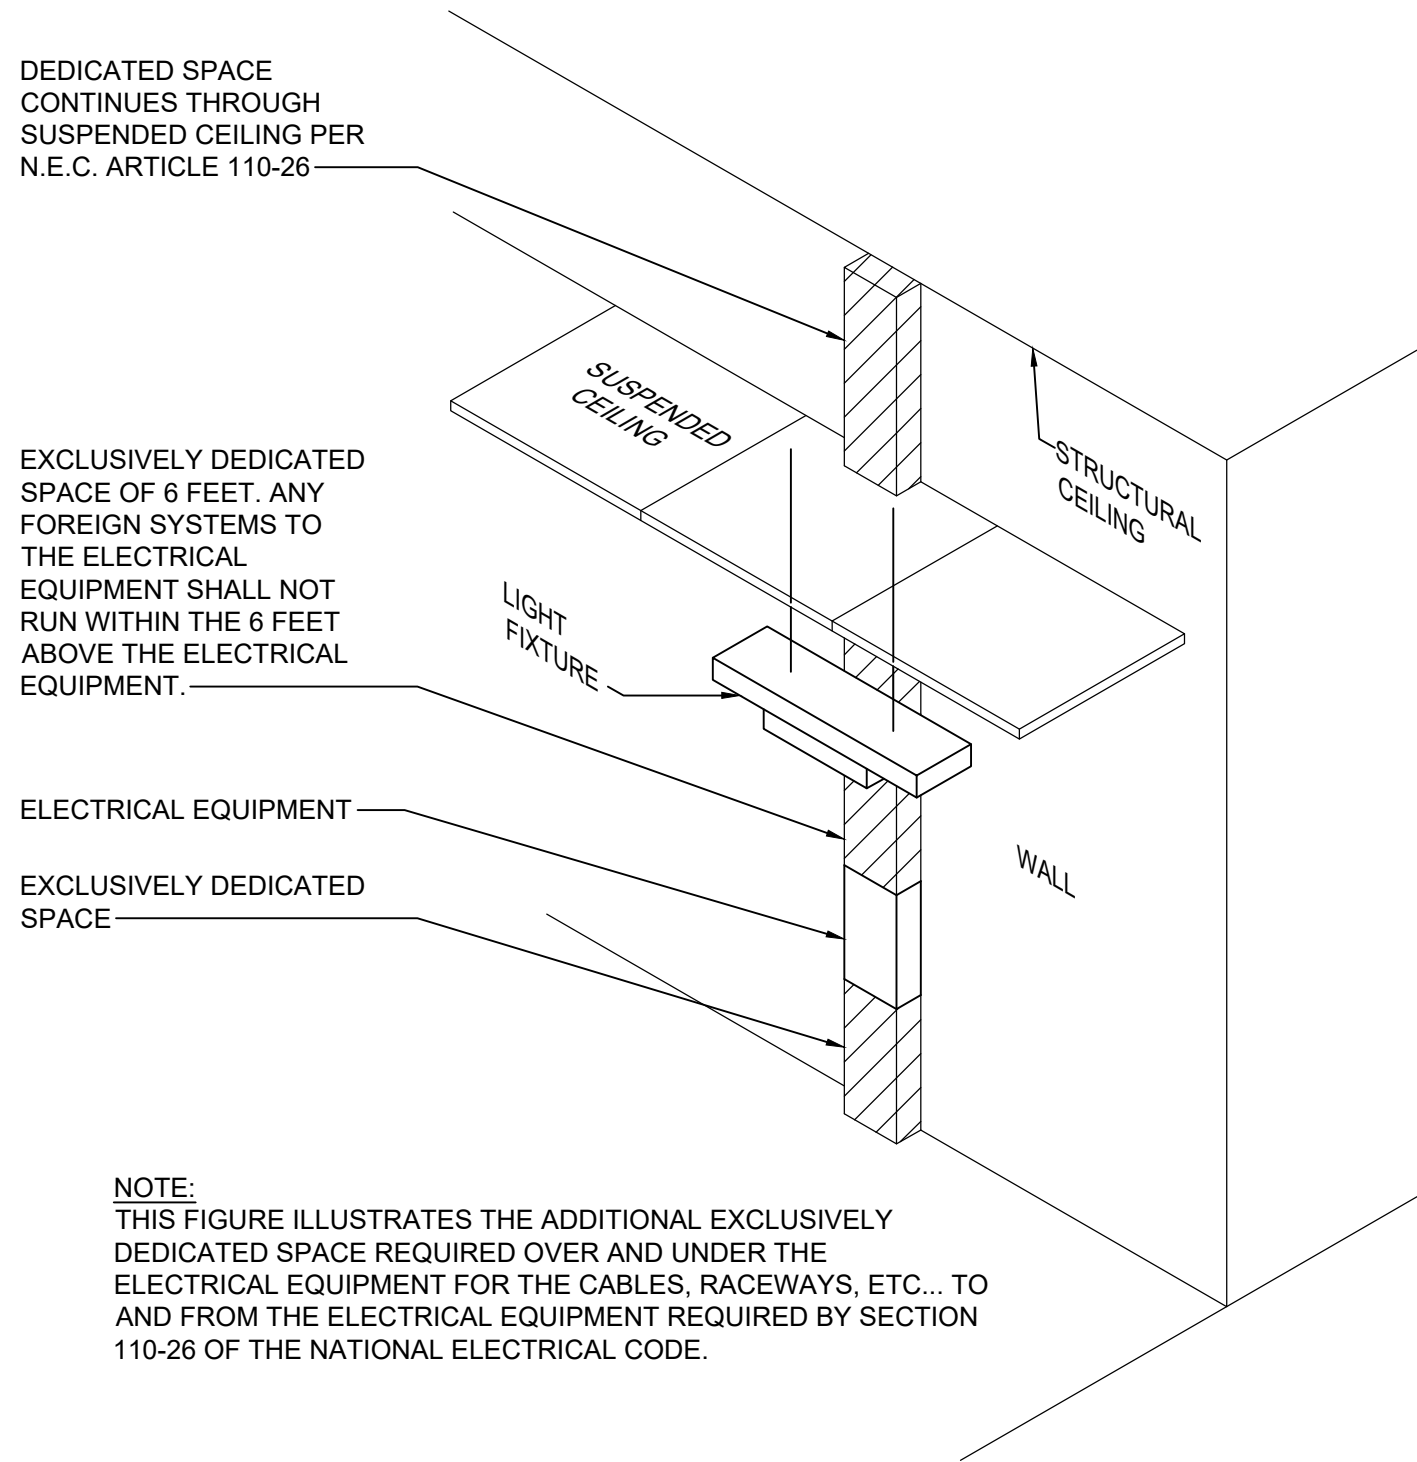

4 DEDICATED SPACE FOR ELECTRICAL
NOT TO SCALE


TABLE 110.26(A)(1) - WORKING SPACES			
NOMINAL VOLTAGE TO GROUND	MINIMUM CLEAR DISTANCE (FEET)		
	CONDITION 1	CONDITION 2	CONDITION 3
0 - 150	900mm (3 ft)	900mm (3 ft)	900mm (3 ft)
151 - 600	900mm (3 ft)	1.0m (3 ft 6 in.)	1.2 m (4 ft.)
601 - 1000	900mm (3 ft)	1.2 m (4 ft.)	1.5 m (5 ft.)

NOTE: WHERE THE "CONDITIONS" ARE AS FOLLOWS:


CONDITION 1 - EXPOSED LIVE PARTS ON ONE SIDE OF WORKING SPACE AND NO LIVE OR GROUNDED PARTS ON THE OTHER SIDE OF THE WORKING SPACE, OR EXPOSED LIVE PARTS ON BOTH SIDES OF THE WORKING SPACE THAT ARE EFFECTIVELY GUARDED BY INSULATING MATERIALS.

CONDITION 2 - EXPOSED LIVE PARTS ON ONE SIDE OF THE WORKING SPACE AND GROUNDED PARTS ON THE OTHER SIDE OF WORKING SPACE. CONCRETE BRICK, OR TILE WALLS SHALL BE CONSIDERED GROUNDED.


CONDITION 3 - EXPOSED LIVE PARTS ON BOTH SIDES OF THE WORK SPACE

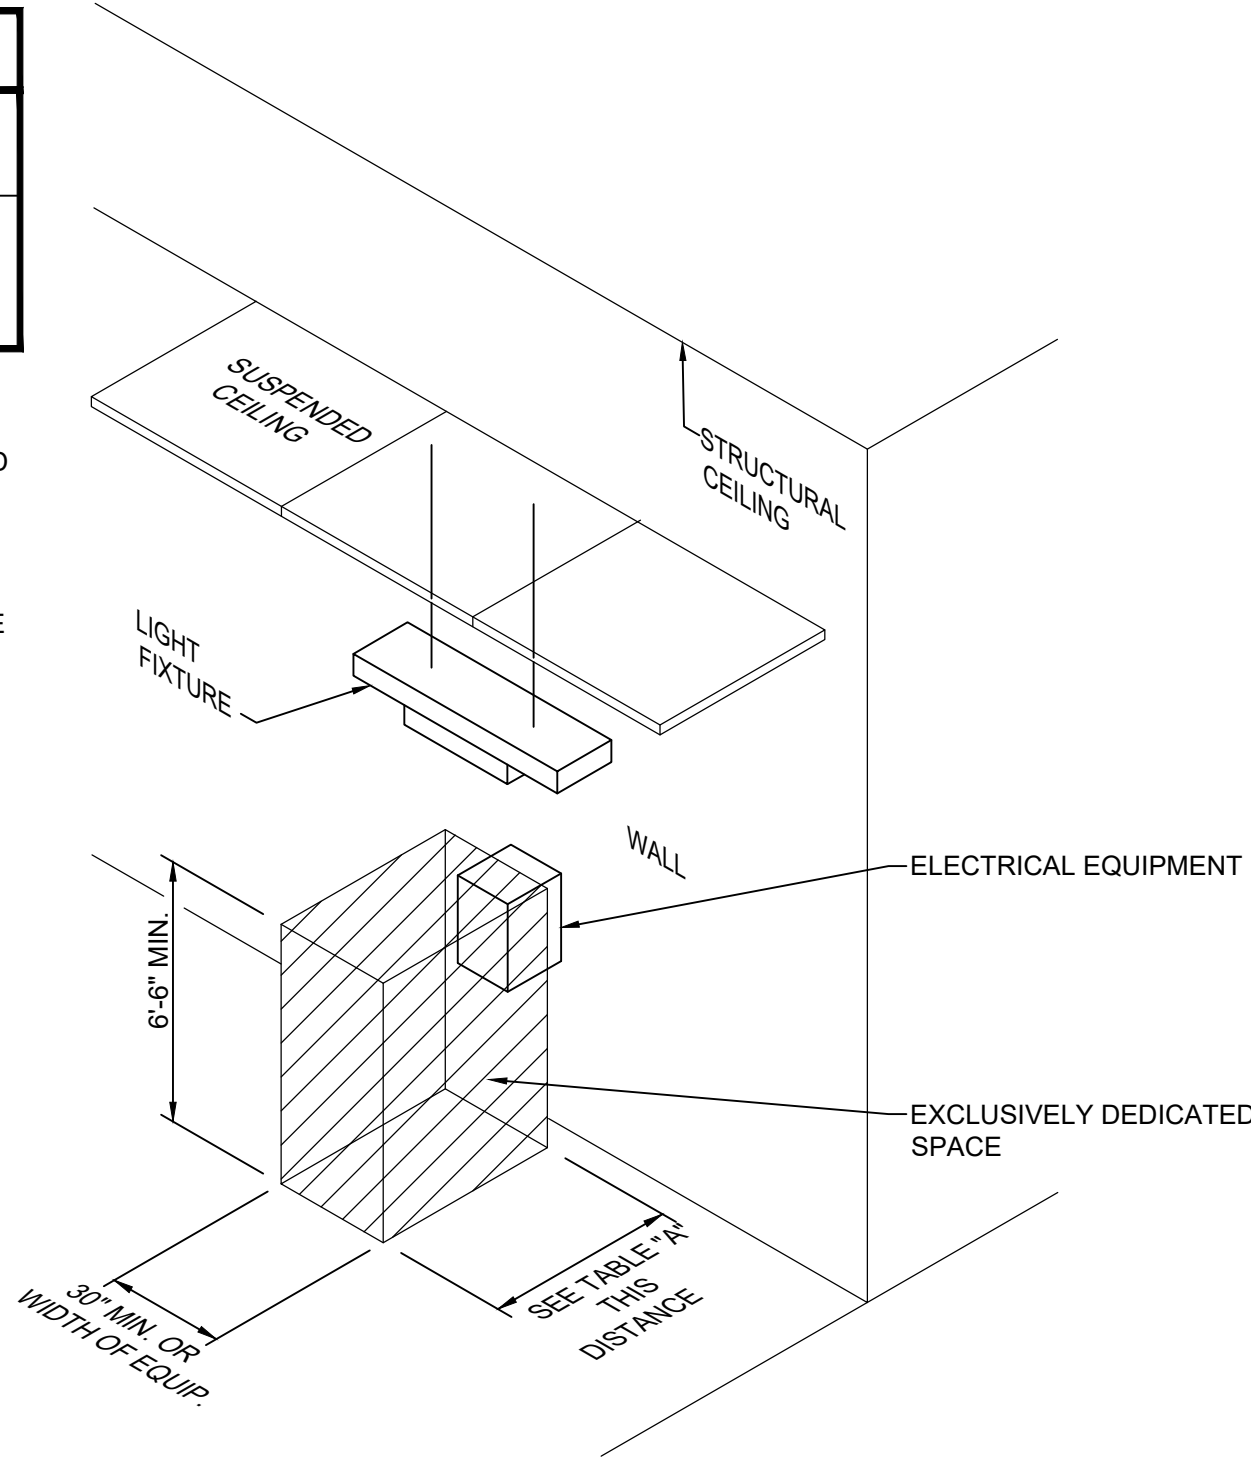

5 WORKING CLEARANCE FOR ELECTRICAL
NOT TO SCALE

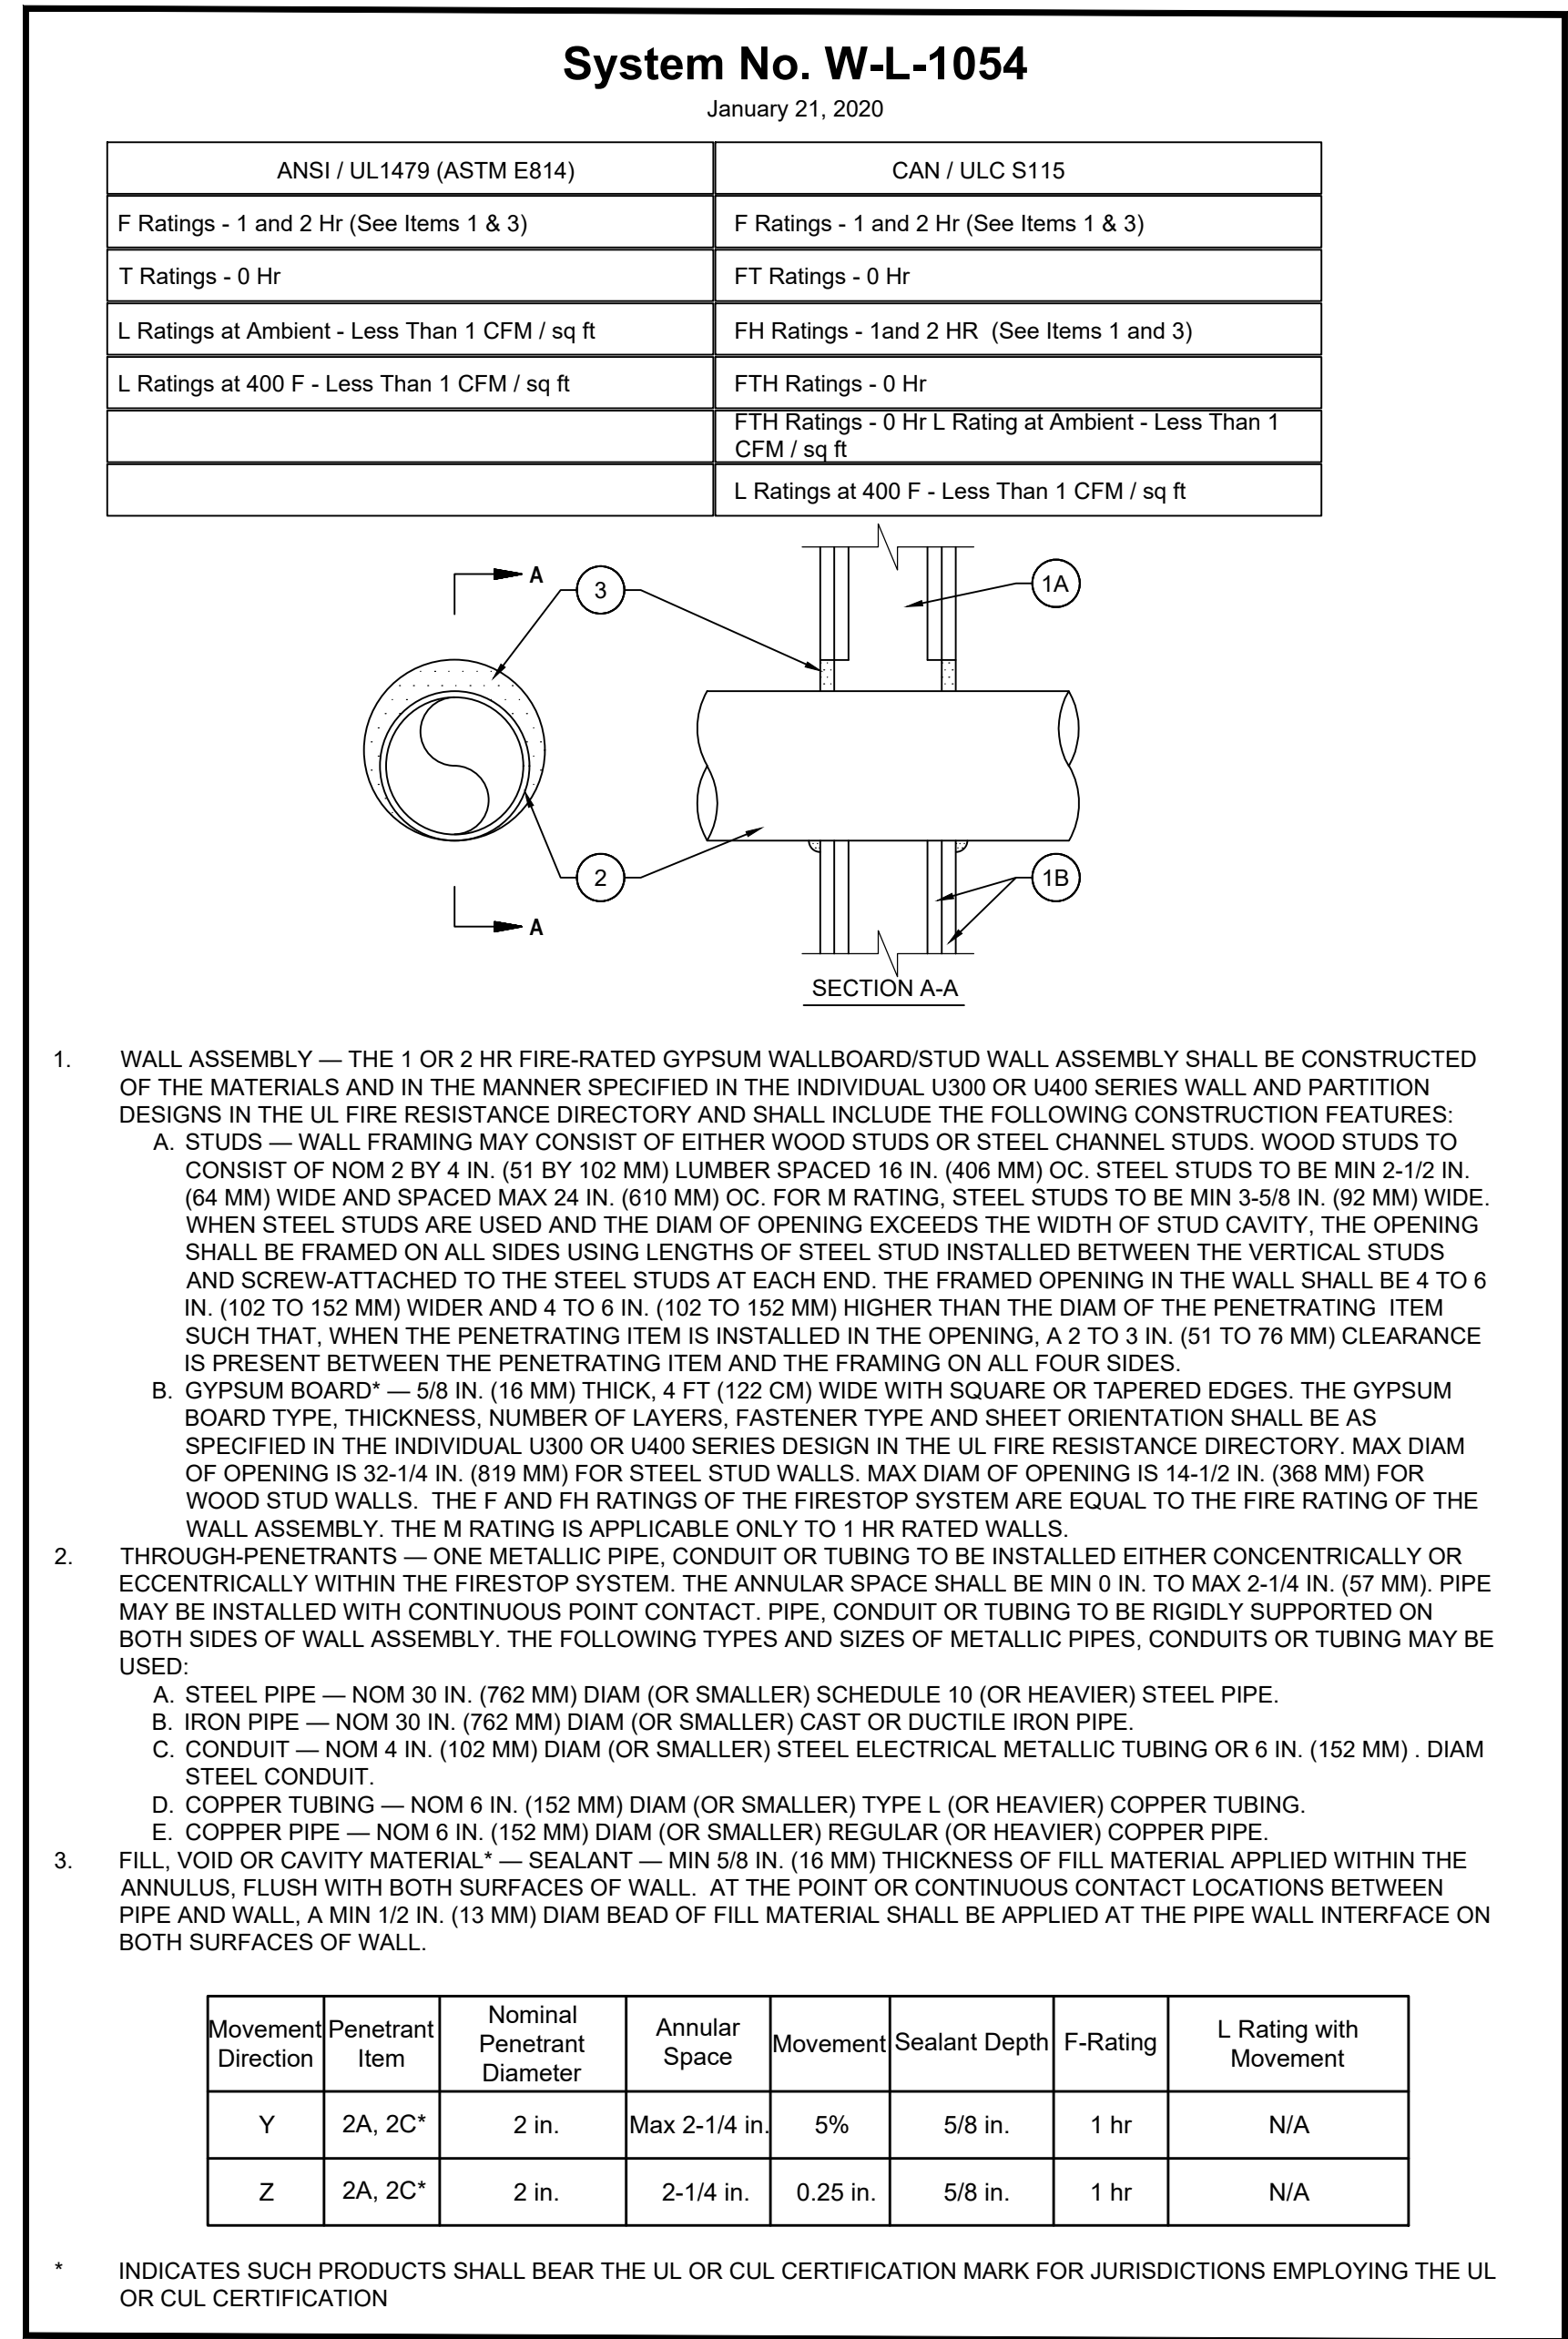

6 1 AND 2 HOUR FIREWALL PENETRATION DETAIL
NOT TO SCALE

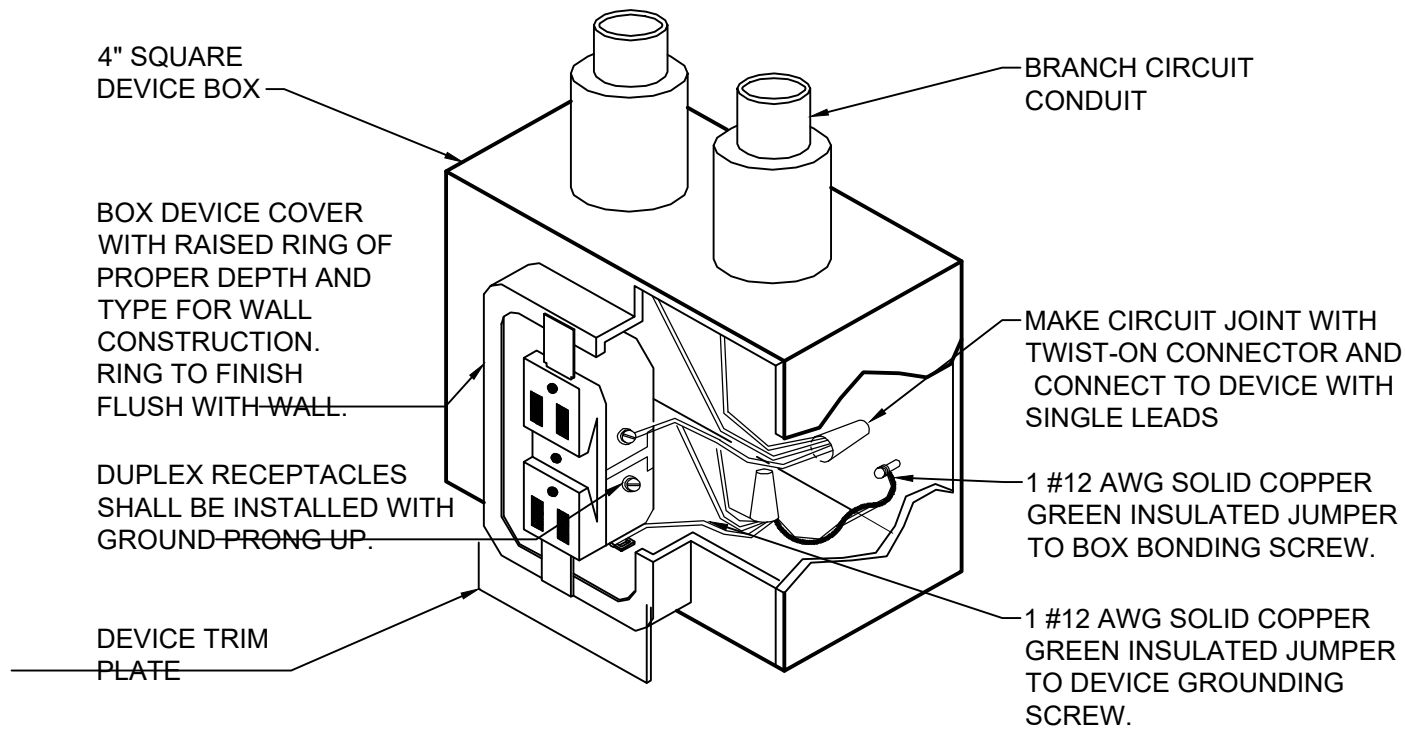

3 RECEPTACLE GROUNDING DETAIL
NOT TO SCALE



NOTE: ARRANGE PANELBOARD BRANCH CIRCUIT BREAKERS AS SHOWN ON THE BELOW SCHEDULES. AGREEMENT OF CIRCUIT BREAKER (POLE) NUMBERS WITH THE PANEL SCHEDULES AND ELECTRICAL FLOOR PLANS IS REQUIRED IN ORDER TO AVOID CONFUSION DURING CONSTRUCTION. REDRAWING THE CIRCUITRY FOR RECORD DRAWING PURPOSES AND ACCURATE DOCUMENTATION OF THE AS-BUILT CONDITIONS.

SWITCHBOARD MDS & ESTIMATED DEMAND LOAD SUMMARY													
TYPE:	208	120	VOLTS		3	PHASE		4	WIRE		PROVIDE	XX	EQUIPMENT GROUND BUS
BOLT-ON	MOUNT:	SURFACE								IF		XX	100 % NEUTRAL BUS
HINGED TRIM	FEED:	TOP								CHECKED		XX	ULSE LABEL
												ISOLATED GROUND BAR	
ENCLOSURE													
LOAD SERVED		LOAD	OKT	BKR	OKT	LOAD VA			OKT	BKR	LOAD	LOAD SERVED	
		VA	TRIP/POLES	#	A	B	C	#	TRIP/POLES				
PANEL NA		50,990	500/3		54,978	52,141		2	60/3		4,388	PANEL NL	
		49,146		1							3,095		
		51,479					57,255				5,776		
PANEL NB		41,517	400/3		68,882			4	225/3		27,365	PANEL NK	
		43,879		3		72,540					28,681		
		41,299					71,838				30,629		
PANEL NC		53,925	800/3		56,837			6	60/3		2,912	PANEL NG	
		50,274		5		52,264					1,990		
		49,727					52,767				3,040		
PANEL ND		50,145	500/3		51,933			8	60/3		1,788	PANEL NS	
		47,870		7		49,945					2,075		
		46,206					49,314				3,108		
PANEL LS VIA LIFE SAFETY BRANCH ATS-1		4,780	100/3		71,340				400/3		66,560	FUTURE PANEL NG2	
		4,357		9		64,261		10			59,904		
		3,191									59,904		
PANEL C VIA CRITICAL BRANCH ATS-2		28,245	300/3		28,245				225/3			PREPARED SPACE	
		34,622		11		34,622		12					
		33,877					33,877						
SWITCHBOARD EH VIA EQUIPMENT ATS-3		161,257	1600/3		161,257				225/3			PREPARED SPACE	
(100% RATED BREAKER)		154,749		13		154,749		14					
		157,978					157,978						
NOTES (AS APPLICABLE):					493,472	480,522	486,122	TTL PHASE VA		4,000	A. BUS (COPPER UNO)		
1. COORDINATE CIRCUIT BREAKER TRIP WITH EQUIPMENT.					4,112	4,004	4,051	TTL PHASE AMPS		4,000	A. MAIN CIRCUIT BREAKER		
2. COORDINATE SPD CIRCUIT BREAKER TRIP WITH SPD PROVIDED.					33%	33%	33%	PHASE BALANCE			(100% RATED MAIN CIRCUIT BREAKER)		
										100	KA/MINIMUM RATING		
ADDITIONAL NOTES (AS APPLICABLE):													
4. SWBD EH CB SHALL BE 100% RATED & PROVIDED WITH AN ARC ENERGY REDUCTION MAINTENANCE SWITCH PER NEC ART. 240.87.													
5. THE MCB SHALL BE 100% RATED & PROVIDED WITH AN ARC ENERGY REDUCTION MAINTENANCE SWITCH PER NEC ART. 240.87.													
6. KITCHEN EQUIPMENT DEMAND FACTOR PER NEC TABLE 220.56.													
7. SEE SPECIFICATIONS SECTION 16032 AND SWITCHBOARD ELEVATION 7/6.0 FOR ADDITIONAL DETAILS AND REQUIREMENTS.													
DEMAND SUMMARY:													
R: TOTAL RECEPTACLES (VA) =	478,377	10,000	1.0	10,000									
RECEPTACLES FIRST 10 KVA		468,377	0.5	234,189									
RECEPTACLES > 10 KVA		57,520	1.25	71,900									
L: LIGHTING		52,758	1.00	52,758									
M: MISCELLANEOUS EQUIPMENT		28,558	1.25	35,197									
O: OTHER EQUIPMENT (CONTINUOUS)		40,697	1.25	50,871									
B: LARGEST MOTOR		709,812	1.00	709,812									
H: HVAC EQUIPMENT (FLA = MCA X 0.8)		94,395	0.65	61,357									
K: KITCHEN EQUIPMENT													
TOTAL CONNECTED (VA)				1,460,117									
TOTAL DEMAND (VA)				1,224,083									
TOTAL DEMAND (AMPERES)				3,398									
PANEL DEMAND LOADING VS RATING				84.9%									

SWITCHBOARD EH																													
TYPE:	208	120	VOLTS	3	PHASE	4	WIRE	PROVIDE	XX	EQUIPMENT GROUND BUS																			
BOLT-ON	MOUNT:	SURFACE			IF	XX	100	% NEUTRAL BUS																					
HINGED TRIM	FEED:	TOP			CHECKED	XX	ULSE LABEL																						
ISOLATED GROUND BAR																													
ENCLOSURE																													
LOAD VA																													
LOAD SERVED	LOAD	OKT BKR	OKT	PHASE	LOAD	OKT BKR	LOAD	LOAD SERVED																					
PANEL EHA	31,787	400/3	64,984	60,200	61,989	2	400/3	33,197	PANEL EHB																				
SPARE	29,583	1	60,200	61,989	61,989	2	400/3	33,197	PANEL EHB																				
PANEL EHC	26,454	300/3	53,054	54,240	54,240	4	300/3	26,600	PANEL EHD																				
SPARE	26,600	3	53,054	54,240	54,240	4	300/3	26,600	PANEL EHD																				
PANEL EHG	29,554	60/3	27,929	28,183	28,183	6	225/3	28,847	PANEL EHK																				
SPARE	807	5	27,929	28,183	28,183	6	225/3	28,847	PANEL EHK																				
SPD	30/3	7	13,566	13,566	13,566	8	150/3	13,566	DOAS01																				
SPARE	30/3	7	13,566	13,566	13,566	8	150/3	13,566	DOAS01																				
PREPARED SPACE	225/3	9	13,566	13,566	13,566	8	225/3	13,566	PREPARED SPACE																				
SPARE	225/3	9	13,566	13,566	13,566	8	225/3	13,566	PREPARED SPACE																				
PREPARED SPACE	100/3	11	13,566	13,566	13,566	12	100/3	13,566	PREPARED SPACE																				
SPARE	100/3	11	13,566	13,566	13,566	12	100/3	13,566	PREPARED SPACE																				
NOTES (AS APPLICABLE):																													
1. COORDINATE CIRCUIT BREAKER TRIP WITH EQUIPMENT.																													
2. COORDINATE SPD CIRCUIT BREAKER TRIP WITH SPD PROVIDED.																													
DEMAND SUMMARY:																													
R: TOTAL RECEPTACLES (VA) = 360																													
RECEPTACLES FIRST 10 KVA 360 1.0 360																													
RECEPTACLES > 10 KVA 0 0.5 0																													
L: LIGHTING 1,25 1.25 1,250																													
M: MISCELLANEOUS EQUIPMENT 12,240 1.00 12,240																													
O: OTHER EQUIPMENT (CONTINUOUS) 17,646 1.25 22,057																													
B: LARGEST MOTOR 40,697 1.25 50,871																													
H: HVAC EQUIPMENT (FLA = MCA X 0.8) 399,729 1.00 399,729																													
K: KITCHEN EQUIPMENT 3,312 1.00 3,312																													
TOTAL CONNECTED (VA) 473,984																													
TOTAL DEMAND (VA) 488,569																													
TOTAL DEMAND (AMPERES) 1,356																													
PANEL DEMAND LOADING VS RATING 84.8%																													

PANEL C																													
TYPE:	208	120	VOLTS	3	PHASE	4	WIRE	PROVIDE	XX	EQUIPMENT GROUND BUS																			
BOLT-ON	MOUNT:	SURFACE			IF	XX	100	% NEUTRAL BUS																					
HINGED TRIM	FEED:	TOP			CHECKED	XX	ULSE LABEL																						
ISOLATED GROUND BAR																													
ENCLOSURE																													
LOAD VA																													
LOAD SERVED	LOAD	OKT BKR	OKT	PHASE LOAD VA			OKT	OKT BKR	LOAD	LOAD SERVED																			
	VA	TRIP/POLES	#	A	B	C	#	TRIP/POLES	VA																				
PANEL CA	6.630	100/3	1	14,210			2	100/3	7,580	PANEL CB																			
	6,270		3		18,252		4		9,982																				
	6,384		5			17,144	5		10,700																				
PANEL CC	6.990	100/3	7	14,035			8	100/3	7,045	PANEL CD																			
	7,710		9		15,672		10		7,962																				
	7,716		11			15,695	12		7,979																				
SPARE		100/3	13				14	30/3		SPD																			
			15				16																						
			17				18																						
SPARE		100/3	19				20	100/3		SPARE																			
			21				22																						
			23				24																						
SPARE		20/1	25				26	70/3		SPACE																			
LIGHTING: KITCHEN 43	698	20/1	27		698		28																						
LIGHTING: LAUNDRY & MECH/ELEC EQUIP	1,038	20/1	29			1,038	30																						
NOTES (AS APPLICABLE):				28,245				34,622	33,877	TTL PHASE VA		400	A. BUS (COPPER, UNO)																
1. COORDINATE CIRCUIT BREAKER TRIP WITH EQUIPMENT				235				289	282	TTL PHASE AMPS		300	A. MAIN LUGS AND/OR FEEDER RATING																
2. COORDINATE SPD CIRCUIT BREAKER TRIP WITH SPD PROVIDED.				225				36%	35%	PHASE BALANCE		85	KAIC MINIMUM RATING																
DEMAND SUMMARY:				COAIN.		DEMAND																							
				(VA)		(VA)																							
TOTAL RECEPTACLES (VA) =				60,680																									
RECEPTACLES FIRST 10 KVA				10,000		1,000																							
RECEPTACLES > 10 KVA				50,680		0.50																							
LIGHTING				20,288		1.25																							
MISCELLANEOUS EQUIPMENT				15,776		1.00																							
OTHER EQUIPMENT (CONTINUOUS)						1.25																							
LARGEST MOTOR						1.25																							
HVAC EQUIPMENT (FLA = MCA X 0.8)						1.00																							
KITCHEN EQUIPMENT						1.00																							
TOTAL CONNECTED (VA)				96,744																									
TOTAL DEMAND (VA)						76,476																							
TOTAL DEMAND (AMPERES)						212.3																							
PANEL DEMAND LOADING VS RATING				70.8%																									



PRELIMINARY
PRICING ONLY -
NOT FOR
CONSTRUCTION

NOTES (AS APPLICABLE):				10,082	9,715	10,757	TTL PHASE VA	100 A	BUS (COPPER, UNO)
1. COORDINATE CIRCUIT BREAKER TRIP WITH EQUIPMENT.				64	91	90	TTL PHASE AMPS	100 A	MAIN LUGS AND/OR FEEDER RATING
				33%	32%	35%	PHASE BALANCE	25	KVAC MINIMUM RATING
DEMAND SUMMARY:				CONA	DEMAND FACTOR	DEMAND (VA)	ADDITIONAL NOTES (AS APPLICABLE):		
TOTAL RECEPTACLES (VA) =				26,480			2. PROVIDE ARC FAULT CIRCUIT BREAKERS FOR ALL 120V, 15A & 20A PATIENT ROOM BRANCH CIRCUITS SUPPLYING OUTLETS AND DEVICES.		
RECEPTACLES FIRST 16 KVA				10,000	1.00	10,000			
RECEPTACLES > 16 KVA				10,480	0.50	5,240			
LIGHTING				4,074	1.25	5,093			
MISCELLANEOUS EQUIPMENT					1.00				
OTHER EQUIPMENT (CONTINUOUS)					1.25				
LARGEST MOTOR					1.25				
HVAC EQUIPMENT (FLA = MCA X 0.8)					1.00				
KITCHEN EQUIPMENT					1.00				
TOTAL CONNECTED (VA)				30,554					
TOTAL DEMAND (VA)						23,333			
TOTAL DEMAND (AMPERES)						64.8			
PANEL DEMAND LOADING VS RATING				64.8%					

NOTES (AS APPLICABLE):				10,115	9,715	10,724	TTL PHASE VA	100 A. BUS (COPPER, UNO)
1. COORDINATE CIRCUIT BREAKER TRIP WITH EQUIPMENT.				84	81	89	TTL PHASE AMPS	100 A. MAIN LUGS AND/OR FEEDER RATING
				33%	32%	33%	PHASE BALANCE	2% KICA MINIMUM RATING
DEMAND SUMMARY:				CONA	DEMAND	DEMAND	ADDITIONAL NOTES (AS APPLICABLE):	
				(VA)	FACTOR	(VA)	2. PROVIDE ARC FAULTY CIRCUIT BREAKERS FOR ALL 120V, 15A & 20A PATIENT ROOM BRANCH CIRCUITS SUPPLYING OUTLETS AND DEVICES.	
TOTAL RECEPTACLES (VA) =				26,480				
RECEPTACLES FIRST 10 KVA				10,000	1.00	10,000		
RECEPTACLES >10 KVA				16,480	0.50	8,240		
LIGHTING				4,074	1.25	5,093		
MISCELLANEOUS EQUIPMENT								
OTHER EQUIPMENT (CONTINUOUS)					1.25			
LARGEST MOTOR					1.25			
HVAC EQUIPMENT (FLA = MCA X 0.8)					1.00			
KITCHEN EQUIPMENT					1.00			
TOTAL CONNECTED (VA)				30,554				
TOTAL DEMAND (VA)						23,333		
TOTAL DEMAND (AMPERES)						64.8		
PANEL DEMAND LOADING (VS.RATING)				64.8%				

EO .11

NOTE: ARRANGE PANELBOARD BRANCH CIRCUIT BREAKERS AS SHOWN ON THE BELOW SCHEDULES. AGREEMENT OF CIRCUIT BREAKER (POLE) NUMBERS WITH THE PANEL SCHEDULES AND ELECTRICAL FLOOR PLANS IS REQUIRED IN ORDER TO AVOID CONFUSION DURING CONSTRUCTION. REDRAWING THE CIRCUITRY FOR RECORD DRAWING PURPOSES AND ACCURATE DOCUMENTATION OF THE AS-BUILT CONDITIONS.

TYPE:	208	120	VOLTS	3	PHASE	4	WIRE	PROVIDE	XX	EQUIPMENT GROUND BUS
BOLT-ON	MOUNT:	SURFACE						IF	XX	100 % NEUTRAL BUS
HINGED TRIM	FEED:	TOP						CHECKED	ULSE LABEL	ISOLATED GROUND BAR
	NEMA -	1	ENCLOSURE							
	LOAD	VA	TRIP/POLES	CT	PHASE LOAD VA	CT	CT	LOAD		
	VA	TRIP/POLES	#	A	B	C	#	VA		
LOAD SERVED										
PRIVATE ROOM 301 HEADBOARD RECEPTACLES	360	201	1	720			2	201	360	PRIVATE ROOM 302 HEADBOARD RECEPTACLES
PRIVATE ROOM 301 BED RECEPTACLE	180	201	3		360		4	201	180	PRIVATE ROOM 302 BED RECEPTACLE
PRIVATE ROOM 303 HEADBOARD RECEPTACLES	360	201	5			720	6	201	360	PRIVATE ROOM 304 HEADBOARD RECEPTACLES
PRIVATE ROOM 303 BED RECEPTACLE	180	201	7	360			8	201	180	PRIVATE ROOM 304 BED RECEPTACLE
DOUBLE ROOM 305 HEADBOARD RECEPTACLES	360	201	9		720		10	201	360	DOUBLE ROOM 306 HEADBOARD RECEPTACLES
DOUBLE ROOM 305 BED 1 RECEPTACLE	180	201	11			360	12	201	180	DOUBLE ROOM 306 BED 1 RECEPTACLE
SPARE	180	201	13				14	201		SPARE
DOUBLE ROOM 305 BED 2 RECEPTACLE	180	201	15		360		16	201	180	DOUBLE ROOM 306 BED 2 RECEPTACLE
DOUBLE ROOM 307 HEADBOARD RECEPTACLES	360	201	17			720	18	201	360	DOUBLE ROOM 308 HEADBOARD RECEPTACLES
DOUBLE ROOM 307 BED 1 RECEPTACLE	180	201	19	360			20	201	180	DOUBLE ROOM 308 BED 1 RECEPTACLE
SPARE	180	201	21				22	201		SPARE
DOUBLE ROOM 307 BED 2 RECEPTACLE	180	201	23			360	24	201	180	DOUBLE ROOM 308 BED 2 RECEPTACLE
PRIVATE ROOM 309 HEADBOARD RECEPTACLES	360	201	25	720			26	201	360	PRIVATE ROOM 310 HEADBOARD RECEPTACLES
PRIVATE ROOM 309 BED RECEPTACLE	180	201	27		360		28	201	180	PRIVATE ROOM 310 BED RECEPTACLE
PRIVATE ROOM 311 HEADBOARD RECEPTACLES	360	201	29			720	30	201	360	PRIVATE ROOM 312 HEADBOARD RECEPTACLES
PRIVATE ROOM 311 BED RECEPTACLE	180	201	31	360			32	201	180	PRIVATE ROOM 312 BED RECEPTACLE
LIGHTING: 31-34, 24-28, 36	1,736	201	33		2,360		34	201	624	BEDROOM LIGHTING: 301-306
RCPS: MED PREP 28	720	201	35			1,344	36	201	624	BEDROOM LIGHTING: 307-312
NURSE CALL: IT 24	200	201	37	870			38	201	670	BEDROOM LIGHTING: 401-405
NURSE CALL: IT 24	200	201	39		870		40	201	670	BEDROOM LIGHTING: 406-410
SPARE	201	41					42	201		SPARE
IT EQUIP 24	360	201	43	360			44	201		SPARE
IT EQUIP 24	360	201	45		360		46	201		SPARE
IT EQUIP 24	360	201	47			360	48	201		SPARE
IT EQUIP 24	360	201	49	2,880			50	60/3	2,520	PANEL CA2
SPARE	201	51			2,880		52			
SPARE	201	53				1,800	54			
NOTES (AS APPLICABLE):				6,630	8,270	6,364	TTL PHASE VA	100	A. BUS (COPPER, UNO)	
1. COORDINATE CIRCUIT BREAKER TRIP WITH EQUIPMENT.				58	69	53	TTL PHASE AMPS	100	A. MAIN LUGS AND/OR FEEDER RATING	
				31%	39%	30%	PHASE BALANCE	10	KAIC MINIMUM RATING	
DEMAND SUMMARY:	CONN. (VA)	DEMAND FACTOR	DEMAND (VA)	ADDITIONAL NOTES (AS APPLICABLE):						
TOTAL RECEPTACLES (VA) =	16,560			2. PROVIDE ARC FAULT CIRCUIT BREAKERS FOR ALL 120V, 15A & 20A PATIENT ROOM BRANCH CIRCUITS SUPPLYING OUTLETS AND DEVICES.						
RECEPTACLES FIRST 10 KVA	10,000	1.00	10,000							
RECEPTACLES > 10 KVA	6,560	0.50	3,280							
LIGHTING	4,324	1.25	5,405							
MISCELLANEOUS EQUIPMENT	400	1.00	400							
OTHER EQUIPMENT (CONTINUOUS)		1.25								
LARGEST MOTOR		1.25								
HVAC EQUIPMENT (FLA = MCA X 0.8)		1.00								
KITCHEN EQUIPMENT		1.00								
TOTAL CONNECTED (VA)	21,284									
TOTAL DEMAND (VA)			19,085							
TOTAL DEMAND (AMPERES)			53.0							
PANEL DEMAND LOADING VS RATING	53.0%									

PANEL CB										
TYPE:	208	120	VOLTS	3	PHASE	4	WIRE	PROVIDE	XX	EQUIPMENT GROUND BUS
BOLT-ON	MOUNT:	SURFACE						IF	XX	100 % NEUTRAL BUS
HINGED TRIM	FEED:	TOP						CHECKED		ULSE LABEL
	NEMA -	1	ENCLOSURE							ISOLATED GROUND BAR
	LOAD	VA	TRIP/POLES	CT#	PHASE LOAD VA			CT#	CT# BKR	LOAD
	VA	TRIP/POLES	#	A	B	C	#	TRIP/POLES	VA	LOAD SERVED
DOUBLE ROOM 501 HEADBOARD RECEPTACLES	360	20/1	1	720			2	20/1	360	DOUBLE ROOM 506 HEADBOARD RECEPTACLES
DOUBLE ROOM 501 BED 1 RECEPTACLE	180	20/1	3		360		4	20/1	180	DOUBLE ROOM 506 BED 1 RECEPTACLE
SPARE	180	20/1	5				6	20/1		SPARE
DOUBLE ROOM 501 BED 2 RECEPTACLE	180	20/1	7	360			8	20/1	180	DOUBLE ROOM 506 BED 2 RECEPTACLE
DOUBLE ROOM 502 HEADBOARD RECEPTACLES	360	20/1	9		720		10	20/1	360	DOUBLE ROOM 507 HEADBOARD RECEPTACLES
DOUBLE ROOM 502 BED 1 RECEPTACLE	180	20/1	11			360	12	20/1	180	DOUBLE ROOM 507 BED 1 RECEPTACLE
SPARE	180	20/1	13				14	20/1		SPARE
DOUBLE ROOM 502 BED 2 RECEPTACLE	180	20/1	15		360		16	20/1	180	DOUBLE ROOM 507 BED 2 RECEPTACLE
DOUBLE ROOM 503 HEADBOARD RECEPTACLES	360	20/1	17			720	18	20/1	360	DOUBLE ROOM 508 HEADBOARD RECEPTACLES
DOUBLE ROOM 503 BED 1 RECEPTACLE	180	20/1	19	360			20	20/1	180	DOUBLE ROOM 508 BED 1 RECEPTACLE
SPARE	180	20/1	21				22	20/1		SPARE
DOUBLE ROOM 503 BED 2 RECEPTACLE	180	20/1	23			360	24	20/1	180	DOUBLE ROOM 508 BED 2 RECEPTACLE
DOUBLE ROOM 504 HEADBOARD RECEPTACLES	360	20/1	25	720			26	20/1	360	DOUBLE ROOM 509 HEADBOARD RECEPTACLES
DOUBLE ROOM 504 BED 1 RECEPTACLE	180	20/1	27		360		28	20/1	180	DOUBLE ROOM 509 BED 1 RECEPTACLE
SPARE	180	20/1	29				30	20/1		SPARE
DOUBLE ROOM 504 BED 2 RECEPTACLE	180	20/1	31	360			32	20/1	180	DOUBLE ROOM 509 BED 2 RECEPTACLE
DOUBLE ROOM 505 HEADBOARD RECEPTACLES	360	20/1	33		720		34	20/1	360	DOUBLE ROOM 510 HEADBOARD RECEPTACLES
DOUBLE ROOM 505 BED 1 RECEPTACLE	180	20/1	35			360	36	20/1	180	DOUBLE ROOM 510 BED 1 RECEPTACLE
IT EQUIP 50	360	20/1	37	360			38	20/1		SPARE
DOUBLE ROOM 505 BED 2 RECEPTACLE	180	20/1	39			360	40	20/1	180	DOUBLE ROOM 510 BED 2 RECEPTACLE
RCPS: MED PREP 52	720	20/1	41			1,390	42	20/1	670	BEDROOM LIGHTING: 501-505
IT EQUIP 50	360	20/1	43	1,030			44	20/1	670	BEDROOM LIGHTING: 506-510
IT EQUIP 50	360	20/1	45		984		46	20/1	624	BEDROOM LIGHTING: 601-606
IT EQUIP 50	360	20/1	47			984	48	20/1	624	BEDROOM LIGHTING: 607-612
LIGHTING: NURSES' STATION 54	590	20/1	49	950			50	20/1	360	IT EQUIP 38
NURSE CALL: IT 50	200	20/1	51		560		52	20/1	360	IT EQUIP 38
NURSE CALL: IT 50	200	20/1	53			560	54	20/1	360	IT EQUIP 38
PANEL CB2	2,520	60/3	55	2,720			56	20/1	200	NURSE CALL: IT 38
	3,062		57		5,558		58	30/2	2,496	TELECOM RACK: IT 38
	3,530		59			6,026	60		2,496	
NOTES (AS APPLICABLE):				7,580	9,982	10,760	TTL PHASE VA		100	A. BUS (COPPER, UNO)
1. COORDINATE CIRCUIT BREAKER TRIP WITH EQUIPMENT.				63	83	90	TTL PHASE AMPS		100	A. MAIN LUGS AND/OR FEEDER RATING
				27%	35%	38%	PHASE BALANCE		10	KAIC MINIMUM RATING
DEMAND SUMMARY:	CONN. (VA)	DEMAND FACTOR	DEMAND (VA)	ADDITIONAL NOTES (AS APPLICABLE):						
TOTAL RECEPTACLES (VA) =	17,840			2. PROVIDE ARC FAULT CIRCUIT BREAKERS FOR ALL 120V, 15A & 20A PATIENT ROOM BRANCH CIRCUITS SUPPLYING OUTLETS AND DEVICES.						
RECEPTACLES FIRST 10 KVA	10,000	1.00	10,000							
RECEPTACLES > 10 KVA	7,840	0.50	3,920							
LIGHTING	5,090	1.25	6,363							
MISCELLANEOUS EQUIPMENT	5,392	1.00	5,392							
OTHER EQUIPMENT (CONTINUOUS)		1.25								
LARGEST MOTOR		1.25								
HVAC EQUIPMENT (FLA = MCA X 0.8)		1.00								
KITCHEN EQUIPMENT		1.00								
TOTAL CONNECTED (VA)	28,322									
TOTAL DEMAND (VA)			25,675							
TOTAL DEMAND (AMPERES)			71.3							
PANEL DEMAND LOADING VS RATING	71.3%									

PANEL CA2

TYPE:	208	120	VOLTS	3	PHASE	4	WIRE	PROVIDE	XX	EQUIPMENT GROUND BUS
BOLT-ON	MOUNT:	SURFACE						IF	XX	100 % NEUTRAL BUS
HINGED TRIM	FEED:	TOP						CHECKED		ULSE LABEL
	NEMA -	1	ENCLOSURE							ISOLATED GROUND BAR
	LOAD	CT	CT	PHASE LOAD VA			CT	CT	LOAD	
	VA	BKR	TRIP/POLES	#	A	B	C	#	TRIP/POLES	VA
LOAD SERVED										LOAD SERVED
DOUBLE ROOM 401 HEADBOARD RECEPTACLES	360	201	1	720				2	201	360
DOUBLE ROOM 401 BED 1 RECEPTACLE	180	201	3		360			4	201	180
SPARE	180	201	5					6	201	
DOUBLE ROOM 401 BED 2 RECEPTACLE	180	201	7	360				8	201	180
DOUBLE ROOM 402 HEADBOARD RECEPTACLES	360	201	9		720			10	201	360
DOUBLE ROOM 402 BED 1 RECEPTACLE	180	201	11			360		12	201	180
SPARE	180	201	13					14	201	
DOUBLE ROOM 402 BED 2 RECEPTACLE	180	201	15		360			16	201	180
DOUBLE ROOM 403 HEADBOARD RECEPTACLES	360	201	17			720		18	201	360
DOUBLE ROOM 403 BED 1 RECEPTACLE	180	201	19	360				20	201	180
SPARE	180	201	21					22	201	
DOUBLE ROOM 403 BED 2 RECEPTACLE	180	201	23			360	24	201	180	
DOUBLE ROOM 404 HEADBOARD RECEPTACLES	360	201	25	720			26	201	360	
DOUBLE ROOM 404 BED 1 RECEPTACLE	180	201	27		360		28	201	180	
SPARE	180	201	29				30	201		
DOUBLE ROOM 404 BED 2 RECEPTACLE	180	201	31	360			32	201	180	
DOUBLE ROOM 405 HEADBOARD RECEPTACLES	360	201	33		720		34	201	360	
DOUBLE ROOM 405 BED 1 RECEPTACLE	180	201	35			360	36	201	180	
SPARE	180	201	37				38	201		
DOUBLE ROOM 405 BED 2 RECEPTACLE	180	201	39		360		40	201	180	
SPARE	201	41					42	201		
SPARE	201	43					44	201		
SPARE	201	45					46	201		
SPARE	201	47					48	201		
SPARE	201	49					50	201		
SPARE	201	51					52	201		
SPARE	201	53					54	201		

NOTES (AS APPLICABLE):

1. COORDINATE CIRCUIT BREAKER TRIP WITH EQUIPMENT.

	2,520	2,880	1,800	TTL PHASE VA	60	A. BUS (COPPER, UNO)
	21	24	15	TTL PHASE AMPS	60	A. MAIN LUGS AND/OR FEEDER RATING
	35%	40%	25%	PHASE BALANCE	10	KAIC MINIMUM RATING

DEMAND SUMMARY:

CONN. (VA)	DEMAND FACTOR	DEMAND (VA)	ADDITIONAL NOTES (AS APPLICABLE):
TOTAL RECEPTACLES (VA) =	7,200		2. PROVIDE ARC FAULT CIRCUIT BREAKERS FOR ALL 120V, 15A & 20A PATENT ROOM BRANCH CIRCUITS SUPPLYING OUTLETS AND DEVICES.
RECEPTACLES FIRST 10 KVA	7,200	1.00	
RECEPTACLES > 10 KVA		0.50	
LIGHTING		1.25	
MISCELLANEOUS EQUIPMENT		1.00	
OTHER EQUIPMENT (CONTINUOUS)		1.25	
LARGEST MOTOR		1.25	
HVAC EQUIPMENT (FLA = MCA X 0.8)		1.00	
KITCHEN EQUIPMENT		1.00	
TOTAL CONNECTED (VA)	7,200		
TOTAL DEMAND (VA)		7,200	
TOTAL DEMAND (AMPERES)		20.0	
PANEL DEMAND LOADING VS RATING	33.3%		

NOTE: ARRANGE PANELBOARD BRANCH CIRCUIT BREAKERS AS SHOWN ON THE BELOW SCHEDULES. AGREEMENT OF CIRCUIT BREAKER (POLE) NUMBERS WITH THE PANEL SCHEDULES AND ELECTRICAL FLOOR PLANS IS REQUIRED IN ORDER TO AVOID CONFUSION DURING CONSTRUCTION. REDRAWING THE CIRCUITRY FOR RECORD DRAWING PURPOSES AND ACCURATE DOCUMENTATION OF THE AS-BUILT CONDITIONS.

TYPE:	208	120	VOLTS	3	PHASE	4	WIRE	PROVIDE	XX	EQUIPMENT GROUND BUS
BOLT-ON	MOUNT:	SURFACE						IF	XX	100 % NEUTRAL BUS
HINGED TRIM	FEED:	TOP						CHECKED	ULSE	ISOLATED GROUND BAR
	NEMA -	1	ENCLOSURE							
	LOAD	LOAD	LOAD	LOAD	LOAD	LOAD	LOAD			
	VA	TRIP/POLES	#	A	B	C	#	TRIP/POLES	VA	LOAD SERVED
PTH01: ROOM 301	1,248	15/2	1	2,496			2	15/2	1,248	PTH01: ROOM 302
	1,248		3		2,496		4		1,248	
PTH01: ROOM 303	1,248	15/2	5		2,496	2,496	6	15/2	1,248	PTH01: ROOM 304
	1,248		7	2,496			8		1,248	
PTH01: ROOM 305	1,248	15/2	9		2,496		10	15/2	1,248	PTH01: ROOM 306
	1,248		11		2,496		12		1,248	
PTH01: ROOM 307	1,248	15/2	13	2,496			14	15/2	1,248	PTH01: ROOM 308
	1,248		15		2,496		16		1,248	
PTH01: ROOM 309	1,248	15/2	17		2,496	2,496	18	15/2	1,248	PTH01: ROOM 310
	1,248		19	2,496			20		1,248	
PTH01: ROOM 311	1,248	15/2	21		2,496		22	15/2	1,248	PTH01: ROOM 312
	1,248		23			2,496	24		1,248	
PTH01: ROOM 401	1,248	15/2	25	2,496			26	15/2	1,248	PTH01: ROOM 402
	1,248		27		2,496		28		1,248	
PTH01: ROOM 403	1,248	15/2	29			2,496	30	15/2	1,248	PTH01: ROOM 404
	1,248		31	2,496			32		1,248	
PTH01: ROOM 405	1,248	15/2	33		2,496		34	15/2	1,248	PTH01: ROOM 406
	1,248		35			2,496	36		1,248	
PTH01: ROOM 407	1,248	15/2	37	2,496			38	15/2	1,248	PTH01: ROOM 408
	1,248		39		2,496		40		1,248	
PTH01: ROOM 409	1,248	15/2	41		2,496		42	15/2	1,248	PTH01: ROOM 410
	1,248		43	2,496			44		1,248	
SPARE		20/1	45				46	20/1		SPARE
ER11	520	15/2	47			1,040	48	15/2	520	ER12
	520		49	1,040			50		520	
AH07	666	15/2	51		1,331		52	15/2	666	AH08
	666		53			1,331	54		666	
AH07 AUX HEAT	3,074	35/3	55	7,302			56	45/3	4,227	AH08 AUX HEAT
	3,074		57		7,302		58		4,227	
	3,074		59			7,302	60		4,227	
HP07	1,739	30/3	61	3,478			62	30/3	1,739	HP08
	1,739		63		3,478		64		1,739	
	1,739		65			3,478	66		1,739	
SPARE		20/1	67				68	20/1		SPARE
SPARE		20/1	69				70	20/1		SPARE
SPARE		20/1	71				72	20/1		SPARE
NOTES (AS APPLICABLE):				31,787	26,583	30,623	TTL PHASE VA	400	A: BUS (COPPER, UNO)	
1. COORDINATE CIRCUIT BREAKER TRIP WITH EQUIPMENT.				285	247	255	TTL PHASE AMPS	400	A: MAIN LUGS AND/OR FEEDER RATING	
				35%	32%	33%	PHASE BALANCE	25	KAIC MINIMUM RATING	
DEMAND SUMMARY:	CONN. (VA)	DEMAND FACTOR		DEMAND (VA)						ADDITIONAL NOTES (AS APPLICABLE):
TOTAL RECEPTACLES (VA) =										2. PROVIDE ARC FAULT CIRCUIT BREAKERS FOR ALL 120V, 15A & 20A PATIENT ROOM BRANCH CIRCUITS SUPPLYING OUTLETS AND DEVICES.
RECEPTACLES FIRST 10 KVA		1.00								
RECEPTACLES > 10 KVA		0.50								
LIGHTING		1.25								
MISCELLANEOUS EQUIPMENT		1.00								
OTHER EQUIPMENT (CONTINUOUS)		1.25								
LARGEST MOTOR	5,217	1.25		6,521						
HVAC EQUIPMENT (FLA = MCA X 0.8)	86,776	1.00		86,776						
KITCHEN EQUIPMENT		1.00								
TOTAL CONNECTED (VA)	91,993									
TOTAL DEMAND (VA)				93,297						
TOTAL DEMAND (AMPERES)				259.0						
PANEL DEMAND LOADING VS RATING	64.7%									

TYPE:	208	120	VOLTS	3	PHASE	4	WIRE	PROVIDE	XX	EQUIPMENT GROUND BUS
BOLT-ON	MOUNT:	SURFACE						IF	XX	100 % NEUTRAL BUS
HINGED TRIM	FEED:	TOP						CHECKED	ULSE	ISOLATED GROUND BAR
	NEMA -	1	ENCLOSURE							
	LOAD	LOAD	LOAD	LOAD	LOAD	LOAD	LOAD			
	VA	TRIP/POLES	#	A	B	C	#	TRIP/POLES	VA	LOAD SERVED
PTH01: ROOM 501	1,248	15/2	1	2,496			2	15/2	1,248	PTH01: ROOM 502
	1,248		3		2,496		4		1,248	
PTH01: ROOM 503	1,248	15/2	5		2,496	2,496	6	15/2	1,248	PTH01: ROOM 504
	1,248		7	2,496			8		1,248	
PTH01: ROOM 505	1,248	15/2	9		2,496		10	15/2	1,248	PTH01: ROOM 506
	1,248		11		2,496		12		1,248	
PTH01: ROOM 507	1,248	15/2	13	2,496			14	15/2	1,248	PTH01: ROOM 508
	1,248		15		2,496		16		1,248	
PTH01: ROOM 509	1,248	15/2	17		2,496	2,496	18	15/2	1,248	PTH01: ROOM 510
	1,248		19	2,496			20		1,248	
PTH01: ROOM 601	1,248	15/2	21		2,496		22	15/2	1,248	PTH01: ROOM 602
	1,248		23			2,496	24		1,248	
PTH01: ROOM 603	1,248	15/2	25	2,496			26	15/2	1,248	PTH01: ROOM 604
	1,248		27		2,496		28		1,248	
PTH01: ROOM 605	1,248	15/2	29			2,496	30	15/2	1,248	PTH01: ROOM 606
	1,248		31	2,496			32		1,248	
PTH01: ROOM 607	1,248	15/2	33		2,496		34	15/2	1,248	PTH01: ROOM 608
	1,248		35			2,496	36		1,248	
PTH01: ROOM 609	1,248	15/2	37	2,496			38	15/2	1,248	PTH01: ROOM 610
	1,248		39		2,496		40		1,248	
PTH01: ROOM 611	1,248	15/2	41		2,496		42	15/2	1,248	PTH01: ROOM 612
	1,248		43	2,496			44		1,248	
SPARE		20/1	45				46	20/1		SPARE
AH17	749	20/2	47			749	48	20/1		SPARE
	749		49	749			50	20/1		SPARE
AH18	666	15/2	51		666		52	20/1		SPARE
	666		53			666	54	20/1		SPARE
AH18 AUX HEAT	4,227	45/3	55	8,551			56	45/3	4,323	AH17 AUX HEAT
	4,227		57		8,551		58		4,323	
	4,227		59			8,551	60		4,323	
HP18	1,739	30/3	61	3,929			62	35/3	2,190	HP17
	1,739		63		3,929		64		2,190	
	1,739		65			3,929	66		2,190	
SPARE		20/1	67				68	20/1		SPARE
SPARE		20/1	69				70	20/1		SPARE
SPARE		20/1	71				72	20/1		SPARE
NOTES (AS APPLICABLE):				33,197	30,618	31,366	TTL PHASE VA	400	A: BUS (COPPER, UNO)	
1. COORDINATE CIRCUIT BREAKER TRIP WITH EQUIPMENT.				277	235	261	TTL PHASE AMPS	400	A: MAIN LUGS AND/OR FEEDER RATING	
				35%	32%	33%	PHASE BALANCE	25	KAIC MINIMUM RATING	
DEMAND SUMMARY:	CONN. (VA)	DEMAND FACTOR		DEMAND (VA)						ADDITIONAL NOTES (AS APPLICABLE):
TOTAL RECEPTACLES (VA) =										2. PROVIDE ARC FAULT CIRCUIT BREAKERS FOR ALL 120V, 15A & 20A PATIENT ROOM BRANCH CIRCUITS SUPPLYING OUTLETS AND DEVICES.
RECEPTACLES FIRST 10 KVA		1.00								
RECEPTACLES > 10 KVA		0.50								
LIGHTING		1.25								
MISCELLANEOUS EQUIPMENT		1.00								
OTHER EQUIPMENT (CONTINUOUS)		1.25								
LARGEST MOTOR	6,571	1.25		8,214						
HVAC EQUIPMENT (FLA = MCA X 0.8)	88,609	1.00		88,609						
KITCHEN EQUIPMENT		1.00								
TOTAL CONNECTED (VA)	95,181									
TOTAL DEMAND (VA)				96,824						
TOTAL DEMAND (AMPERES)				268.8						
PANEL DEMAND LOADING VS RATING	67.2%									

PANEL EHC										
TYPE:	208	120	VOLTS	3	PHASE	4	WIRE	PROVIDE	XX	EQUIPMENT GROUND BUS
BOLT-ON	MOUNT:	SURFACE						IF	XX	100 % NEUTRAL BUS
HINGED TRIM	FEED:	TOP						CHECKED	XX	ULSE LABEL
	NEMA -	1	ENCLOSURE							ISOLATED GROUND BAR
	LOAD	LOAD	LOAD	LOAD	LOAD	LOAD	LOAD			
	VA	CTK	CTK	#	A	B	C	CTK	CTK BKR	LOAD VA
LOAD SERVED	VA	TRIP/POLES							TRIP/POLES	LOAD SERVED
PTH01: ROOM 701	1,248	15/2	1	2,496				2	15/2	1,248
	1,248		3		2,496			4		1,248
PTH01: ROOM 703	1,248	15/2	5			2,496		6	15/2	1,248
	1,248		7	2,496				8		1,248
PTH01: ROOM 705	1,248	15/2	9		2,496			10	15/2	1,248
	1,248		11			2,496		12		1,248
PTH01: ROOM 707	1,248	15/2	13	2,496				14	15/2	1,248
	1,248		15		2,496			16		1,248
PTH01: ROOM 709	1,248	15/2	17			2,496		18	15/2	1,248
	1,248		19	2,496				20		1,248
PTH01: ROOM 711	1,248	15/2	21		2,496			22	15/2	1,248
	1,248		23			2,496		24		1,248
PTH01: ROOM 801	1,248	15/2	25	2,496				26	15/2	1,248
	1,248		27		2,496			28		1,248
PTH01: ROOM 803	1,248	15/2	29			2,496		30	15/2	1,248
	1,248		31	2,496				32		1,248
PTH01: ROOM 805	1,248	15/2	33		2,496			34	15/2	1,248
	1,248		35			2,496		36		1,248
PTH01: ROOM 807	1,248	15/2	37	2,496				38	15/2	1,248
	1,248		39		2,496			40		1,248
PTH01: ROOM 809	1,248	15/2	41			2,496		42	15/2	1,248
	1,248		43	2,496				44		1,248
PTH01: ROOM 811	1,248	15/2	45		2,496			46	15/2	1,248
	1,248		47			2,496		48		1,248
AH16 AUX HEAT	4,227	45/3	49	4,227				50	20/1	SPARE
	4,227		51		4,227			52	20/1	SPARE
	4,227		53			4,747		54	15/2	ER19
HP16	1,739	30/3	55	2,259				56		520
	1,739		57		2,405			58	15/2	666
	1,739		59			2,405		60		666
SPARE		20/1	61					62	20/1	SPARE
SPARE		20/1	63					64	20/1	SPARE
SPARE		20/1	65					66	20/1	SPARE
NOTES (AS APPLICABLE):				26,454	26,600	27,120	TTL PHASE VA	400 A. BUS (COPPER, UNO)		
1. COORDINATE CIRCUIT BREAKER TRIP WITH EQUIPMENT.				220	222	226	TTL PHASE AMPS	300 A. MAIN LUGS AND/OR FEEDER RATING		
				33%	33%	34%	PHASE BALANCE	14 KAIC MINIMUM RATING		
DEMAND SUMMARY:	CONV.	DEMAND	DEMAND	ADDITIONAL NOTES (AS APPLICABLE):						
TOTAL RECEPTACES (VA) =	CONV. FACTOR	FACTOR	(VA)	2. PROVIDE ARC FAULT CIRCUIT BREAKERS FOR ALL 120V, 15A & 20A PARENT ROOM BRANCH CIRCUITS SUPPLYING OUTLETS AND DEVICES.						
RECEPTACES FIRST 10 KVA		1.00								
RECEPTACES >10 KVA		0.50								
LIGHTING		1.25								
MISCELLANEOUS EQUIPMENT		1.00								
OTHER EQUIPMENT (CONTINUOUS)		1.25								
LARGEST MOTOR	5,217	1.25	6,521							
HVAC EQUIPMENT (FLA = MCA X 0.8)	74,957	1.00	74,957							
KITCHEN EQUIPMENT		1.00								
TOTAL CONNECTED (VA)		80,174								
TOTAL DEMAND (VA)			81,478							
TOTAL DEMAND (AMPERES)			226.2							
PANEL DEMAND LOADING VS RATING		75.4%								

CONSTRUCTION, PRICING SHALL
D AND SEALED DOCUMENTS.

**PRELIMINARY
PRICING ONLY -
NOT FOR
CONSTRUCTION**

NORTH CAROLINA
PROFESSIONAL
8433
UNCAN McFARLEN

David R. Polston - Architect
3806 Park Ave. Suite C, Wilmington, NC 28403
Architecture Planning Design

120 BED
NURSING FACILITY
ELECTRICAL
PANEL SCHEDULES

E0.15

PANEL LSD														
TYPE: BOLT-ON Hinged TRIM	208		120 VOLTS	3 PHASE	4 WIRE			PROVIDE IF	XX	EQUIPMENT GROUND BUS				
	MOUNT:	SURFACE						XX	100 % NEUTRAL BUS					
	FEED:	TOP							USE LABEL					
	NEMA - 1 ENCLOSURE													
	LOAD VA	CKT BKR	CTK #	PHASE LOAD VA			CKT #	CKT BKR	LOAD VA	LOAD SERVED				
LIGHTING SERVORS				A	B	C								
LIGHTING-CORRIDORS 125, 225	616	20/1	1	1,256			2	20/1	641	LIGHTING-CORRIDORS 325, 421				
LIGHTING- LIVING AREA 23	250	20/1	3		450		4	20/1	200	PAGING SYSTEM				
LIGHTING- DINING AREA 30	250	20/1	5			450	6	20/1	200	ACCESS CONTROL				
SPARE		20/1	7				8	20/1		SPARE				
SPARE		20/1	9				10	20/1		SPARE				
SPARE		20/1	11				12	20/1		SPARE				
SPARE		20/1	13				14	30/3		SPD				
SPARE		20/1	15				16	I		I				
SPARE		20/1	17				18							
NOTES (AS APPLICABLE)				1,256	450	450	TTL PHASE VA			60 A BUS (COPPER, UNO)				
1. COORDINATE CIRCUIT BREAKER TRIP WITH EQUIPMENT.				10	4	4	TTL PHASE AMPS			60 A MAIN LGUGS AND/OR FEEDER RATING				
2. COORDINATE SPD CIRCUIT BREAKER TRIP WITH SPD PROVIDED.				58%	21%	21%	PHASE BALANCE			10 KAIC MINIMUM RATING				
DEMAND SUMMARY:		CONN. (VA)	DEMAND FACTOR	DEMAND (VA)										
TOTAL RECEPTACLES (VA) =														
RECEPTACLES FIRST 10 KVA			1.00											
RECEPTACLES > 10 KVA			0.50											
LIGHTING		1,756	1.25	2,195										
MISCELLANEOUS EQUIPMENT		400	1.00	400										
OTHER EQUIPMENT (CONTINUOUS)			1.25											
LARGEST MOTOR			1.25											
HVAC EQUIPMENT (FLA = MCA X 0.8)														
KITCHEN EQUIPMENT			1.00											
TOTAL CONNECTED (VA)		2,156												
TOTAL DEMAND (VA)				2,595										
TOTAL DEMAND (AMPERES)				7.52										
PANEL DEMAND LOADING VS RATING		12.0%												

PANEL NK

TYPE:	208	120	VOLTS	3	PHASE	4	WIRE	PROVIDE	IF	XX	EQUIPMENT GROUND BUS
BOLT-ON	MOUNT:	SURFACE	FEED:	TOP				CHECKED	IF	XX	100 % NEUTRAL BUS
HINGED TRIM											ULSE LABEL
	NEMA -			ENCLOSURE							ISOLATED GROUND BAR
	LOAD	VA	CTK	CTK	PHASE	LOAD	VA	CTK	CTK	LOAD	VA
	TRIP/POLES	#	A	B	C	TRIP/POLES	#	TRIP/POLES	#	VA	LOAD SERVED
CONVENED RCPS	1,080	20/1	1	2,520		2	20/1	1,440		K25: MOBILE HEATED CABINET	
RCPS: KITCHEN OFFICE	900	20/1	3		2,340	4	20/1	1,440		K25: MOBILE HEATED CABINET	
RCP: GENERAL	180	20/1	5			900	6	20/1	720	K29: MIXER	
RCP: GRIDDLE	180	20/1	7	540			9	20/1	360	K35: SLICER	
K12: HEATED BANQUET CART	1,656	20/1	9		2,376		10	20/1	720	K33: JUICE DISPENSER	
K12: HEATED BANQUET CART	1,656	20/1	11			3,384	12	20/1	1,728	K32: TEA BRWR	
SPARE		20/1	13	1,368			14	20/1	1,368	K31: COFFEE MAKER	
SPARE		20/1	15				16	20/1			
SPARE		20/1	17			2,400	18	30/1	2,400	K30: BEVERAGE TABLE	
SPARE		20/1	19	864			20	20/1	864	LIGHTING: KITCHEN / STAFF LOUNGE	
SPARE		20/1	21				22	20/1		SPARE	
SPARE		20/1	23				24	20/1		SPARE	
SPARE		20/1	25				26	20/1		SPARE	
SPARE		20/1	27				28	20/1		SPARE	
SPARE		20/1	29				30	20/1		SPARE	
SPARE		20/1	31				32	20/1		SPARE	
SPARE		20/1	33				34	20/1		SPARE	
SPARE		20/1	35				36	20/1		SPARE	
K2: WAREWASHER EST-44	6,605	70/3	37	6,605			38	20/1		SPARE	
	6,605		39		6,605		40	20/1		SPARE	
	6,605		41			6,605	42	20/1		SPARE	
K2: WAREWASHER BOOSTER HEATER	5,044	60/3	43	5,044			44	20/1		SPARE	
	5,044		45		5,044		46	20/1		SPARE	
	5,044		47			5,044	48	20/1		SPARE	
K15: STEAM KETTLE	4,912	60/3	49	4,912			50	20/1		SPARE	
	4,912		51		4,912		52	20/1		SPARE	
	4,912		53			4,912	54	20/1		SPARE	
K18: ELECTRIC STEAMER	5,512	60/3	55	5,512			56	20/1		SPARE	
	5,512		57		7,384		58	30/2	1,872	K23: HOT FOOD TABLE	
	5,512		59			7,384	60		1,872		

NOTES (AS APPLICABLE):

1. COORDINATE CIRCUIT BREAKER TRIP WITH EQUIPMENT.

2. GFCI CIRCUIT BREAKERS AS REQUIRED BY THE NEC.

DEMAND SUMMARY:

TOTAL RECEPTACES (VA) =	2,340	CONN. (VA)	DEMAND FACTOR	DEMAND (VA)
RECEPTACES FIRST 10 KVA	2,340	1.00		2,340
RECEPTACES > 10 KVA		0.50		
LIGHTING	864	1.25		1,080
MISCELLANEOUS EQUIPMENT		1.00		
OTHER EQUIPMENT (CONTINUOUS)		1.25		
LARGEST MOTOR		1.25		
HVAC EQUIPMENT (FLA = MCA X 0.8)				
KITCHEN EQUIPMENT	24	83.451	0.65	54.243
TOTAL CONNECTED (VA)		86,655		
TOTAL DEMAND (VA)				57,663
TOTAL DEMAND (AMPERES)				160.1

PANEL DEMAND LOADING VS RATING


71.1%

ADDITIONAL NOTES (AS APPLICABLE):

3. KWH REPRESENTS KITCHEN EQUIPMENT NUMBERS.

4. KITCHEN EQUIPMENT DEMAND FACTOR PER NEC TABLE 220.56.

[illegible]

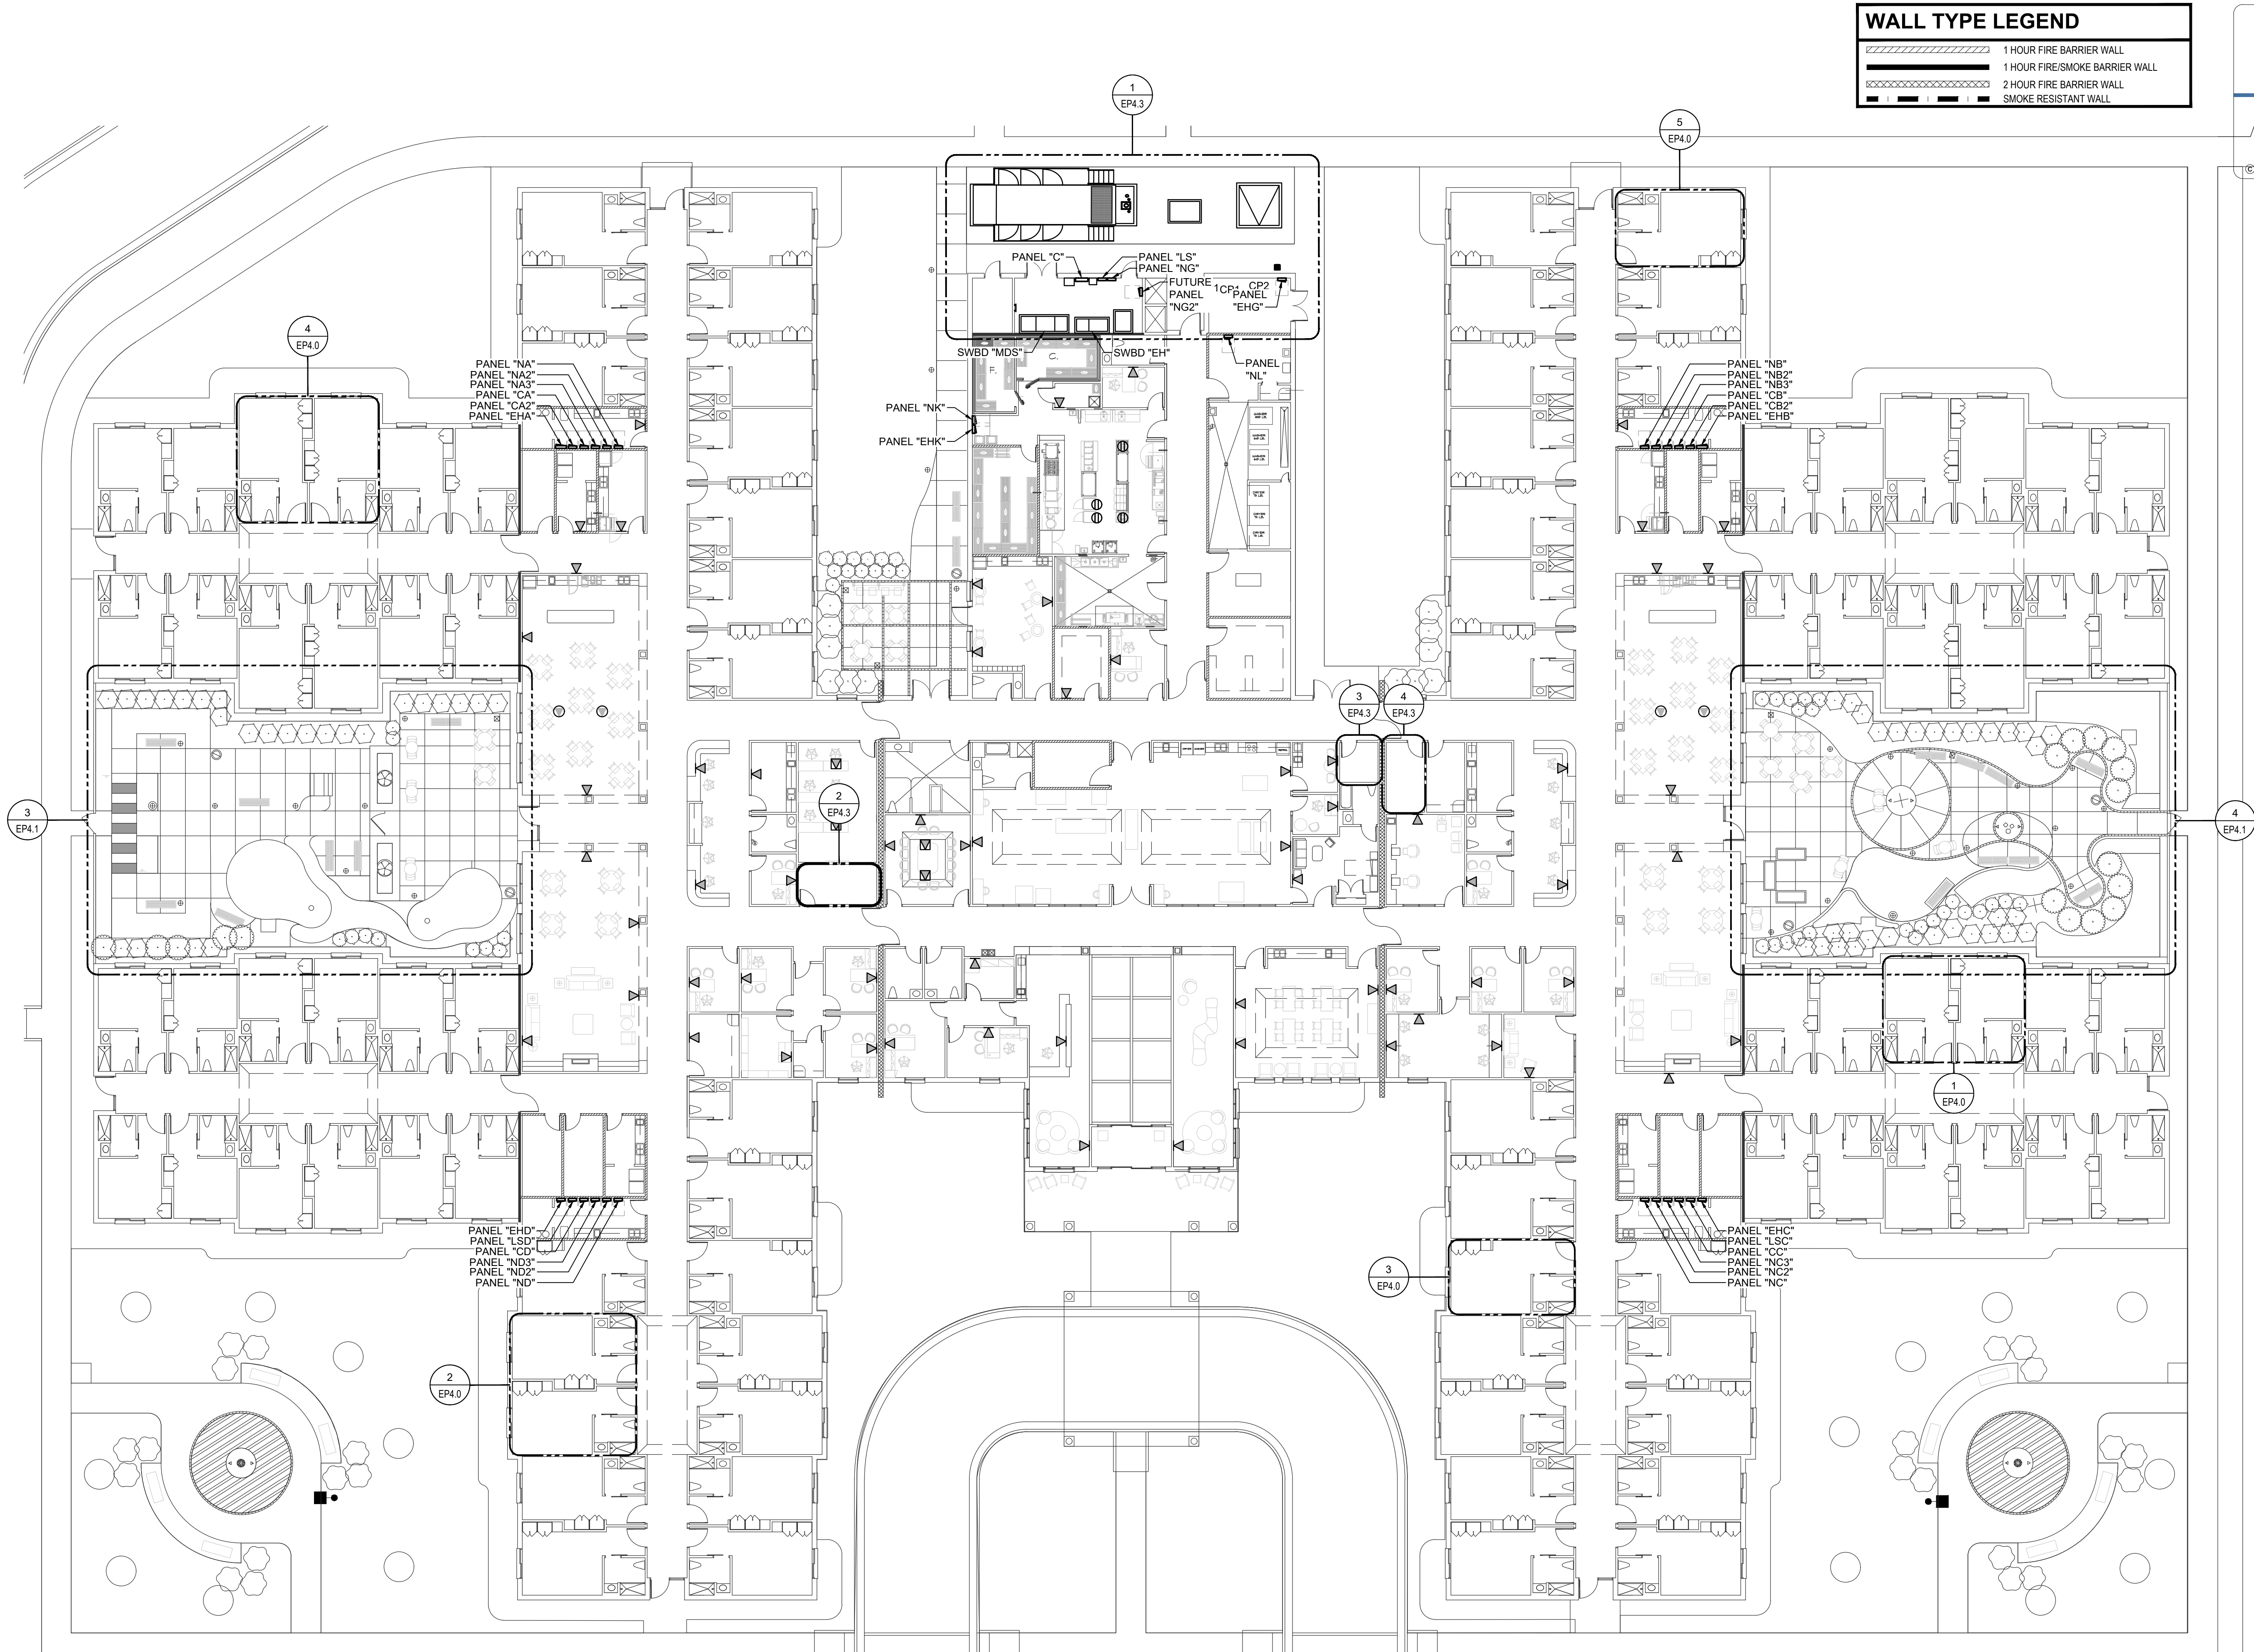

WALL TYPE LEGEND	
	1 HOUR FIRE BARRIER WALL
	1 HOUR FIRE/SMOKE BARRIER WALL
	2 HOUR FIRE BARRIER WALL
	SMOKE RESISTANT WALL

CBHF
Engineers, PLLC
2246 Yaupon Drive
Wilmington, NC 28401
Phone: 910.791.4000
www.cbhfengineers.com
© Copyright 2026 CBHF Engineers, PLLC NC# P-0506


120 BED
NURSING FACILITY
ELECTRICAL REFERENCE
4 PANELBOARD PLAN

David R. Polston - Architect
3806 Park Ave. Suite C, Wilmington, NC 28403
Architecture Planning Design

PRINCIPLE HEALTH CARE
WAKE COUNTY
Holly Springs, North Carolina

PRELIMINARY
PRICING ONLY
NOT FOR
CONSTRUCTION

NOT FINAL. SUBJECT TO REVISION. NOT FOR PERMITTING. FABRICATION, MATERIAL OR EQUIPMENT PURCHASE, INSTALLATION, OR CONSTRUCTION. PRICING SHALL STATE ALL ASSUMPTIONS, EXCLUSIONS, ALLOWANCES, AND CONTINGENCIES AND SHALL BE RECONCILED WITH THE FINAL SIGNED AND SEALED DOCUMENTS.

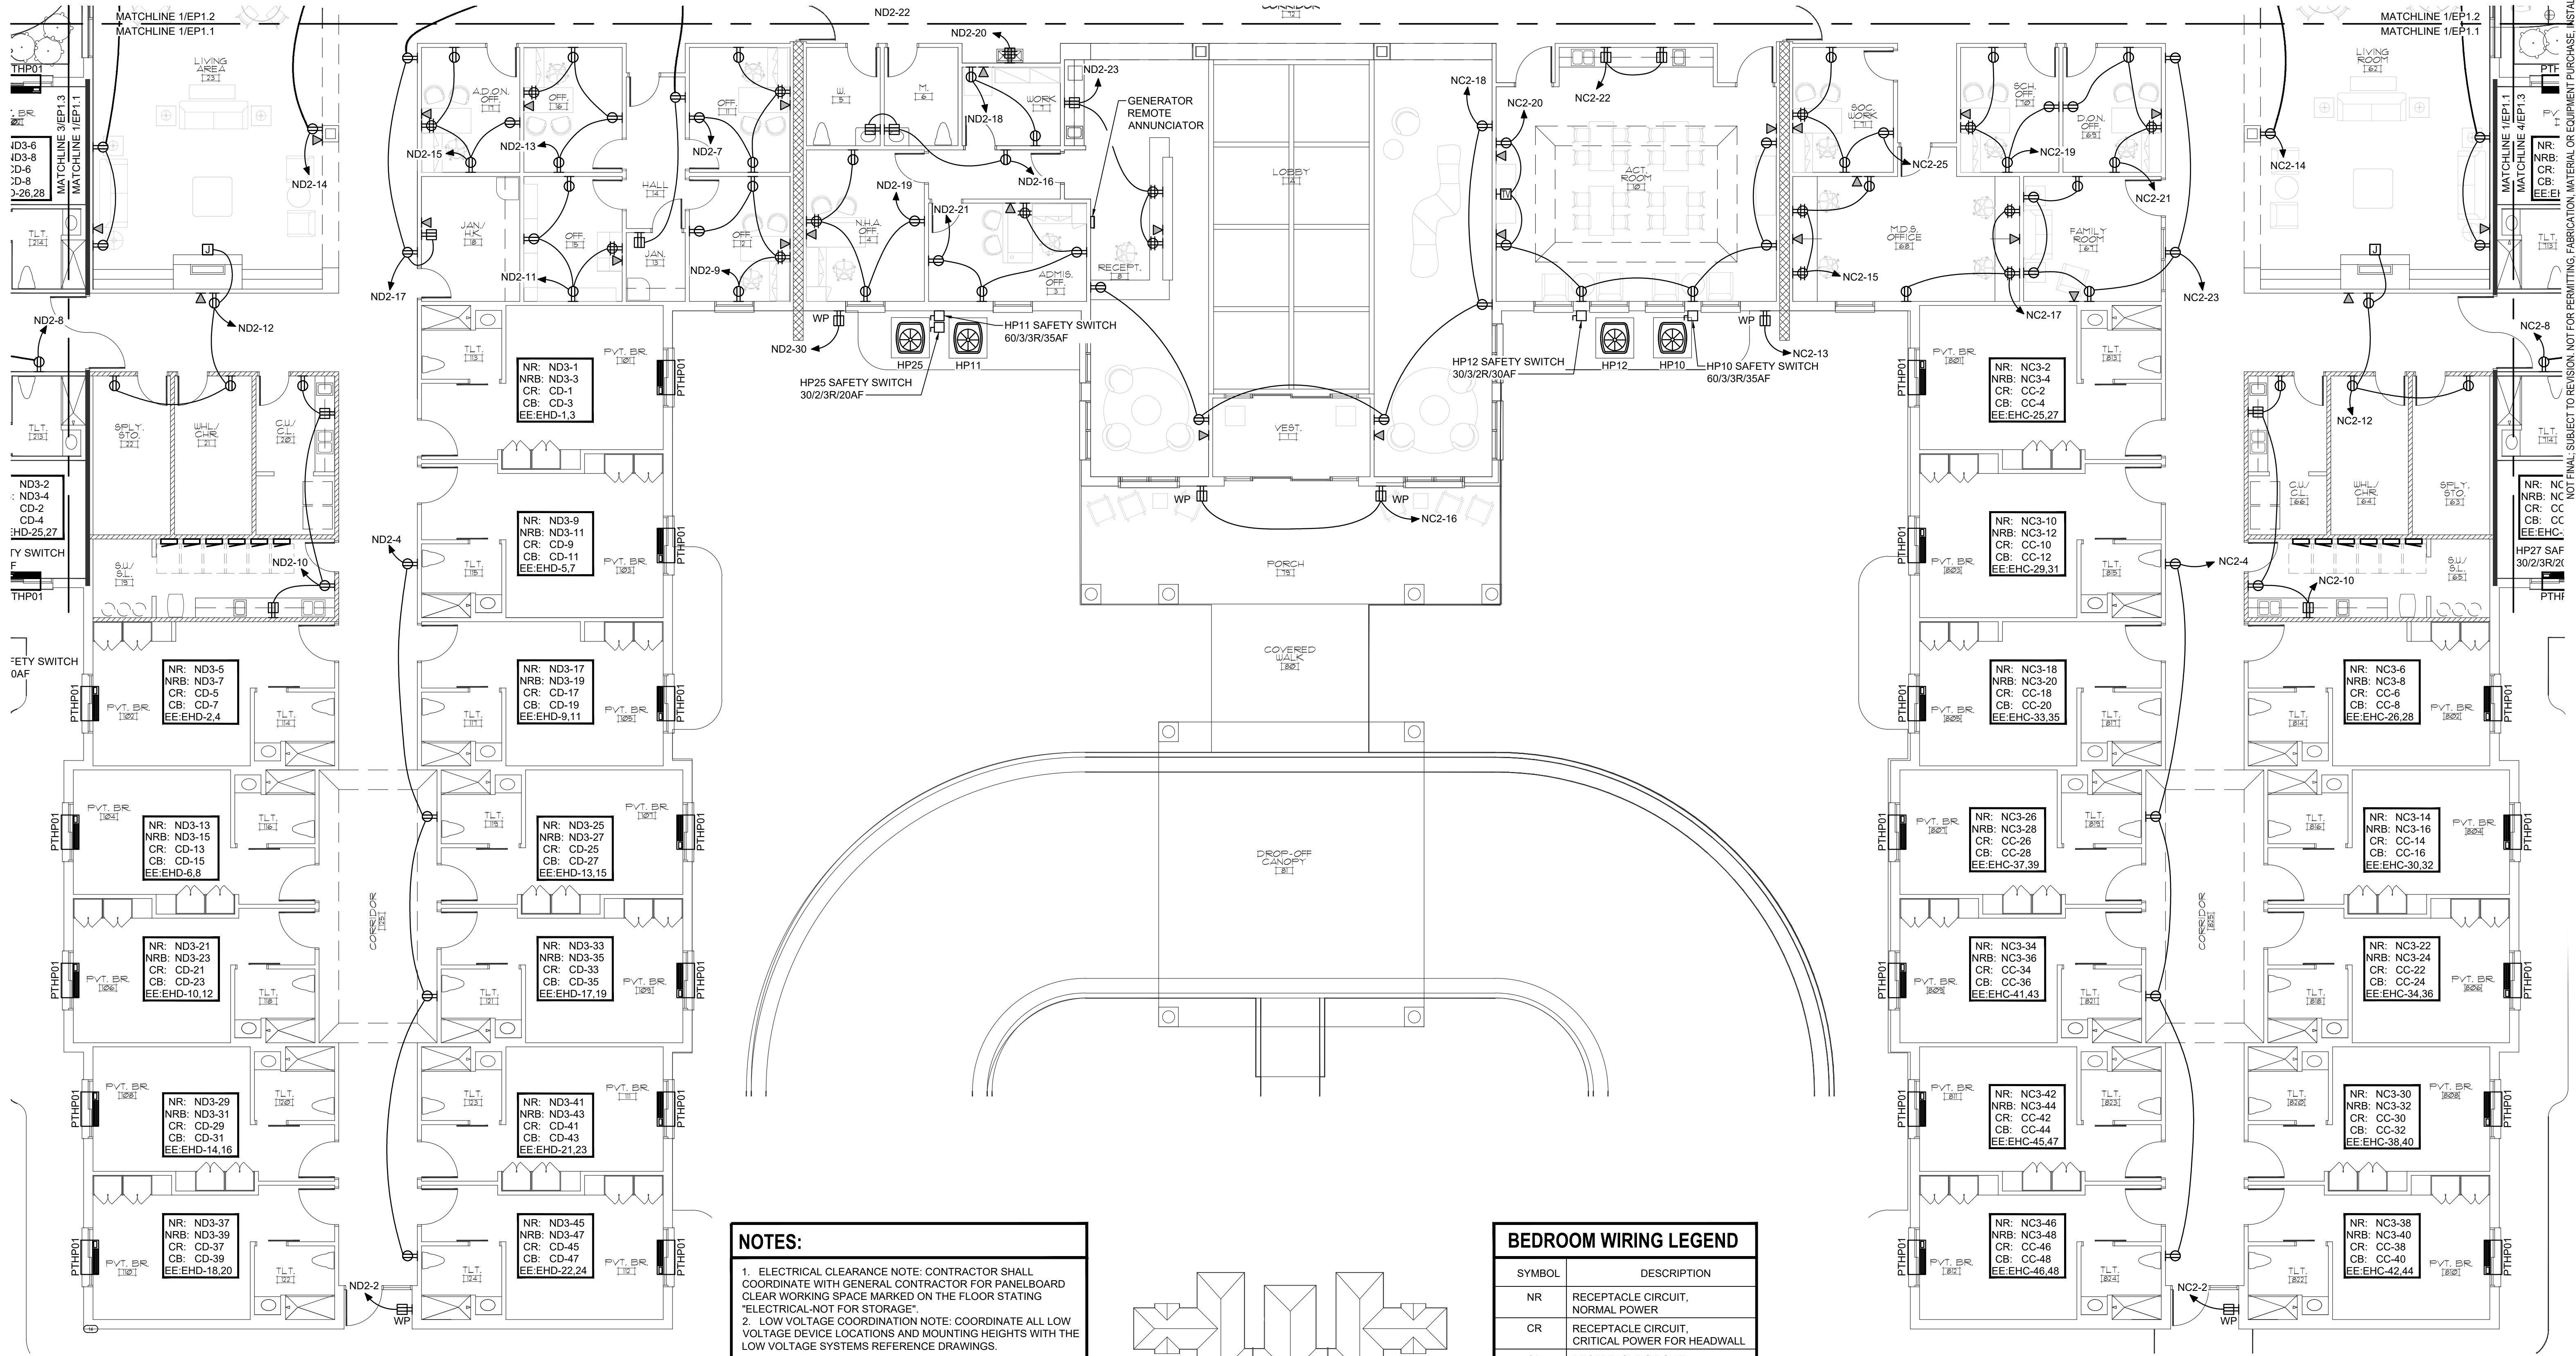

WALL TYPE LEGEND

	1 HOUR FIRE BARRIER WALL
	1 HOUR FIRE/SMOKE BARRIER WALL
	2 HOUR FIRE BARRIER WALL
	SMOKE RESISTANT WALL

CBHF
Engineers, PLLC

2246 Yaupon Drive
Wilmington, NC 28401
Phone: 910.791.4000
www.cbhfengineers.com
© Copyright 2026 CBHF Engineers, PLLC NCH P-0506

PRELIMINARY
PRICING ONLY
NOT FOR
CONSTRUCTION

PRINCIPLE HEALTH CARE
WAKE COUNTY
Holly Springs, North Carolina


David R. Polston - Architect
3806 Park Ave. Suite C, Wilmington, NC 28403
Architecture Planning Design

120 BED
NURSING FACILITY
ELECTRICAL
PARTIAL POWER PLAN

EP
1.1

NOTES:

- ELECTRICAL CLEARANCE NOTE: CONTRACTOR SHALL COORDINATE WITH GENERAL CONTRACTOR FOR PANEL BOARD CLEAR WORKING SPACE MARKED ON THE FLOOR STATING "ELECTRICAL-NOT FOR STORAGE".
- LOW VOLTAGE COORDINATION NOTE: COORDINATE ALL LOW VOLTAGE DEVICE LOCATIONS AND MOUNTING HEIGHTS WITH THE LOW VOLTAGE SYSTEMS REFERENCE DRAWINGS.
- COORDINATE DEVICE LOCATIONS WITH ARCHITECTURAL ELEVATIONS PRIOR TO ROUGH-IN.
- SEE ENLARGED BEDROOM PLANS ON SHEET EP4.0 FOR BEDROOM PLANS.

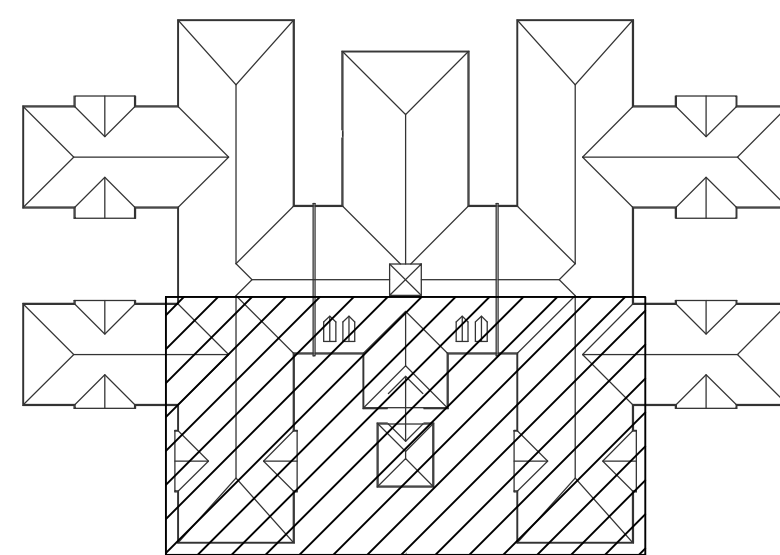

0
KEYPLAN
NOT TO SCALE

BEDROOM WIRING LEGEND

SYMBOL	DESCRIPTION
NR	RECEPTACLE CIRCUIT, NORMAL POWER
CR	RECEPTACLE CIRCUIT, CRITICAL POWER FOR HEADWALL
CB	RECEPTACLE CIRCUIT, CRITICAL POWER FOR BED
NRB	BATHROOM RECEPTACLE CIRCUIT, NORMAL POWER
EH	EQUIPMENT CIRCUIT, EMERG. EQUIP POWER FOR DAHU
NL	LIGHTING CIRCUIT, NORMAL POWER
CL	LIGHTING CIRCUIT, CRITICAL POWER


1


PARTIAL POWER PLAN

1/8" = 1'-0"

0 4' 8' 16'

PLAN
NORTH

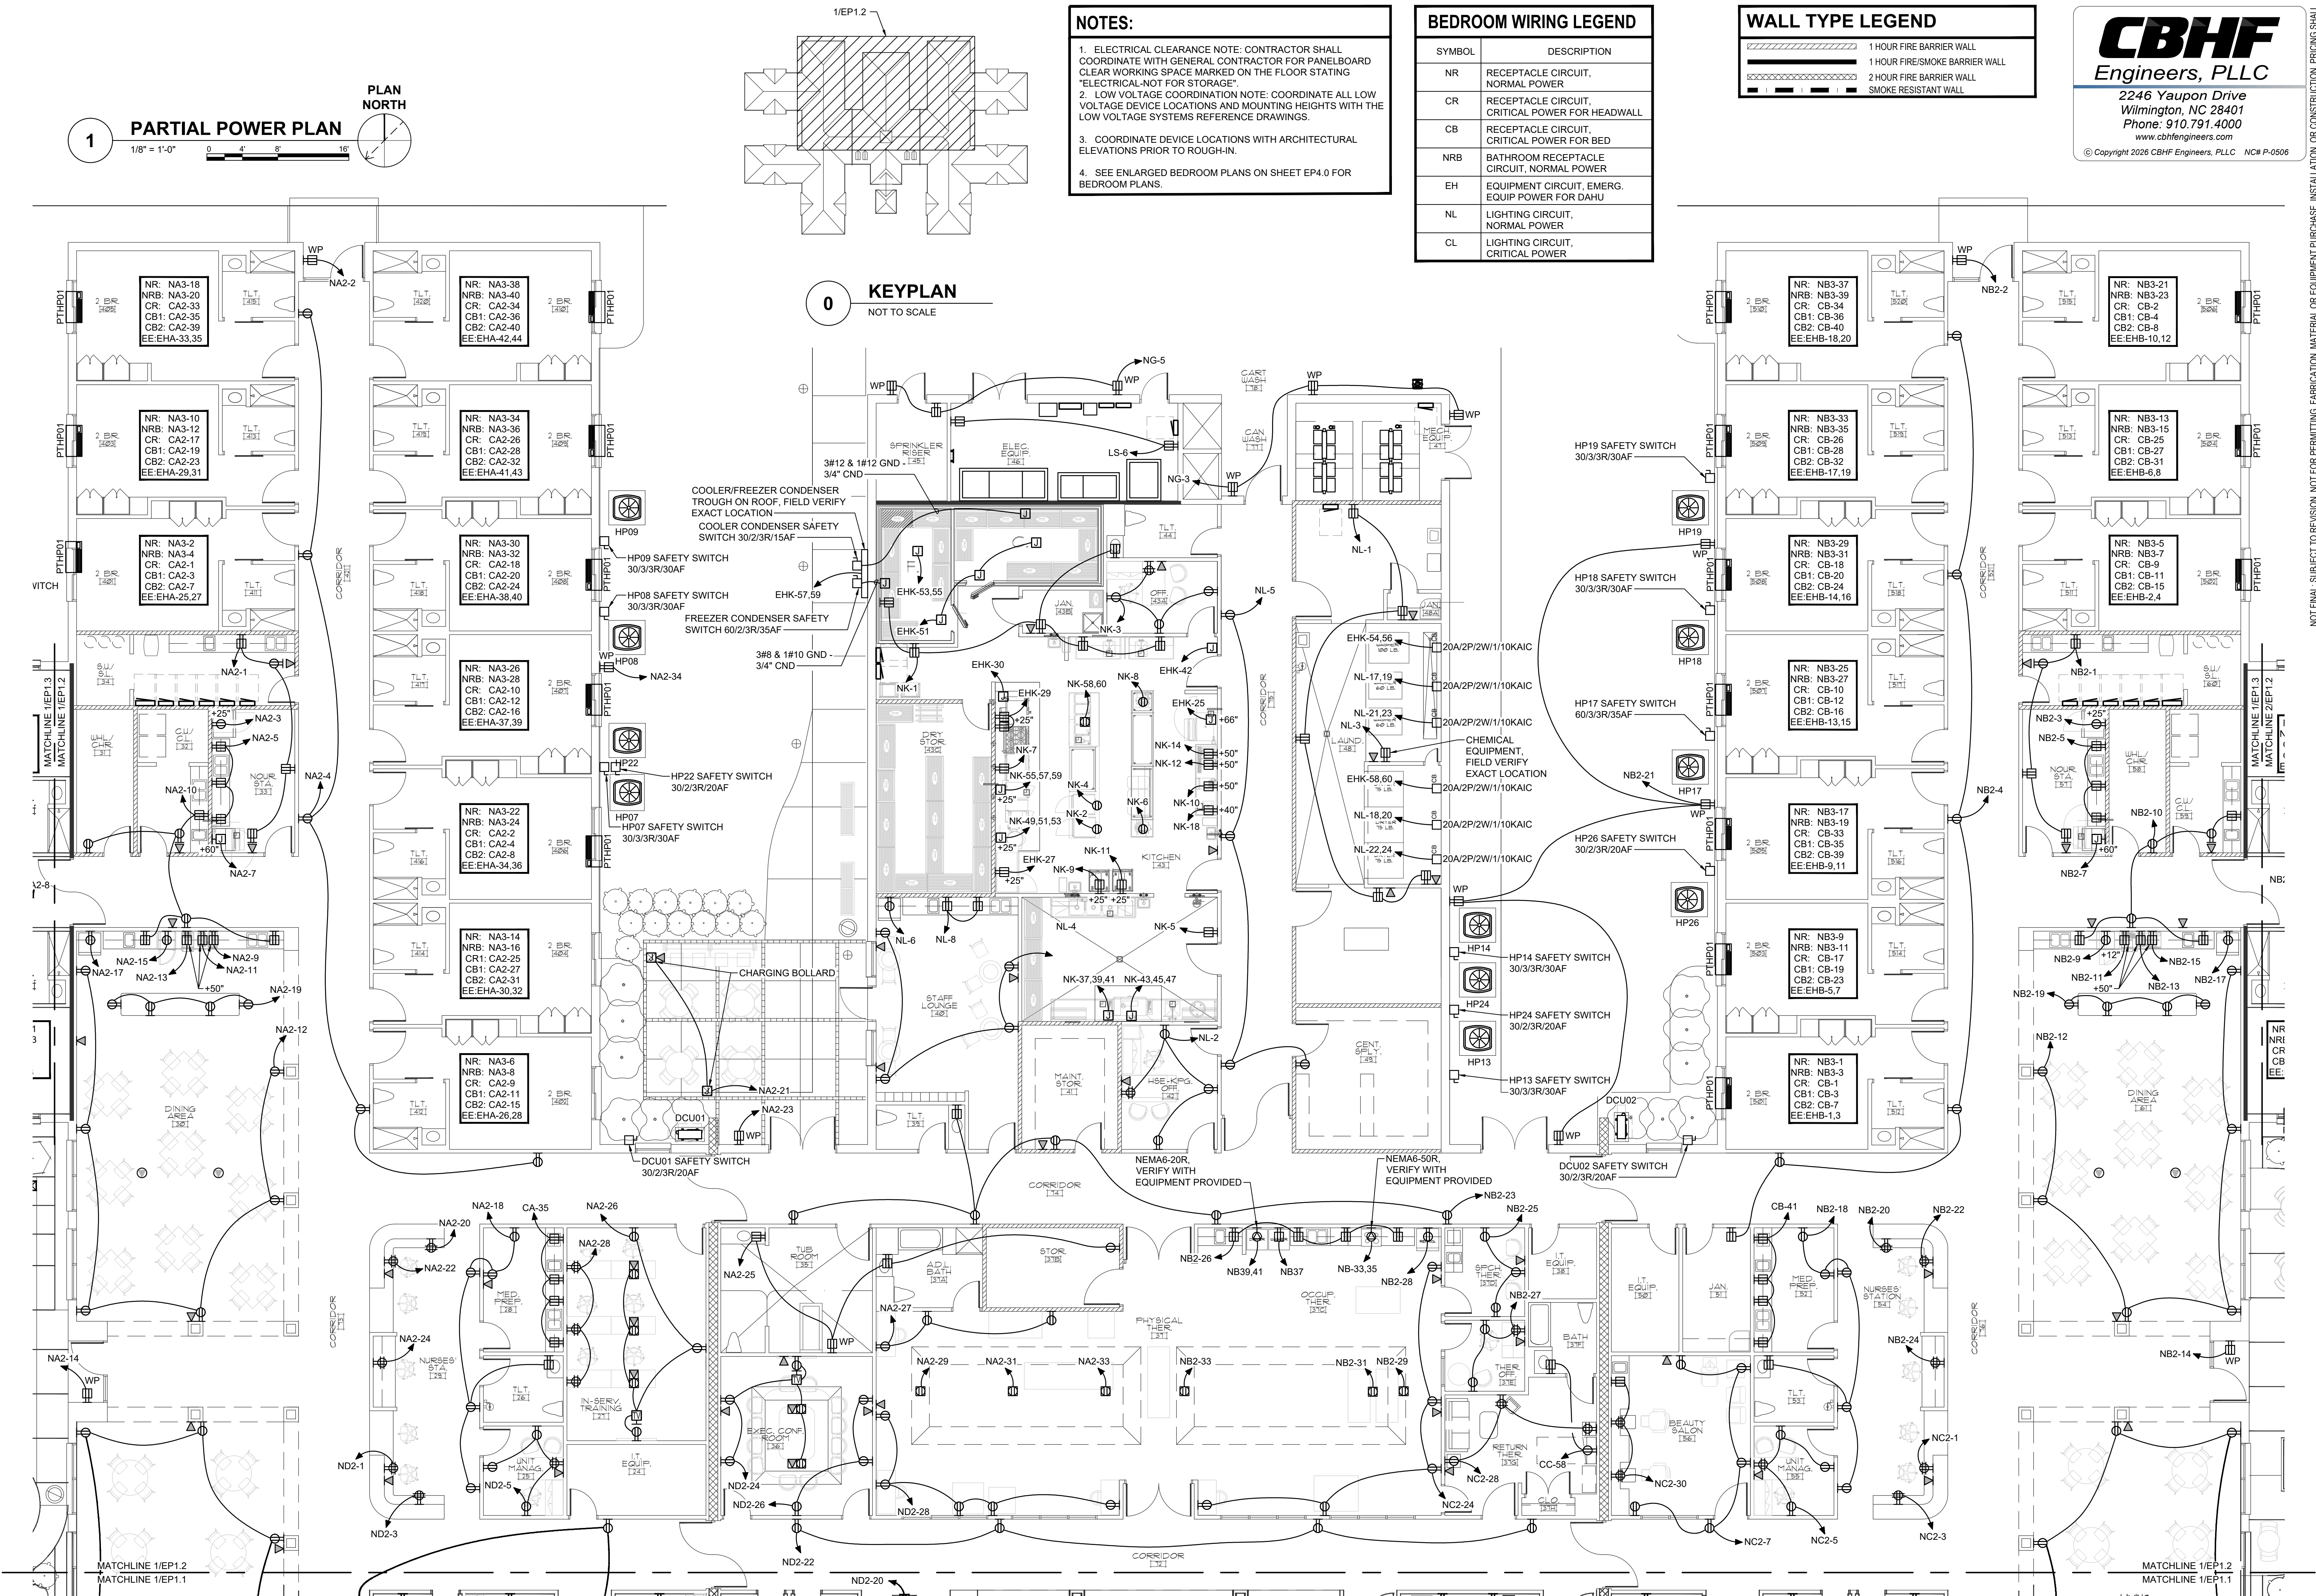

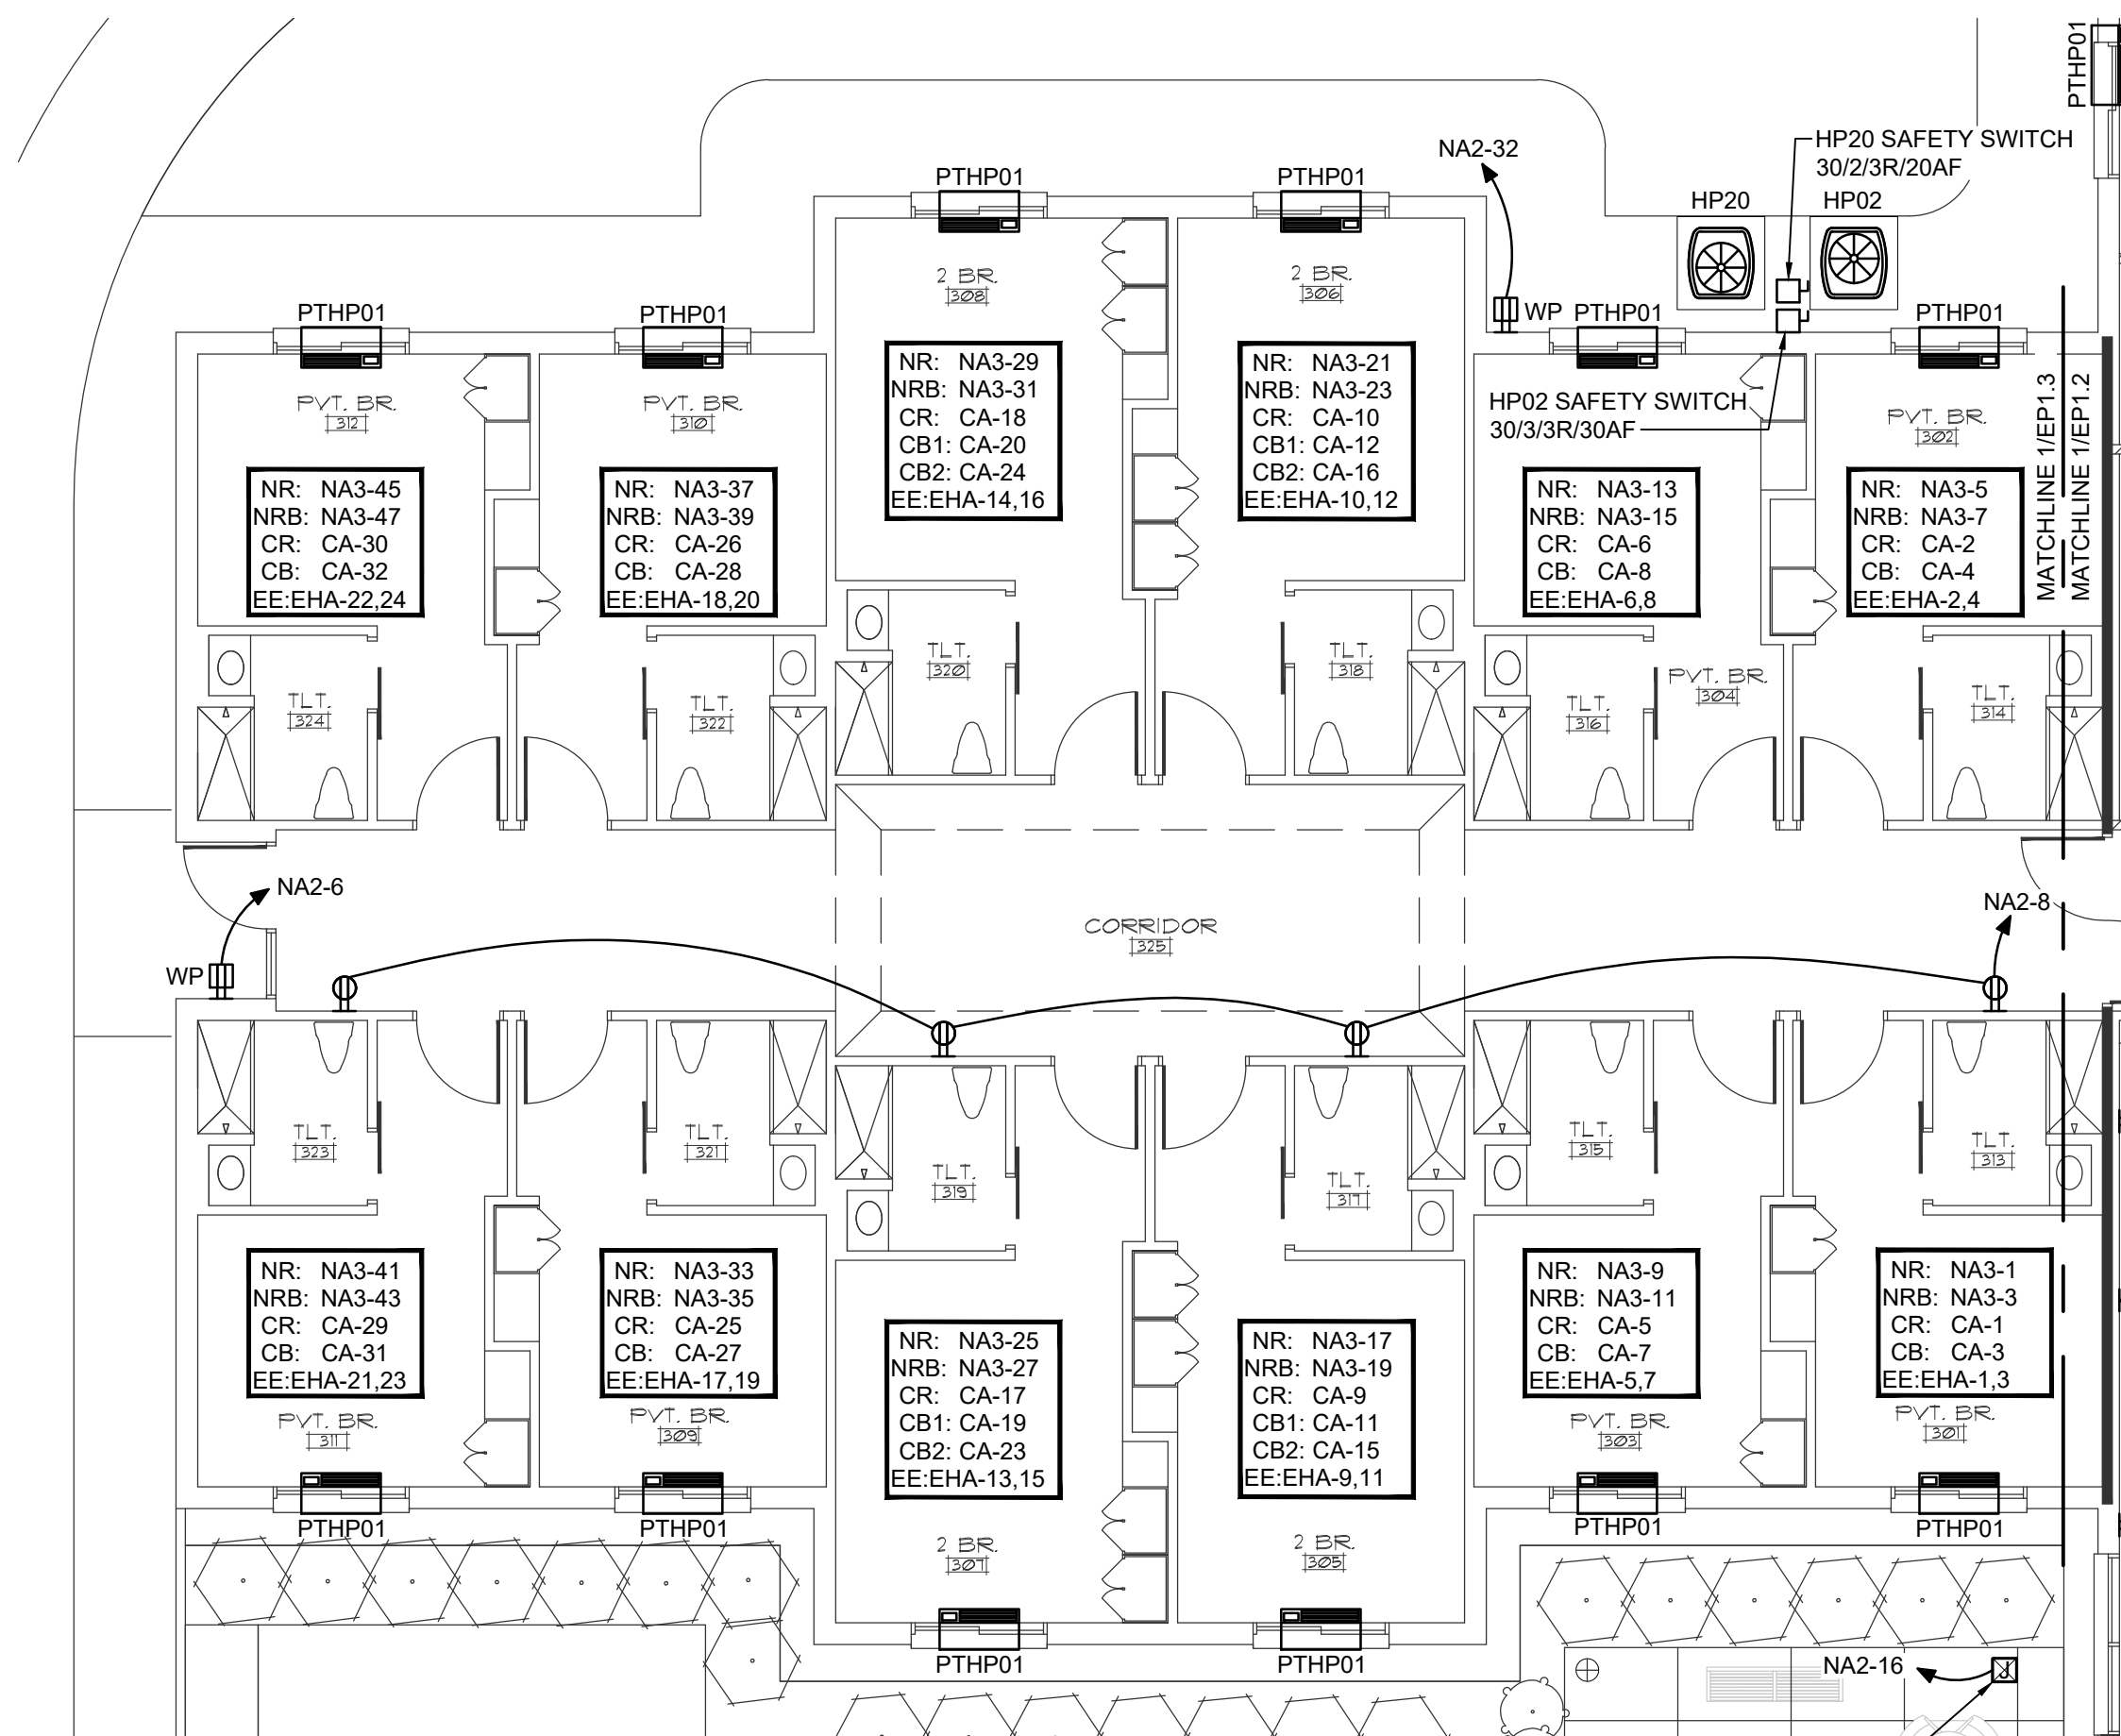


1 PARTIAL POWER PLAN

1/8" = 1'-0"

0 4' 8' 16'

PLAN NORTH

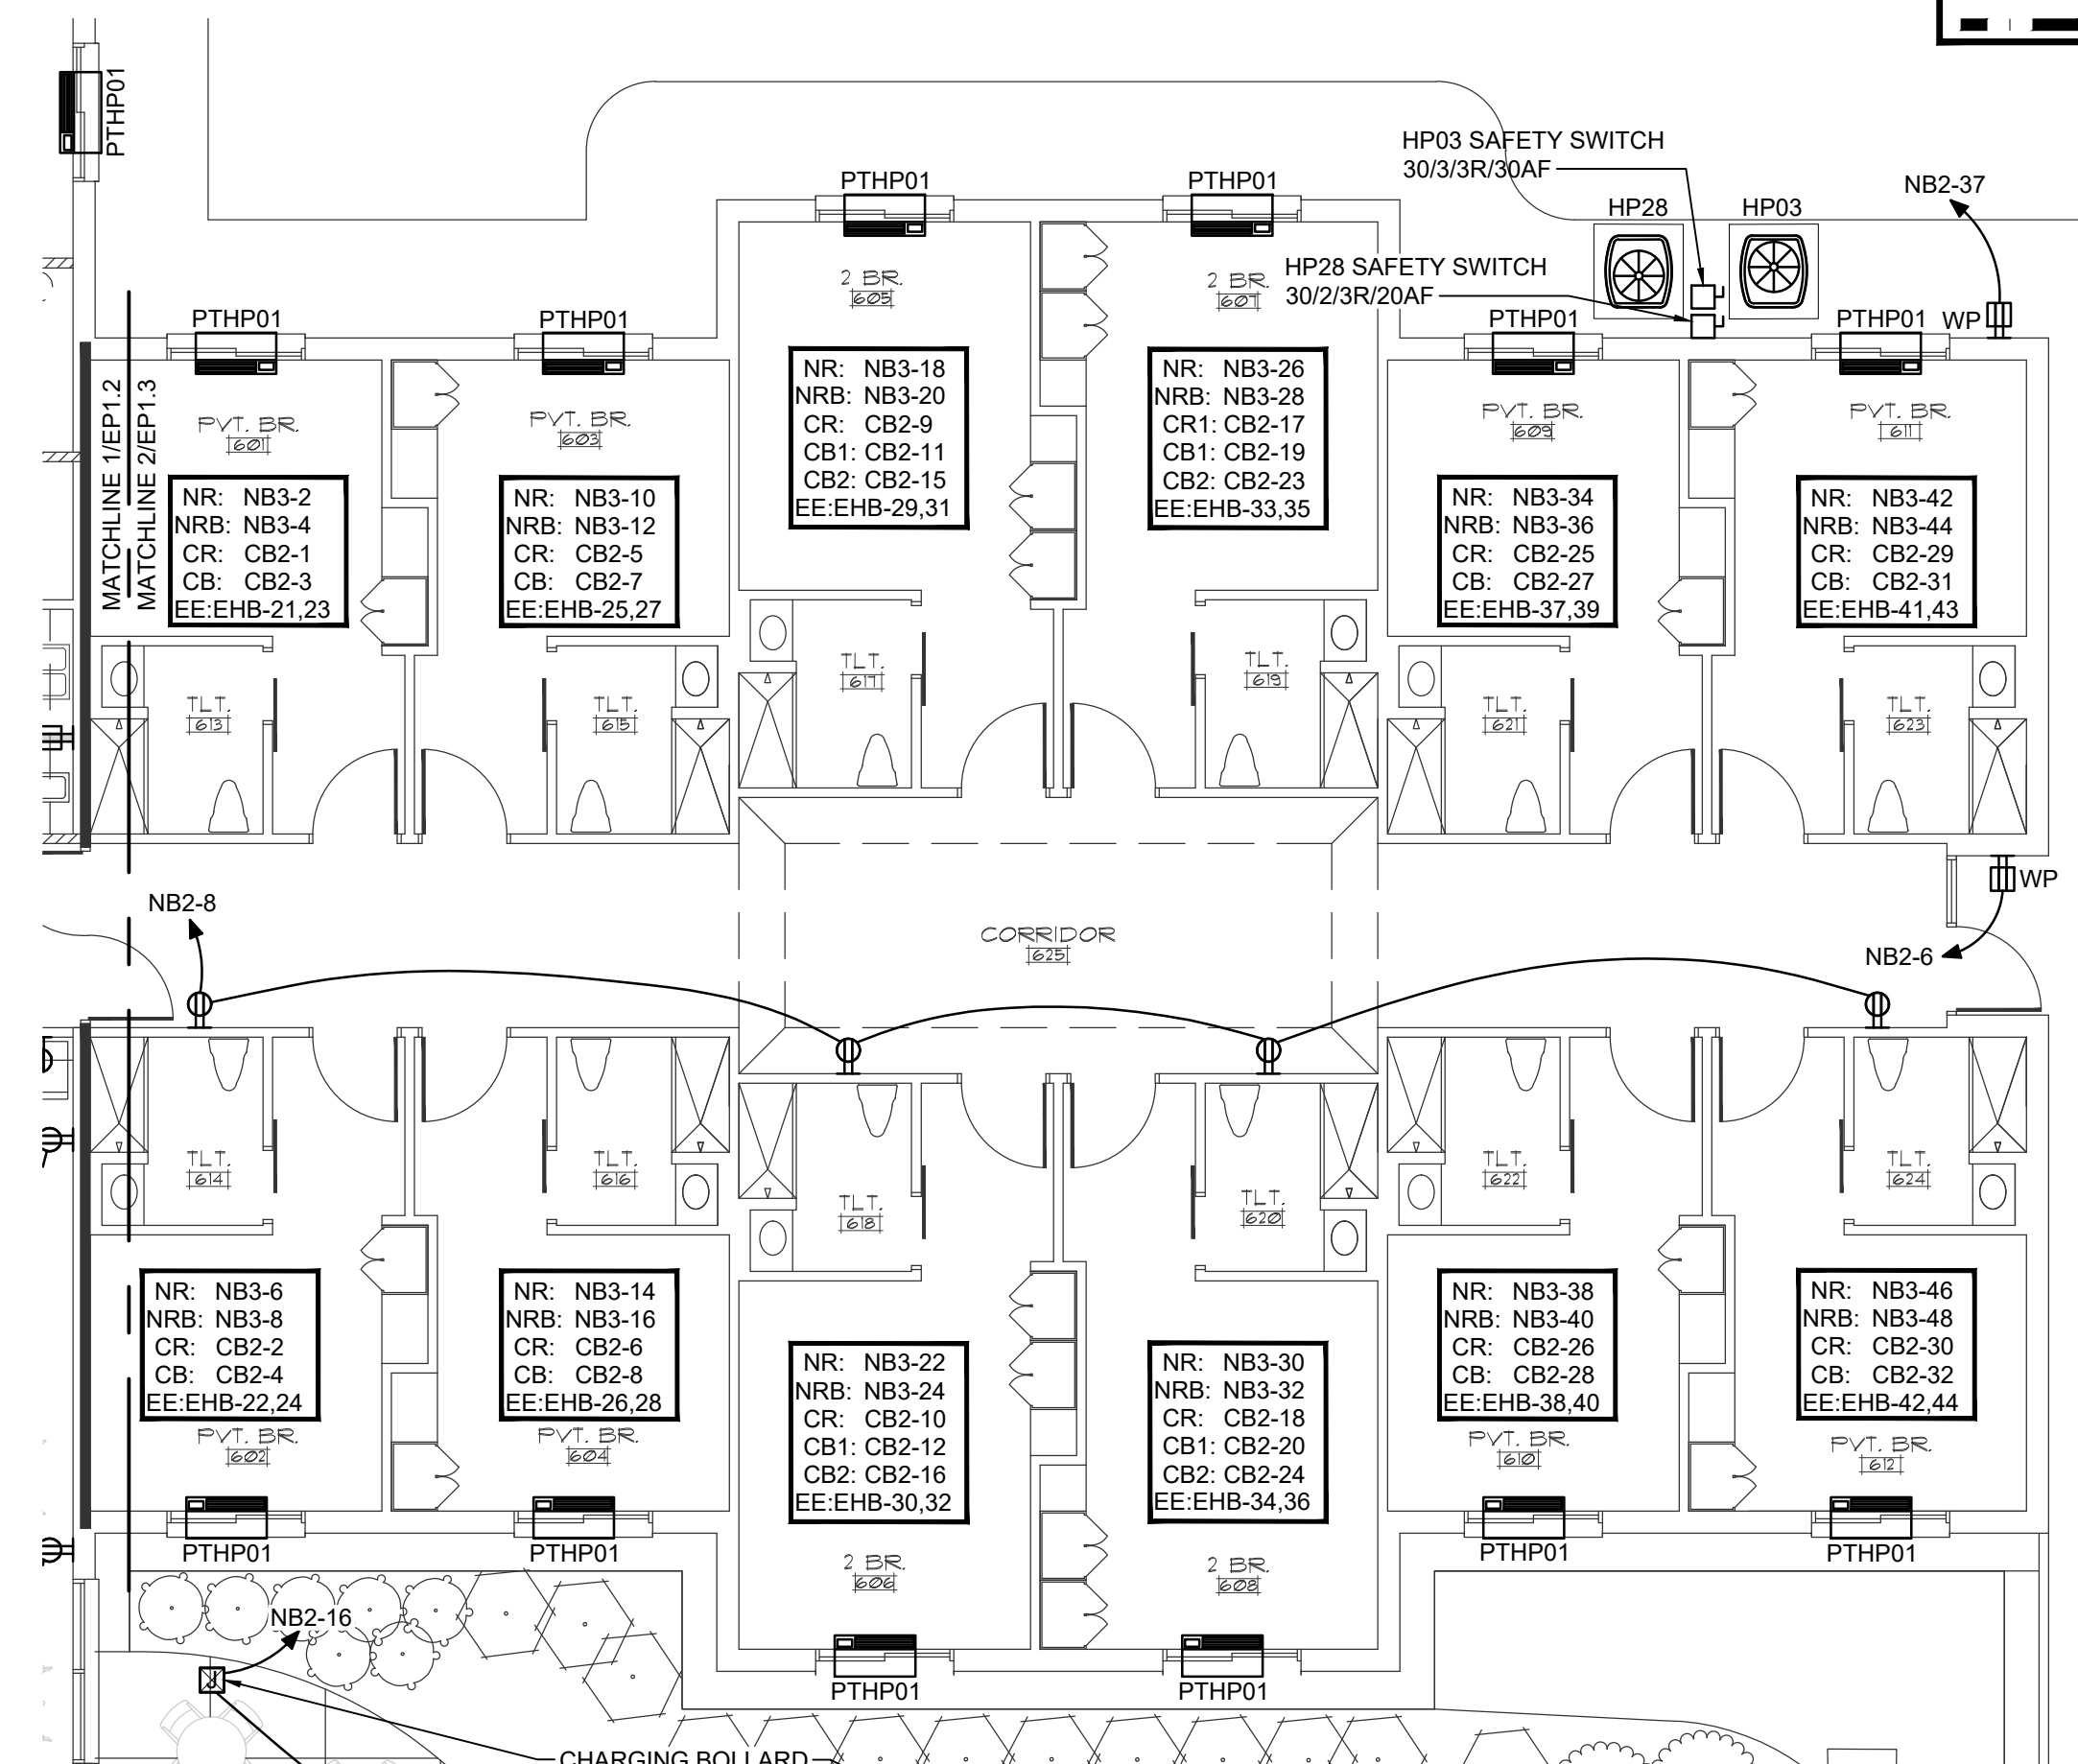


2 PARTIAL POWER PLAN

1/8" = 1'-0"

0 4' 8' 16'

PLAN NORTH

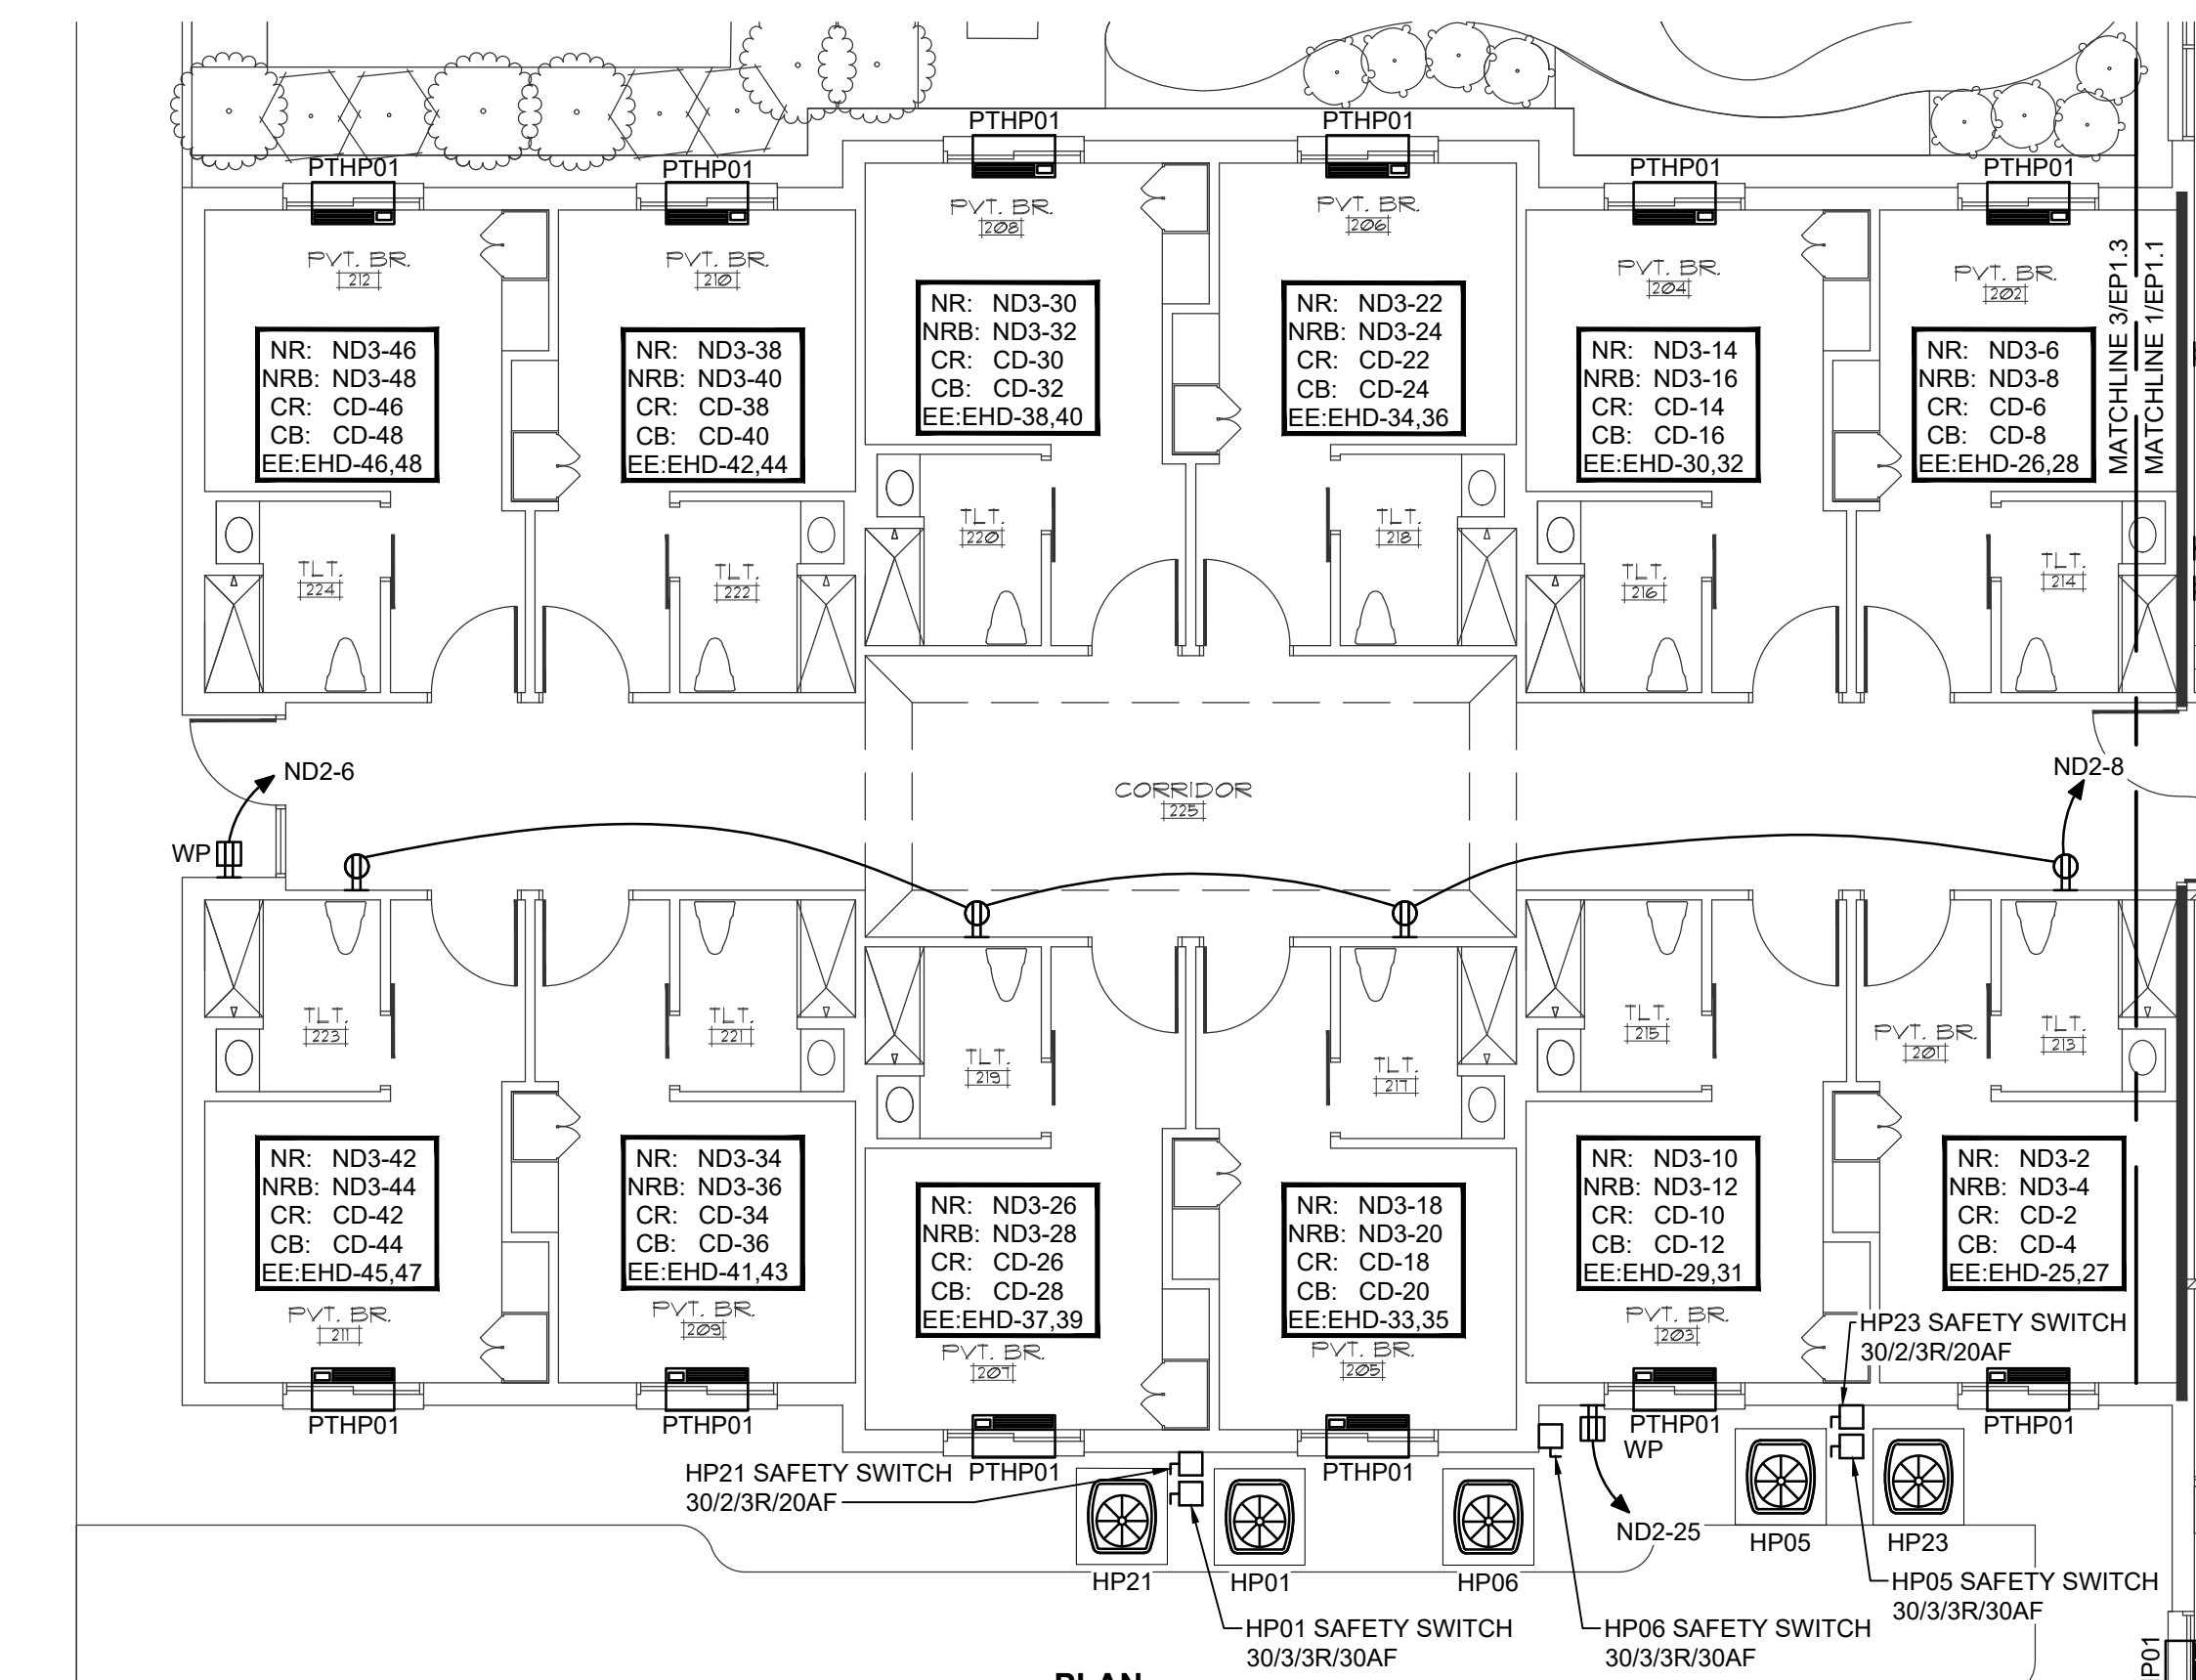


3 PARTIAL POWER PLAN

1/8" = 1'-0"

0 4' 8' 16'

PLAN NORTH

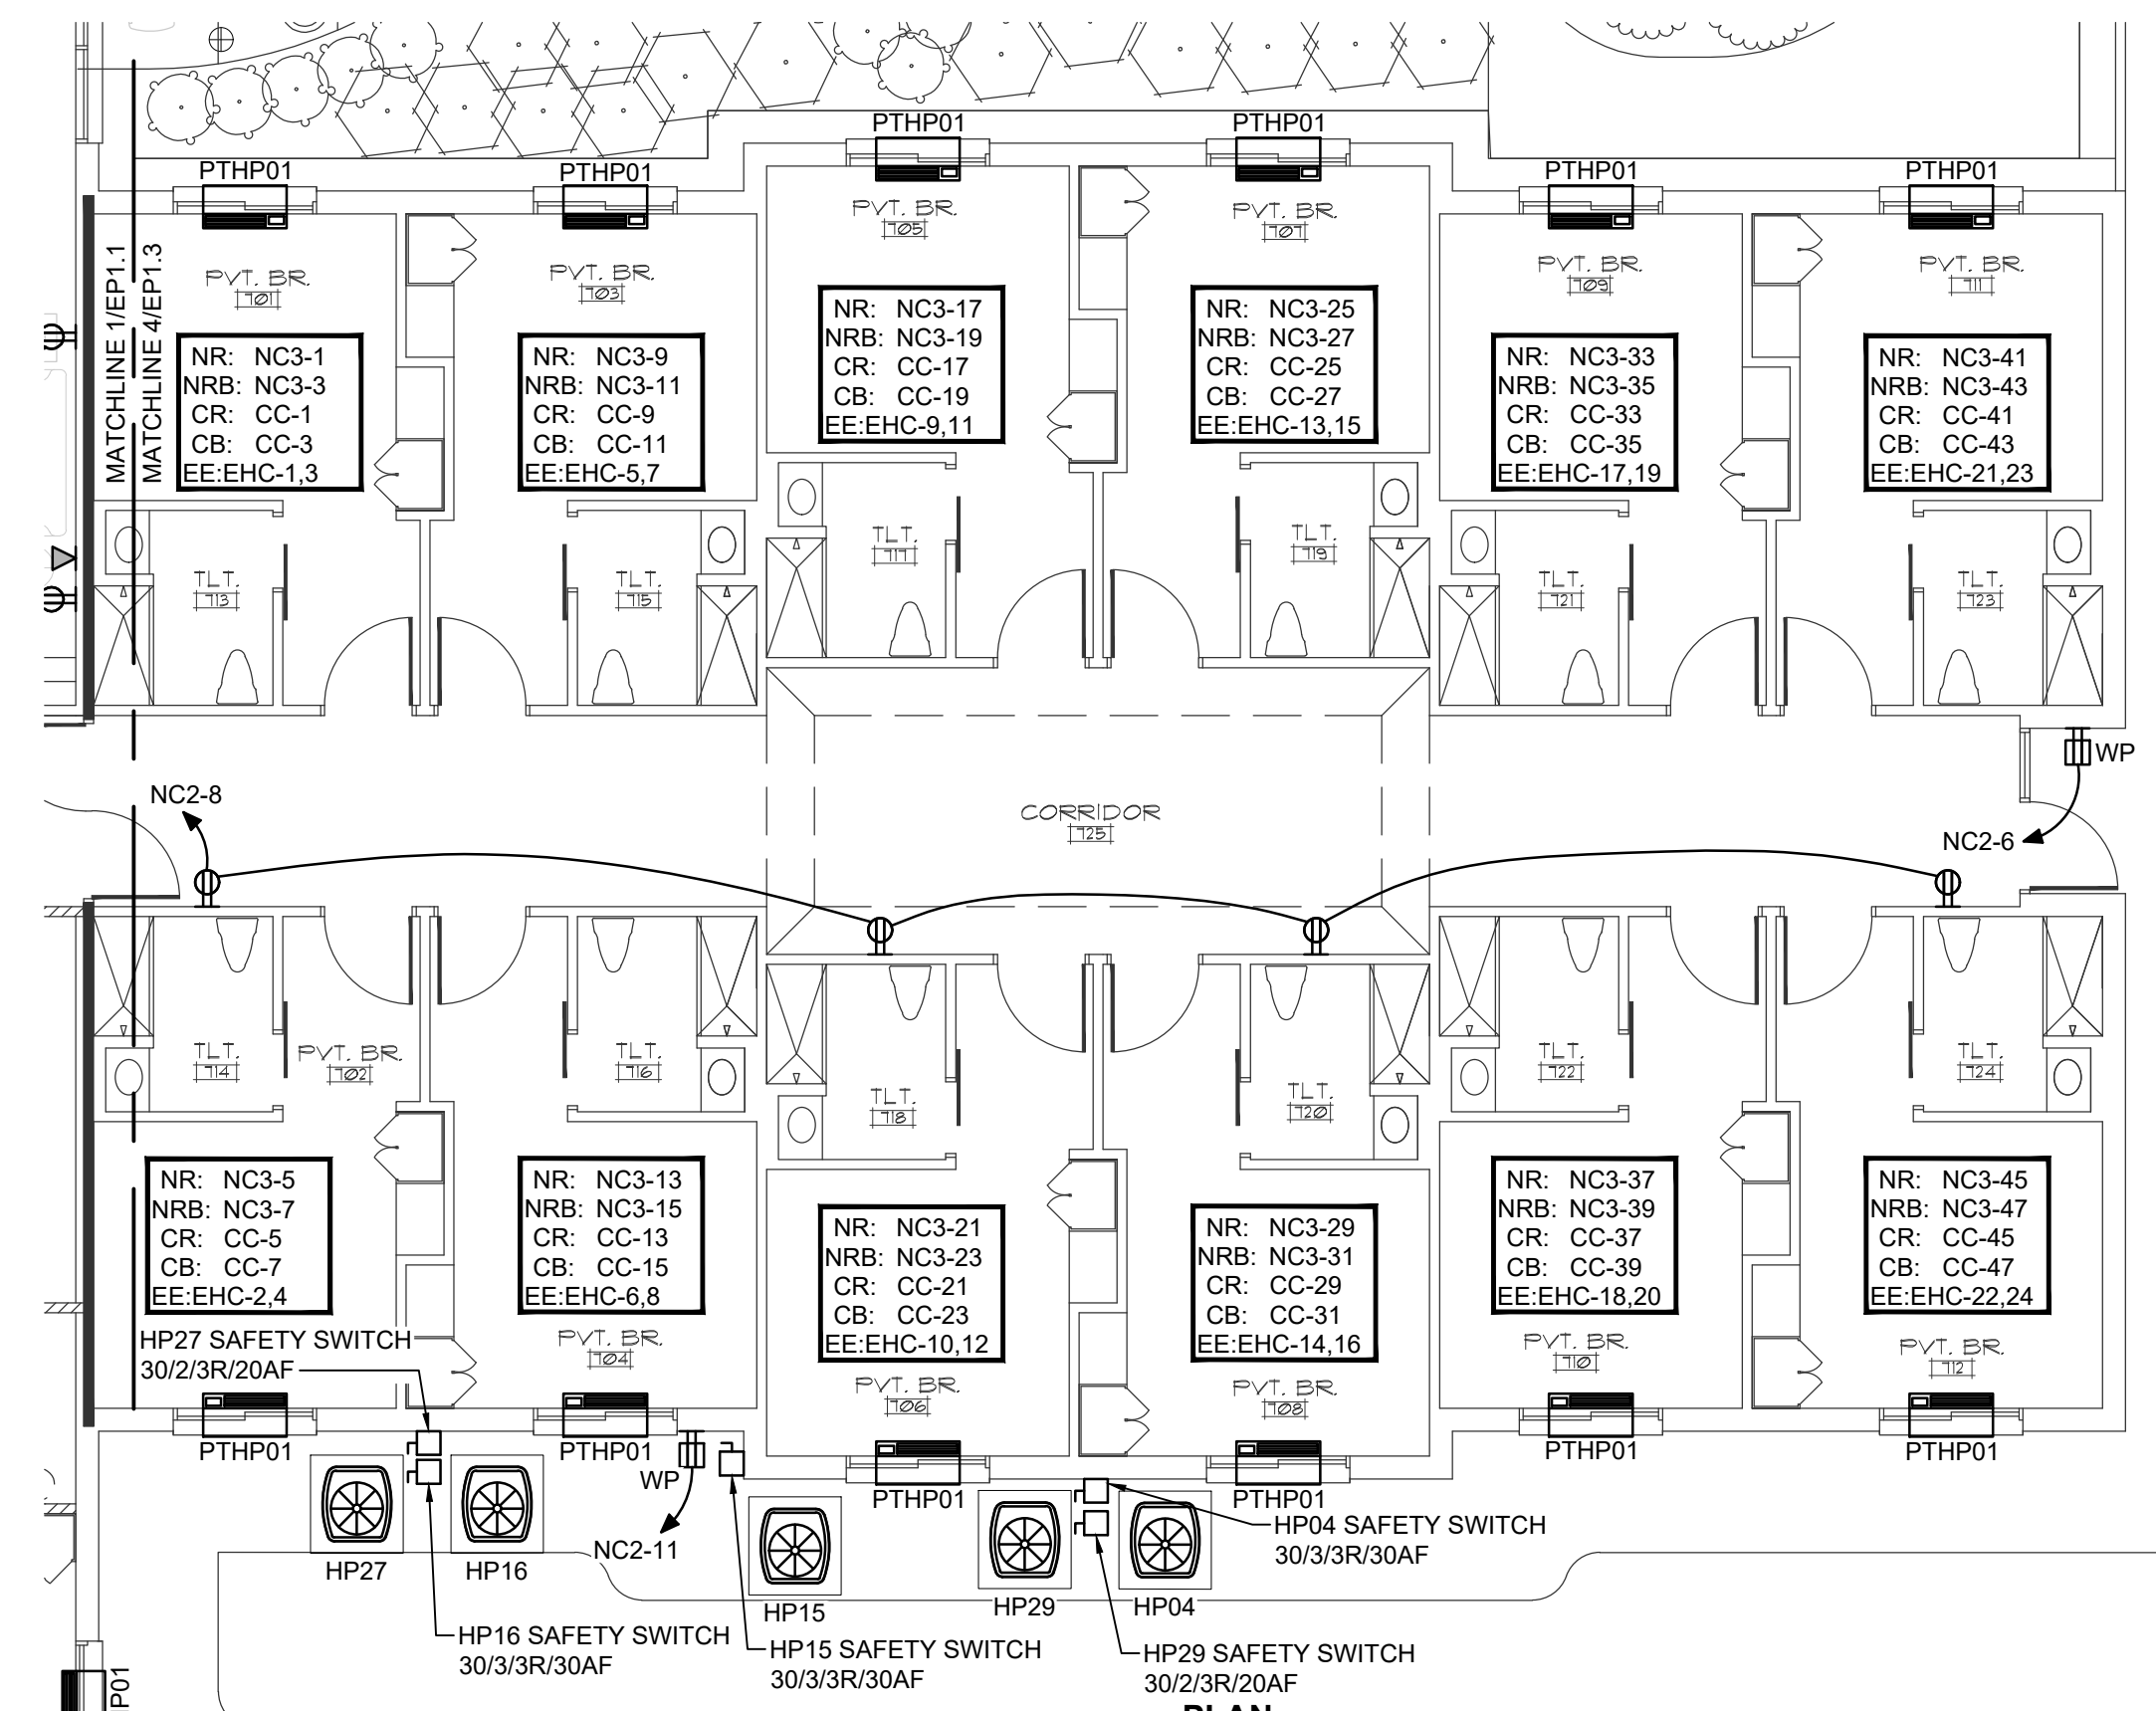


30°/33°/36°/39°/42°
PLAN
NORTH

4 PARTIAL POWER PLAN

1/8" = 1'-0"

0 4' 8' 16'

 WALL TYPE LEGEND

	1 HOUR FIRE BARRIER WALL
	1 HOUR FIRE/SMOKE BARRIER WALL
	2 HOUR FIRE BARRIER WALL
	SMOKE RESISTANT WALL

CBHF
Engineers, PLLC

2246 Yaupon Drive
Wilmington, NC 28401
Phone: 910.791.4000
www.cbhfindengineers.com

© Copyright 2026 CBHF Engineers, PLLC NCH P-0506

PRINCIPLE HEALTH CARE
WAKE COUNTY
Holly Springs, North Carolina

David R. Polston - Architect
3806 Park Ave. Suite C, Wilmington, NC 28403
Architecture Planning Design


120 BED
NURSING FACILITY
ELECTRICAL
PARTIAL POWER PLAN

EP 1.3

BEDROOM WIRING LEGEND	
SYMBOL	DESCRIPTION
NR	RECEPTACLE CIRCUIT, NORMAL POWER
CR	RECEPTACLE CIRCUIT, CRITICAL POWER FOR HEADWALL
CB	RECEPTACLE CIRCUIT, CRITICAL POWER FOR BED
NRB	BATHROOM RECEPTACLE CIRCUIT, NORMAL POWER
EH	EQUIPMENT CIRCUIT, EMERG. EQUIP POWER FOR DAHU
NL	LIGHTING CIRCUIT, NORMAL POWER
CL	LIGHTING CIRCUIT, CRITICAL POWER

NOTES:

1. ELECTRICAL CLEARANCE NOTE: CONTRACTOR SHALL COORDINATE WITH GENERAL CONTRACTOR FOR PANELBOARD CLEAR WORKING SPACE MARKED ON THE FLOOR STATING "ELECTRICAL-NOT FOR STORAGE"
2. LOW VOLTAGE COORDINATION NOTE: COORDINATE ALL LOW VOLTAGE DEVICE LOCATIONS AND MOUNTING HEIGHTS WITH THE LOW VOLTAGE SYSTEMS REFERENCE DRAWINGS.
3. COORDINATE DEVICE LOCATIONS WITH ARCHITECTURAL ELEVATIONS PRIOR TO ROUGH-IN.
4. SEE ENLARGED BEDROOM PLANS ON SHEET EP4.0 FOR BEDROOM PLANS.

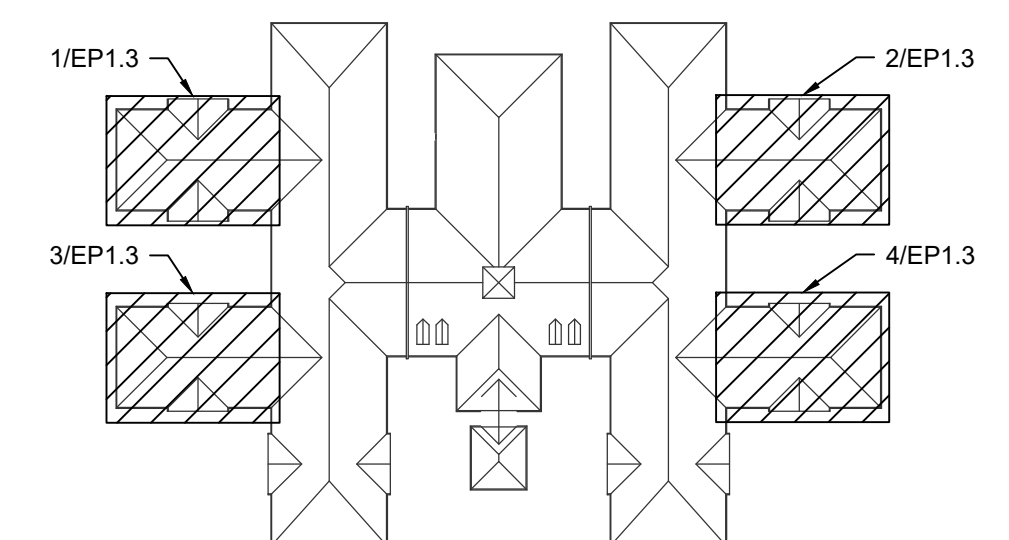

0 KEYPLAN
NOT TO SCALE

WALL TYPE LEGEND	
	1 HOUR FIRE BARRIER WALL
	1 HOUR FIRE/SMOKE BARRIER WALL
	2 HOUR FIRE BARRIER WALL
	SMOKE RESISTANT WALL

CBHF
Engineers, PLLC

2246 Yaupon Drive
Wilmington, NC 28401
Phone: 910.791.4000
www.cbhfengineers.com

© Copyright 2026 CBHF Engineers, PLLC NC# P-0506



PRINCIPLE HEALTH CARE
WAKE COUNTY

Holly Springs, North Carolina

David R. Polston - Architect

3806 Park Ave. Suite C, Wilmington, NC 28403
Architecture Planning Design

120 BED
NURSING FACILITY
ELECTRICAL
ROOF POWER PLAN



EP
1.4

NOT FINAL SUBJECT TO REVISION. NOT FOR PERMITTING. FABRICATION, MATERIAL OR EQUIPMENT PURCHASE, INSTALLATION, OR CONSTRUCTION PRICING SHALL STATE ALL ASSUMPTIONS, EXCLUSIONS, ALLOWANCES, AND CONTINGENCIES AND SHALL BE RECONCILED WITH THE FINAL SIGNED AND SEALED DOCUMENTS.

- KITCHEN HOOD ELECTRICAL COORDINATION NOTES
1. THE KITCHEN HOODS BASIS OF DESIGN IS CAPTIVEAIRE, REFERENCE JOB NUMBER 8326937. HOODS ARE PROVIDED AND INSTALLED BY THE MECHANICAL CONTRACTOR. THE ELECTRICAL CONTRACTOR SHALL COORDINATE ELECTRICAL WORK REQUIRED BY THE HOODS WITH THE MECHANICAL AND GENERAL CONTRACTORS.


2. CONTRACTOR IS RESPONSIBLE TO OBTAIN THE MOST RECENT CAPTIVEAIRE DRAWINGS FROM THE OWNER. CAPTIVEAIRE DRAWINGS SHALL BE CONSIDERED AN ESSENTIAL COMPONENT OF THE CONTRACT DOCUMENTS. SOME ELECTRICAL WORK SHOWN ON THESE DRAWINGS IS INTENTIONALLY NOT DUPLICATED ON THE ELECTRICAL DRAWINGS. THE CONTRACTOR SHALL PROVIDE, AS PART OF THIS CONTRACT, SOURCES OF POWER; POWER, CONTROL AND COMMUNICATIONS CONDUCTORS, CABLES AND RACEWAYS; EMPTY RACEWAYS; JUNCTION, OUTLET AND PULL BOXES; MOUNTING HARDWARE; FINAL CONNECTIONS; CONNECTION HARDWARE; TESTING AND TESTING SUPPORT; ETC., FOR THE CAPTIVEAIRE EQUIPMENT AS SHOWN ON THE CONTRACT DRAWINGS AND THE CAPTIVEAIRE DOCUMENTS.

3. THE CONTRACTOR IS CAUTIONED TO THOROUGHLY REVIEW BOTH THE CONTRACT DRAWINGS AND THE CAPTIVEAIRE DRAWINGS PRIOR TO SUBMITTING A BID. ELECTRICAL ITEMS SHOWN AND/OR NOTED ON THESE DRAWINGS TO BE PROVIDED BY THE "ELECTRICIAN" OR SIMILAR TERM SHALL BE PROVIDED BY THE CONTRACTOR AND SHALL BE CONSIDERED AS BINDING AS MATERIAL, EQUIPMENT AND LABOR SHOWN ON THE CONTRACT DRAWINGS. NO EXTRAS WILL BE CONSIDERED OR APPROVED FOR ITEMS SHOWN ON EITHER DRAWINGS TO BE PROVIDED BY THE CONTRACTOR. INSTALLATION OF CERTAIN MATERIALS FURNISHED BY CAPTIVEAIRE AS NOTED ON THESE REFERENCE DRAWINGS IS ALSO THE RESPONSIBILITY OF THE CONTRACTOR.

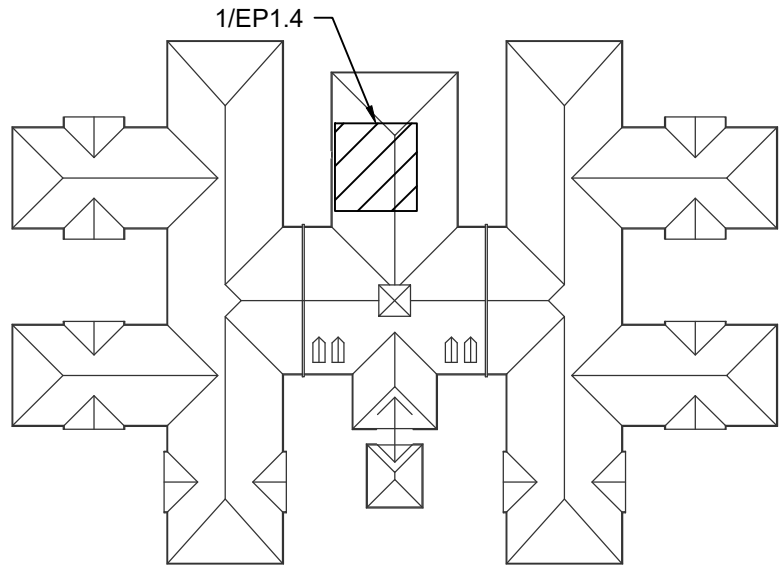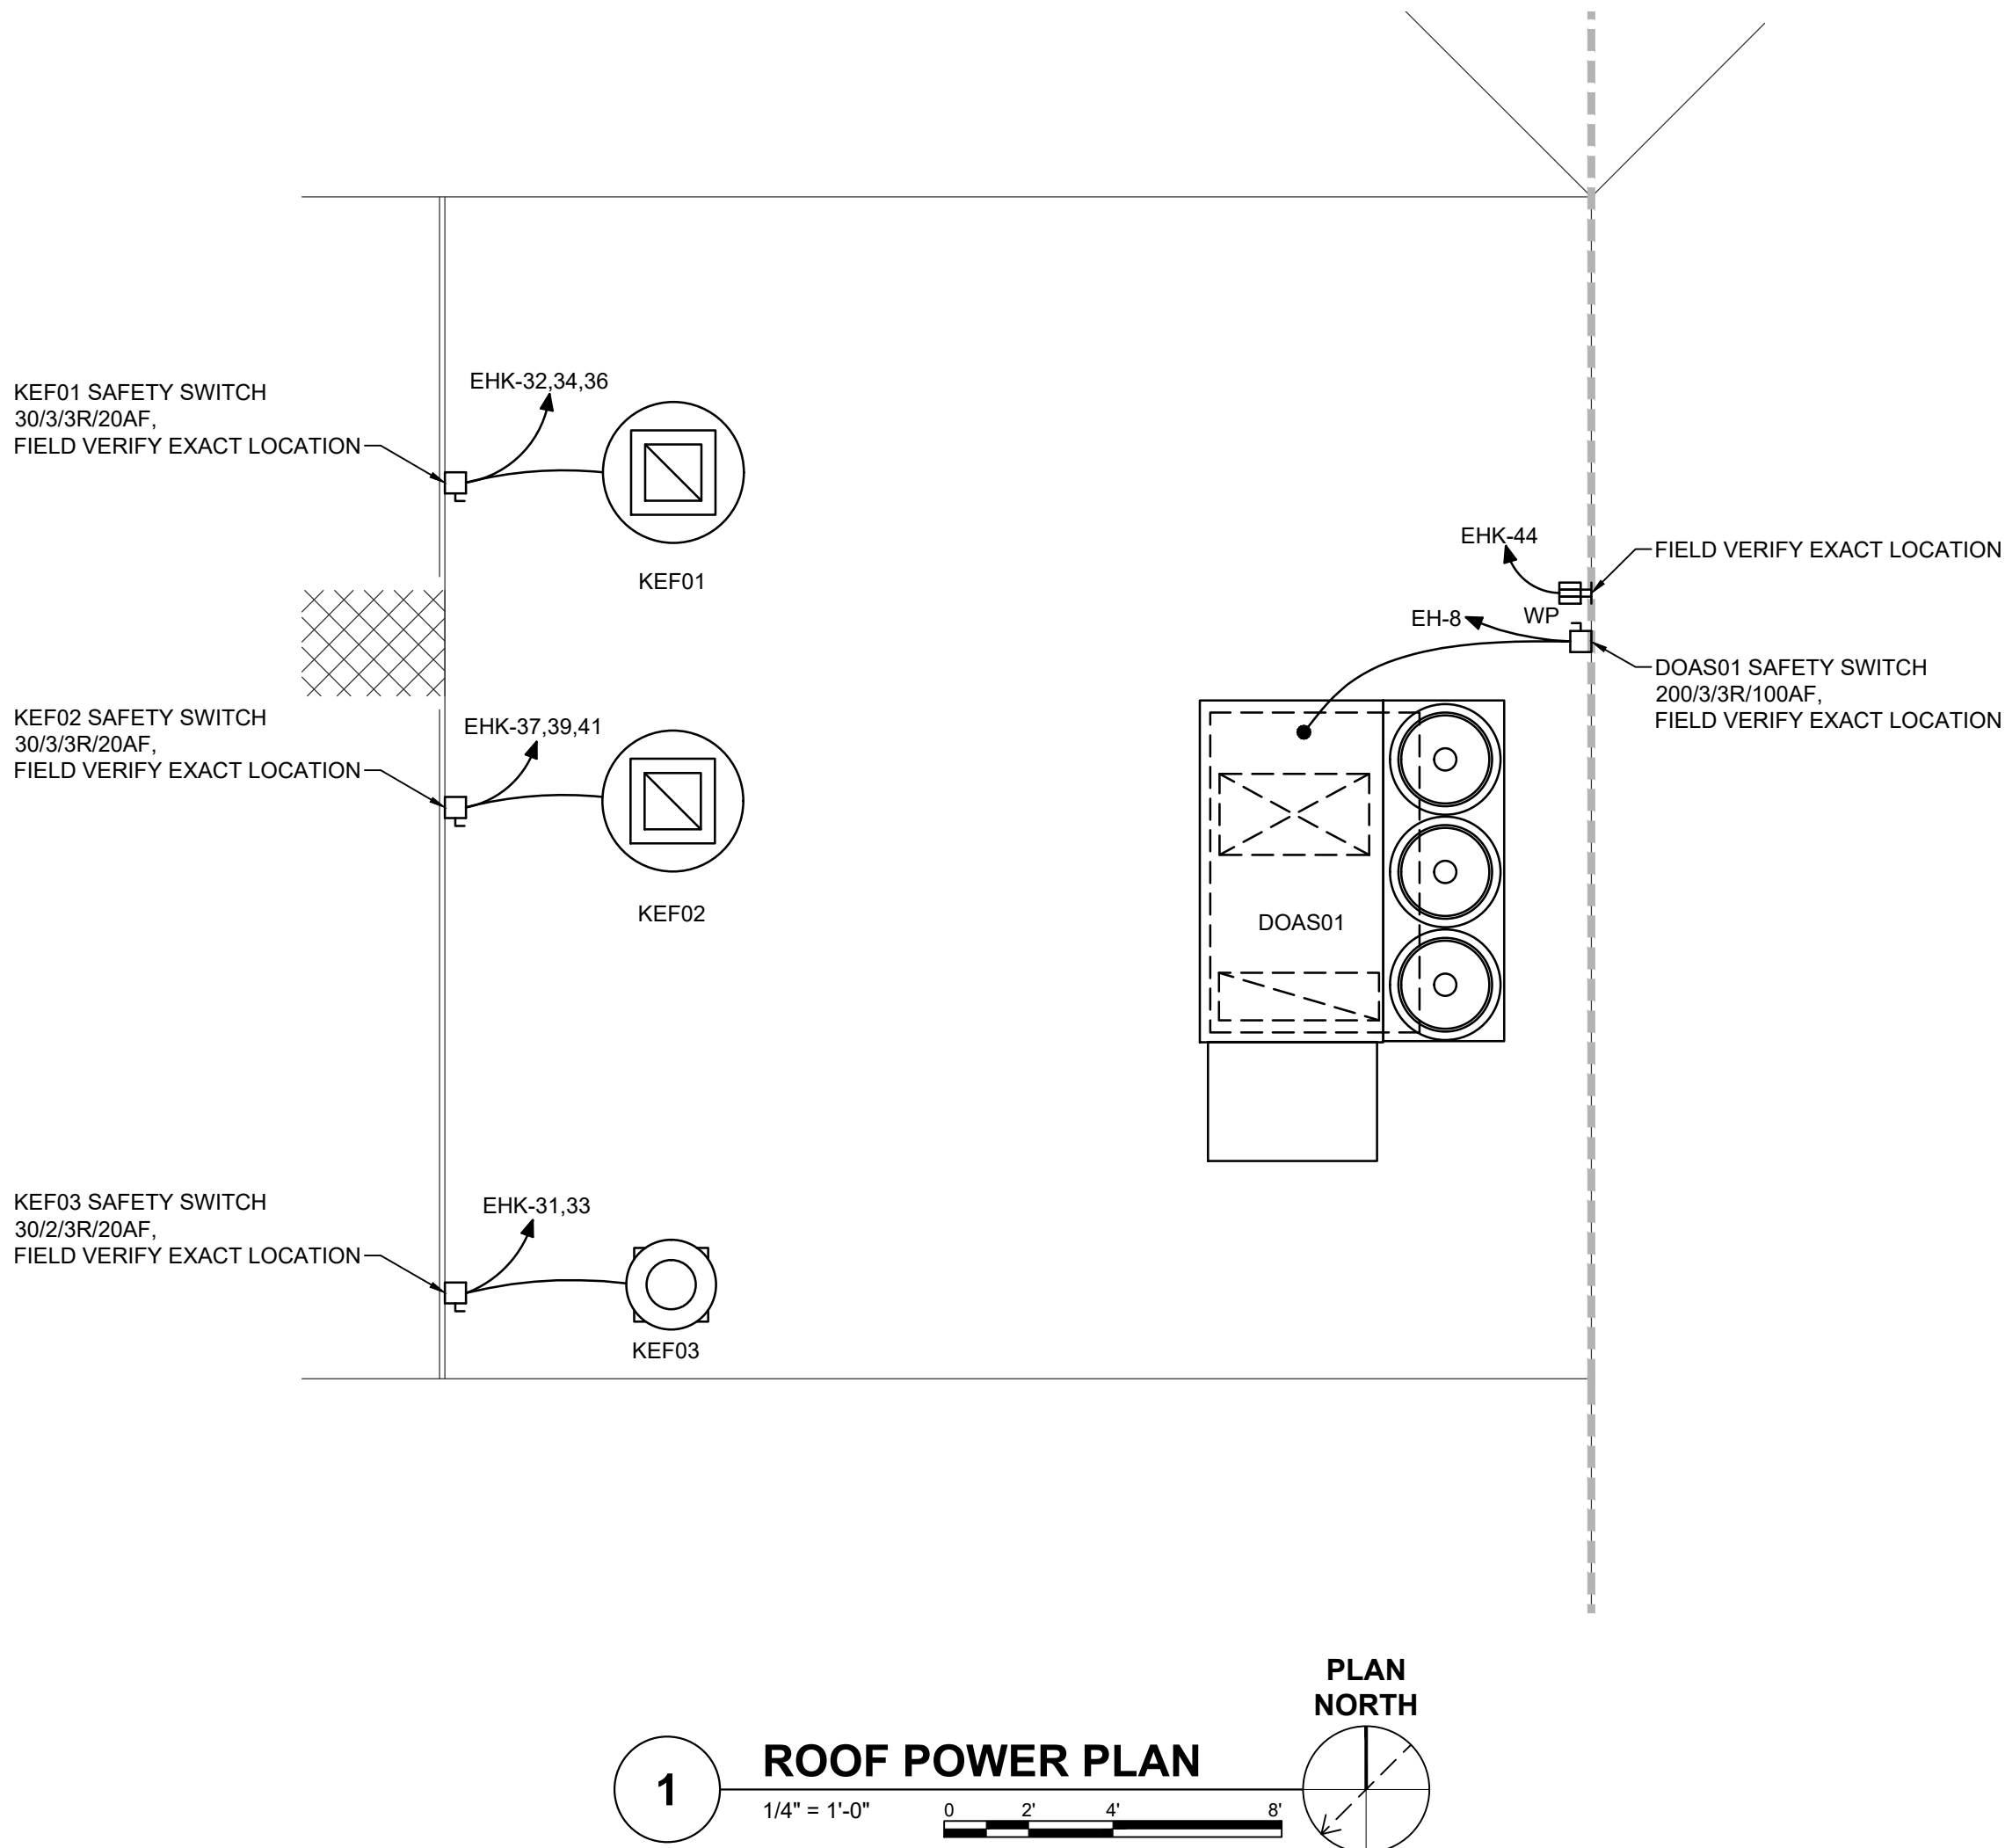


0

KEYPLAN
NOT TO SCALE

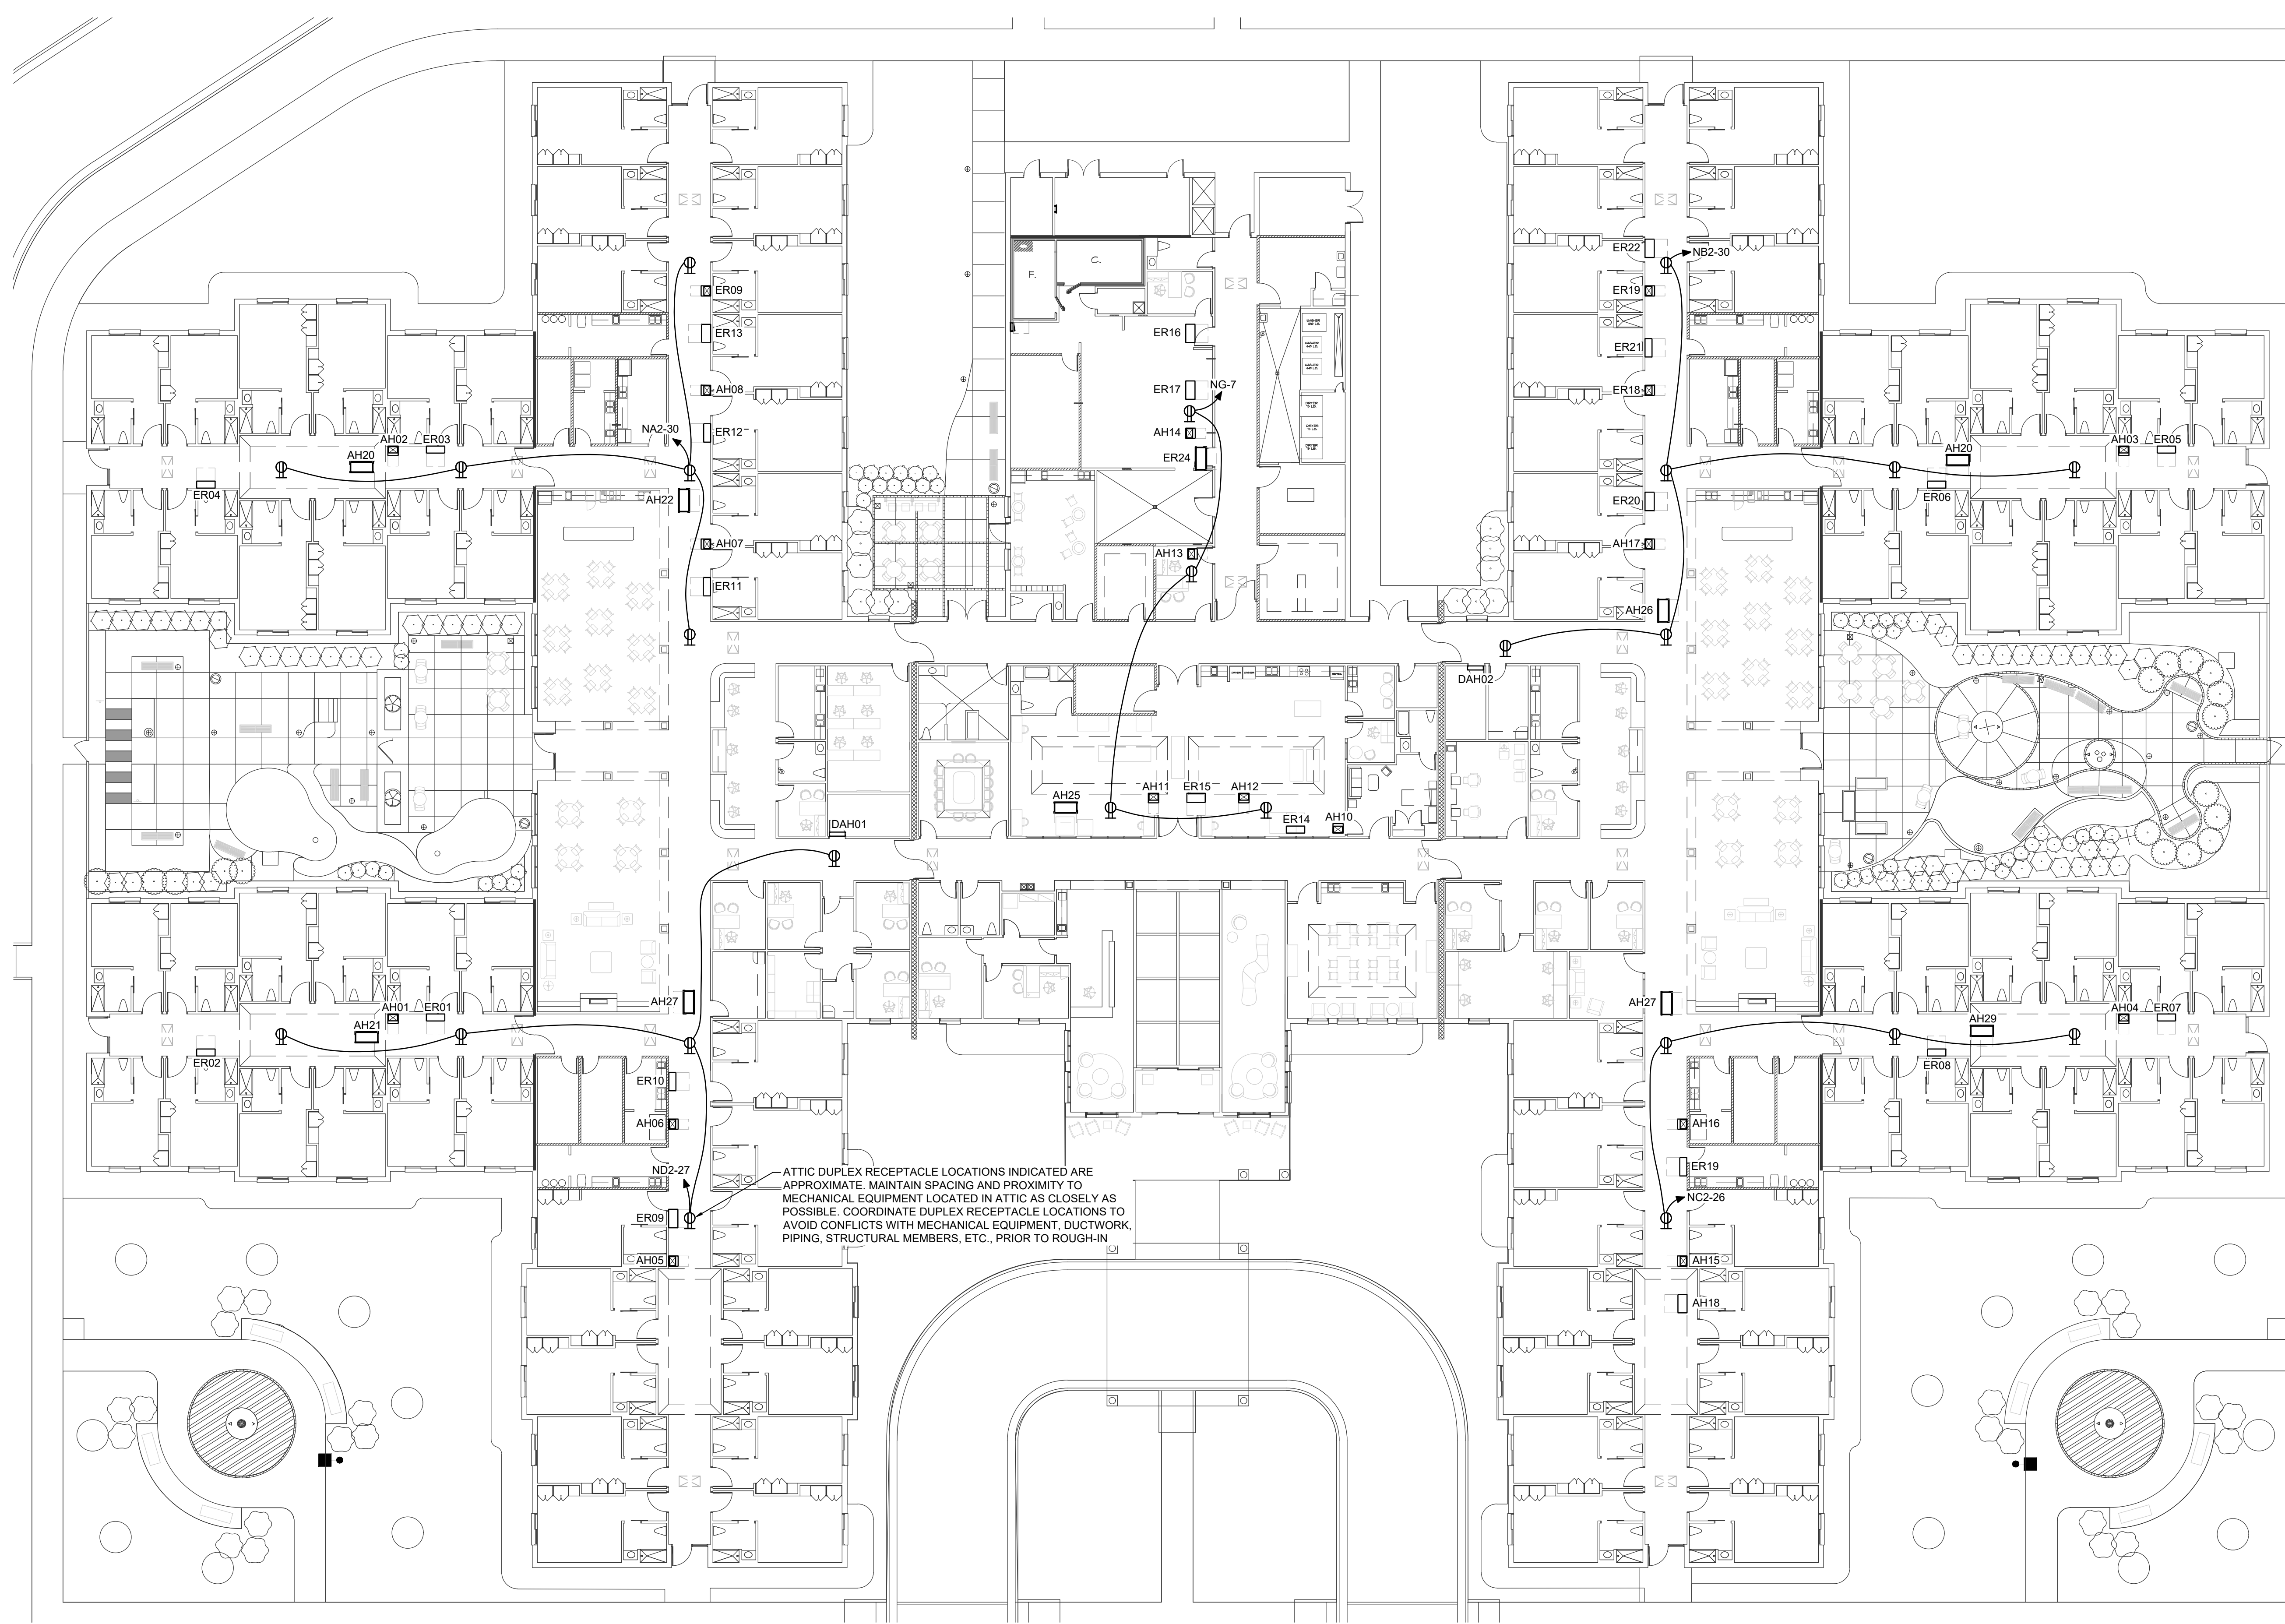

WALL TYPE LEGEND	
	1 HOUR FIRE BARRIER WALL
	1 HOUR FIRE/SMOKE BARRIER WALL
	2 HOUR FIRE BARRIER WALL
	SMOKE RESISTANT WALL

CBHF
Engineers, PLLC
2246 Yaupon Drive
Wilmington, NC 28401
Phone: 910.791.4000
www.cbhfengineers.com
© Copyright 2026 CBHF Engineers, PLLC NC# P-0506

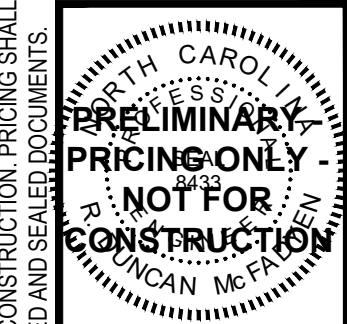

**PRINCIPLE HEALTH CARE
WAKE COUNTY**
Holly Springs, North Carolina


David R. Polston - Architect
3806 Park Ave. Suite C, Wilmington, NC 28403
Architecture Planning Design

120 BED
NURSING FACILITY
ELECTRICAL
ATTIC POWER PLAN


**EP
1.5**

1
1/16" = 1'-0"
0 8' 16' 32'
PLAN NORTH


NOTE: SEE MECHANICAL EQUIPMENT CONNECTION SCHEDULE ON SHEET E0.5 FOR CONDUIT/ WIRE SIZE AND DISCONNECT SWITCH REQUIREMENTS, TYPICAL

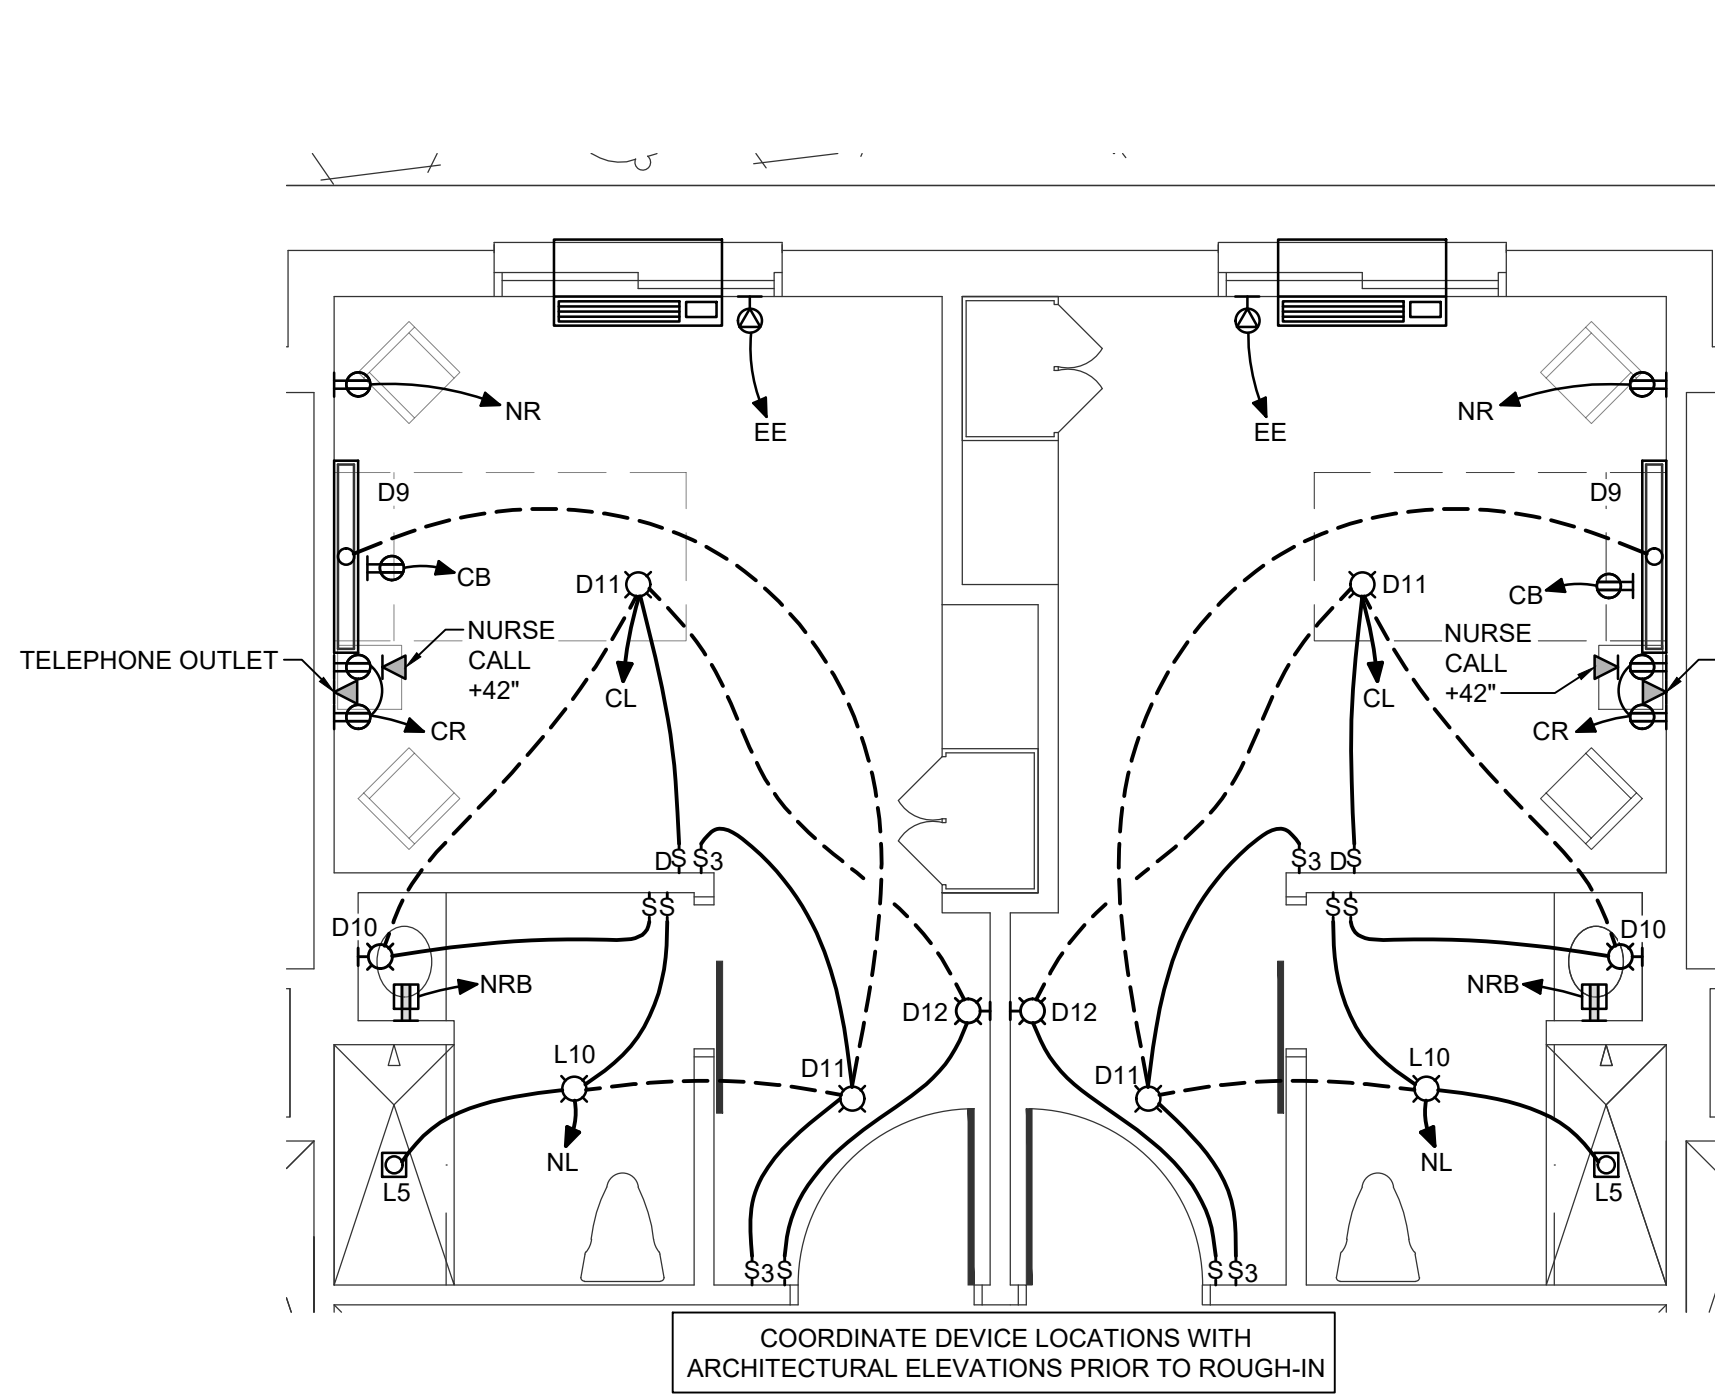


1
1/4" = 1'-0"

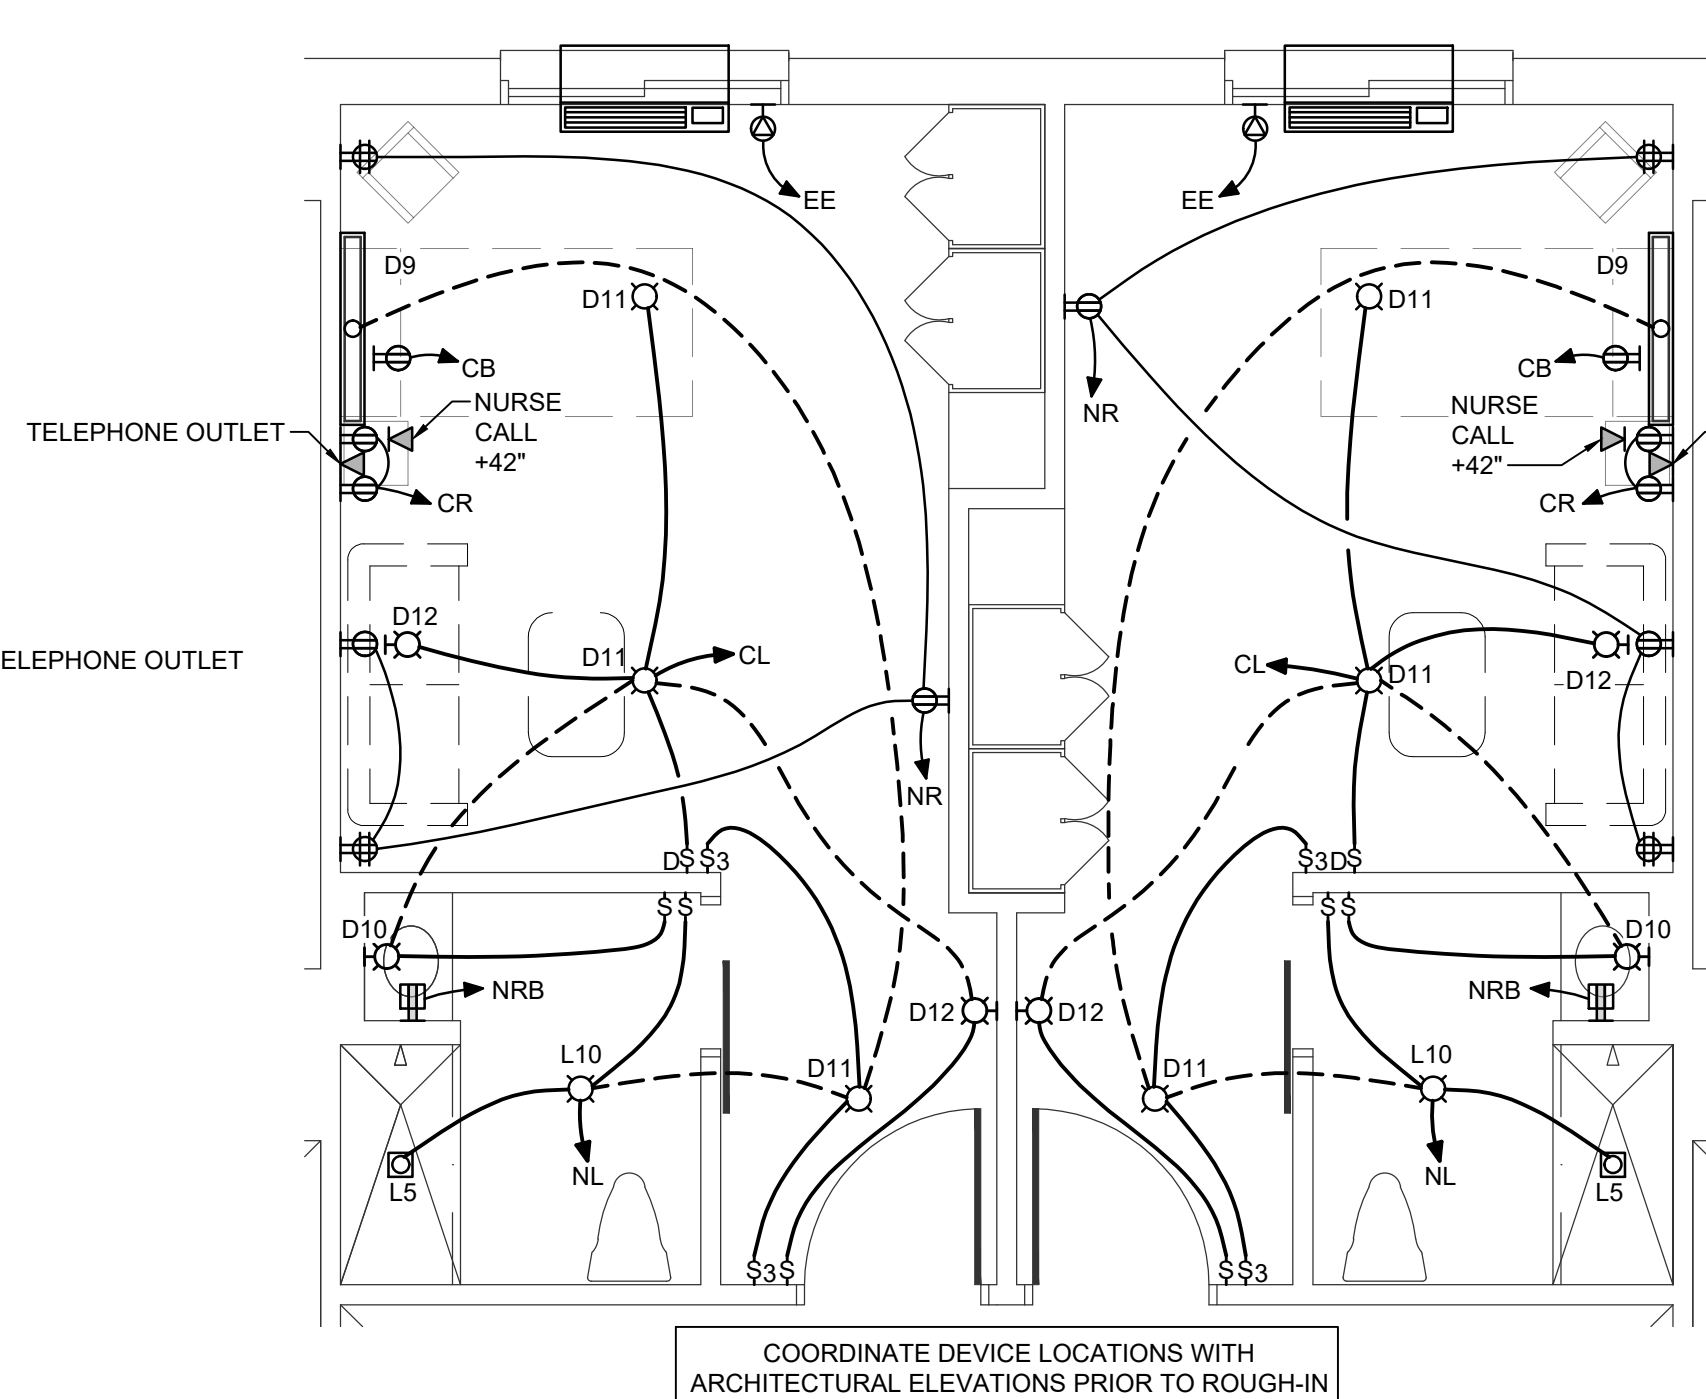


2
1/4" = 1'-0"

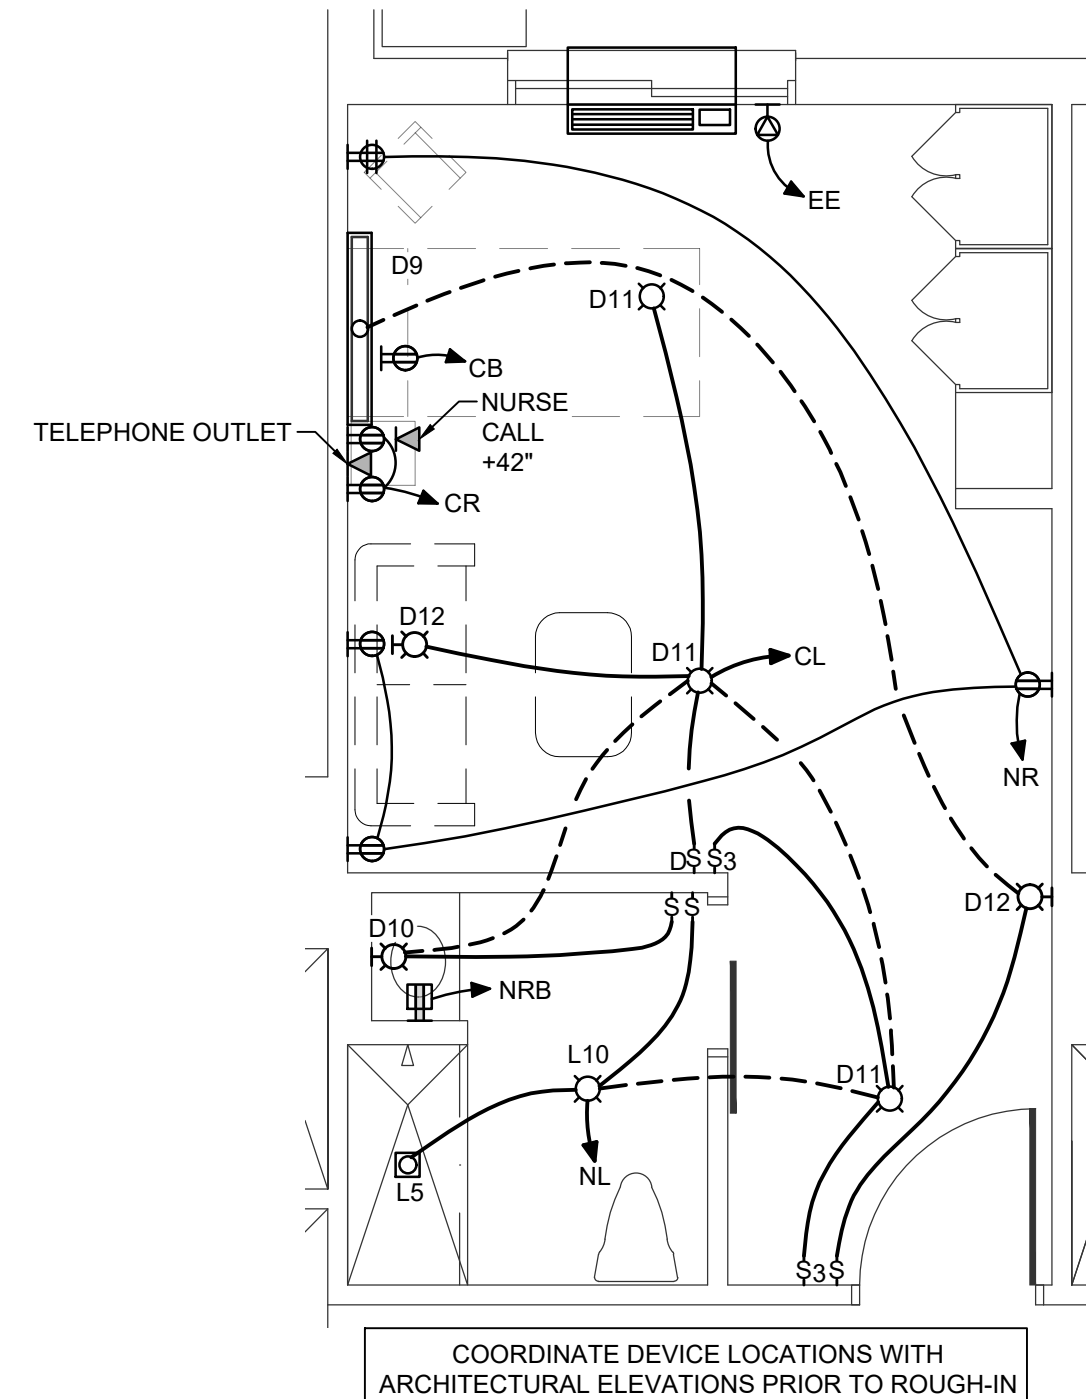

3
1/4" = 1'-0"

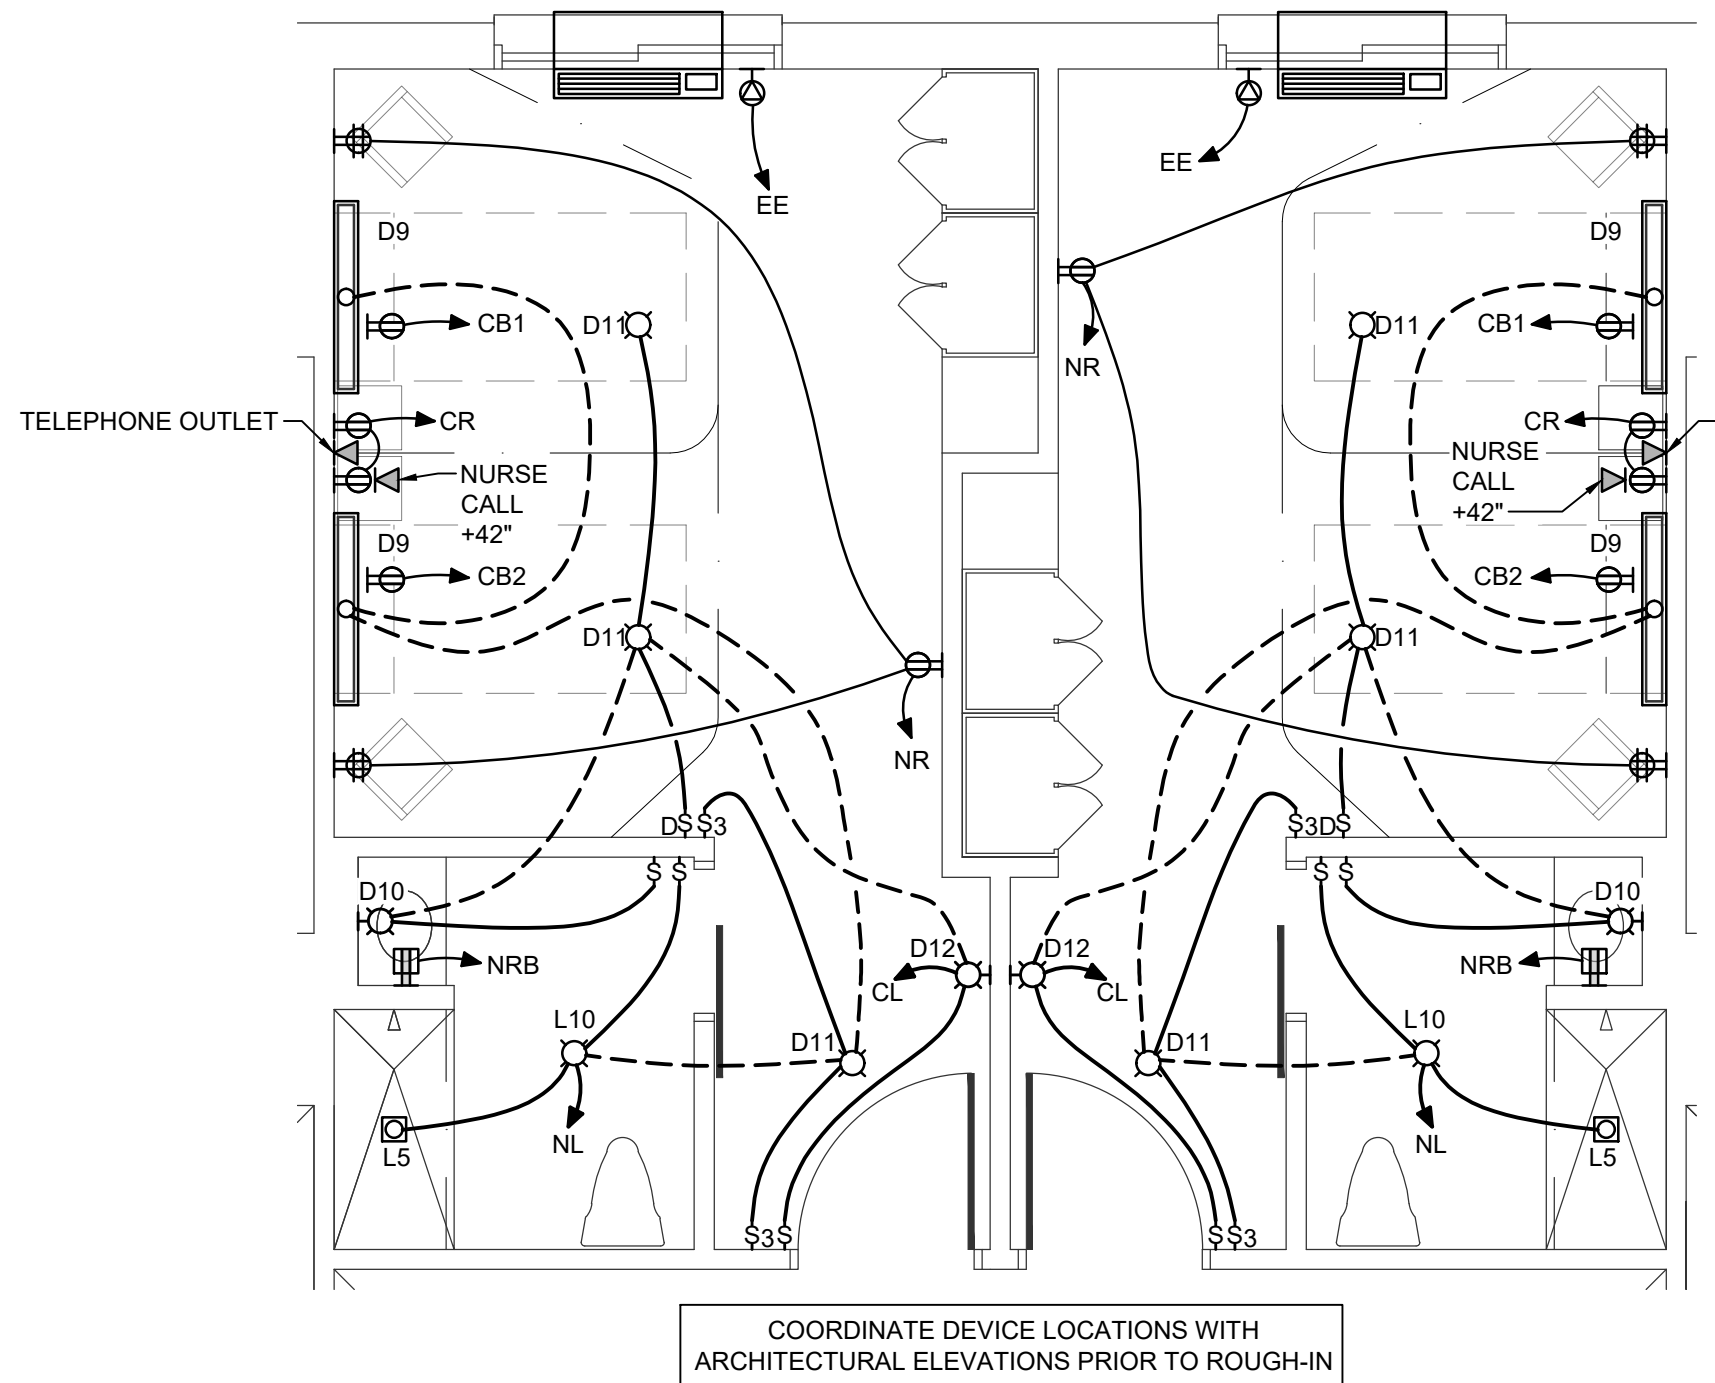

4
1/4" = 1'-0"

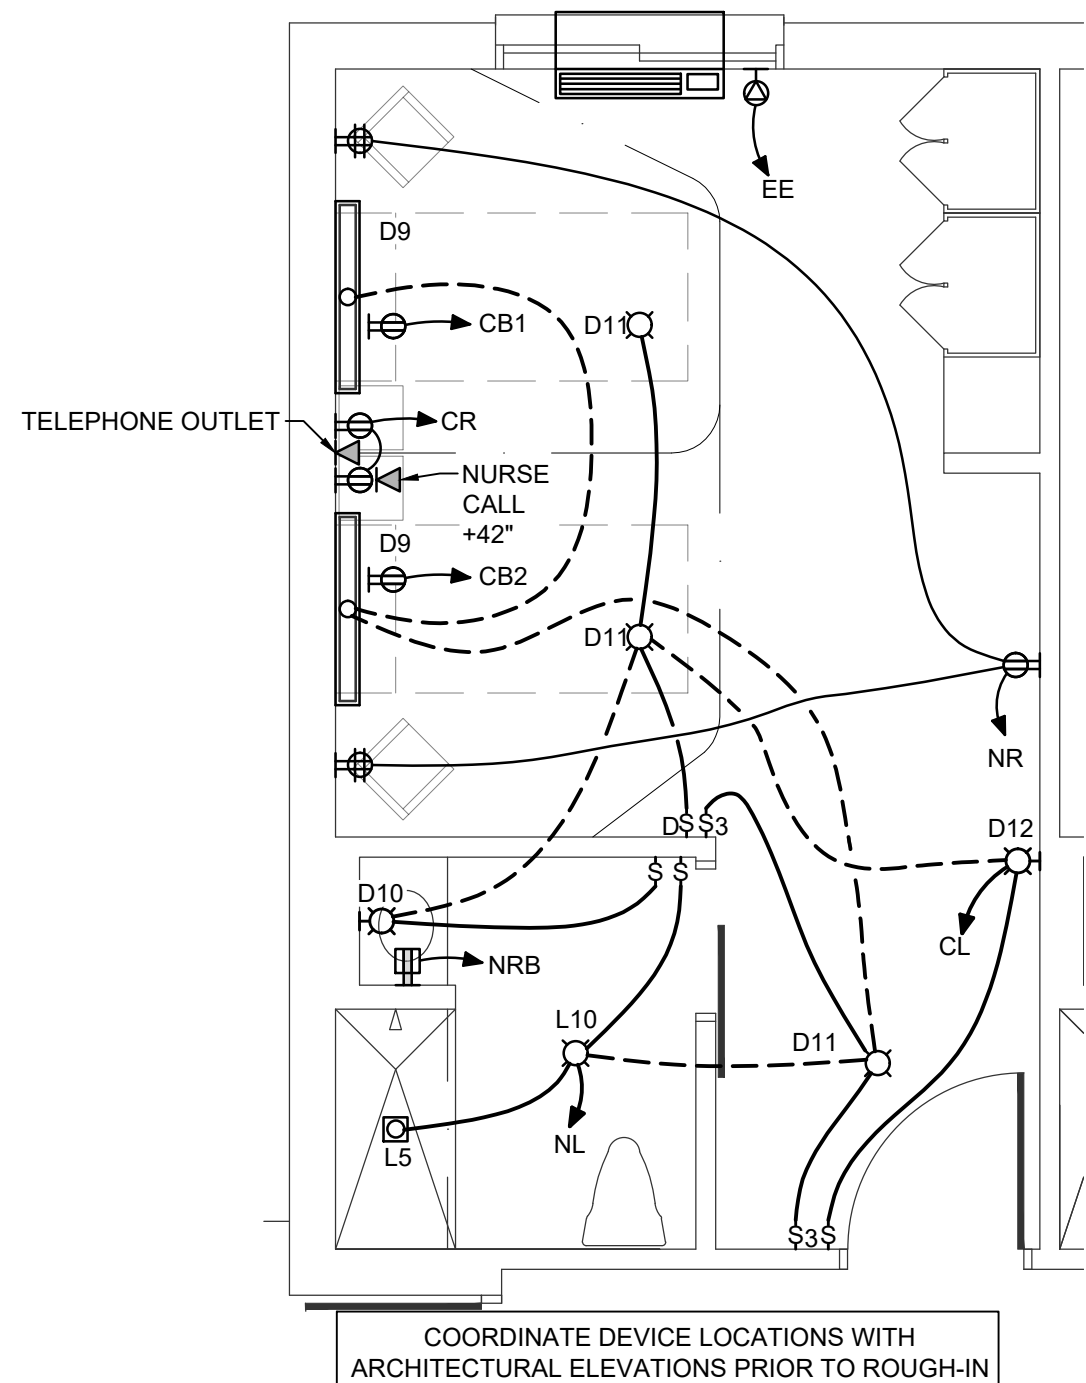

5
1/4" = 1'-0"

WALL TYPE LEGEND	
	1 HOUR FIRE BARRIER WALL
	1 HOUR FIRE/SMOKE BARRIER WALL
	2 HOUR FIRE BARRIER WALL
	SMOKE RESISTANT WALL

BEDROOM WIRING LEGEND	
SYMBOL	DESCRIPTION
NR	RECEPTACLE CIRCUIT, NORMAL POWER
CR	RECEPTACLE CIRCUIT, CRITICAL POWER FOR HEADWALL
CB	RECEPTACLE CIRCUIT, CRITICAL POWER FOR BED
NRB	BATHROOM RECEPTACLE CIRCUIT, NORMAL POWER
EE	EQUIPMENT CIRCUIT, EQUIPMENT POWER FOR PTH01
NL	LIGHTING CIRCUIT, NORMAL POWER
CL	LIGHTING CIRCUIT, CRITICAL POWER

CBHF
Engineers, PLLC

2246 Yaupon Drive
Wilmington, NC 28401
Phone: 910.791.4000
www.cbhfengineers.com
© Copyright 2026 CBHF Engineers, PLLC NC# P-0506

PRINCIPLE HEALTH CARE
WAKE COUNTY
Holly Springs, North Carolina


David R. Polston - Architect
3806 Park Ave. Suite C, Wilmington, NC 28403
Architecture Planning Design

120 BED
NURSING FACILITY
ELECTRICAL
BEDROOM PLANS


EP
4.0

PRELIMINARY
PRICING ONLY
NOT FOR
CONSTRUCTION


NOT FINAL SUBJECT TO REVISION. NOT FOR PERMITTING, FABRICATION, MATERIAL OR EQUIPMENT PURCHASE, INSTALLATION, OR CONSTRUCTION. PRICING SHALL STATE ALL ASSUMPTIONS, EXCLUSIONS, ALLOWANCES, AND CONTINGENCIES AND SHALL BE RECONCILED WITH THE FINAL SIGNED AND SEALED DOCUMENTS.

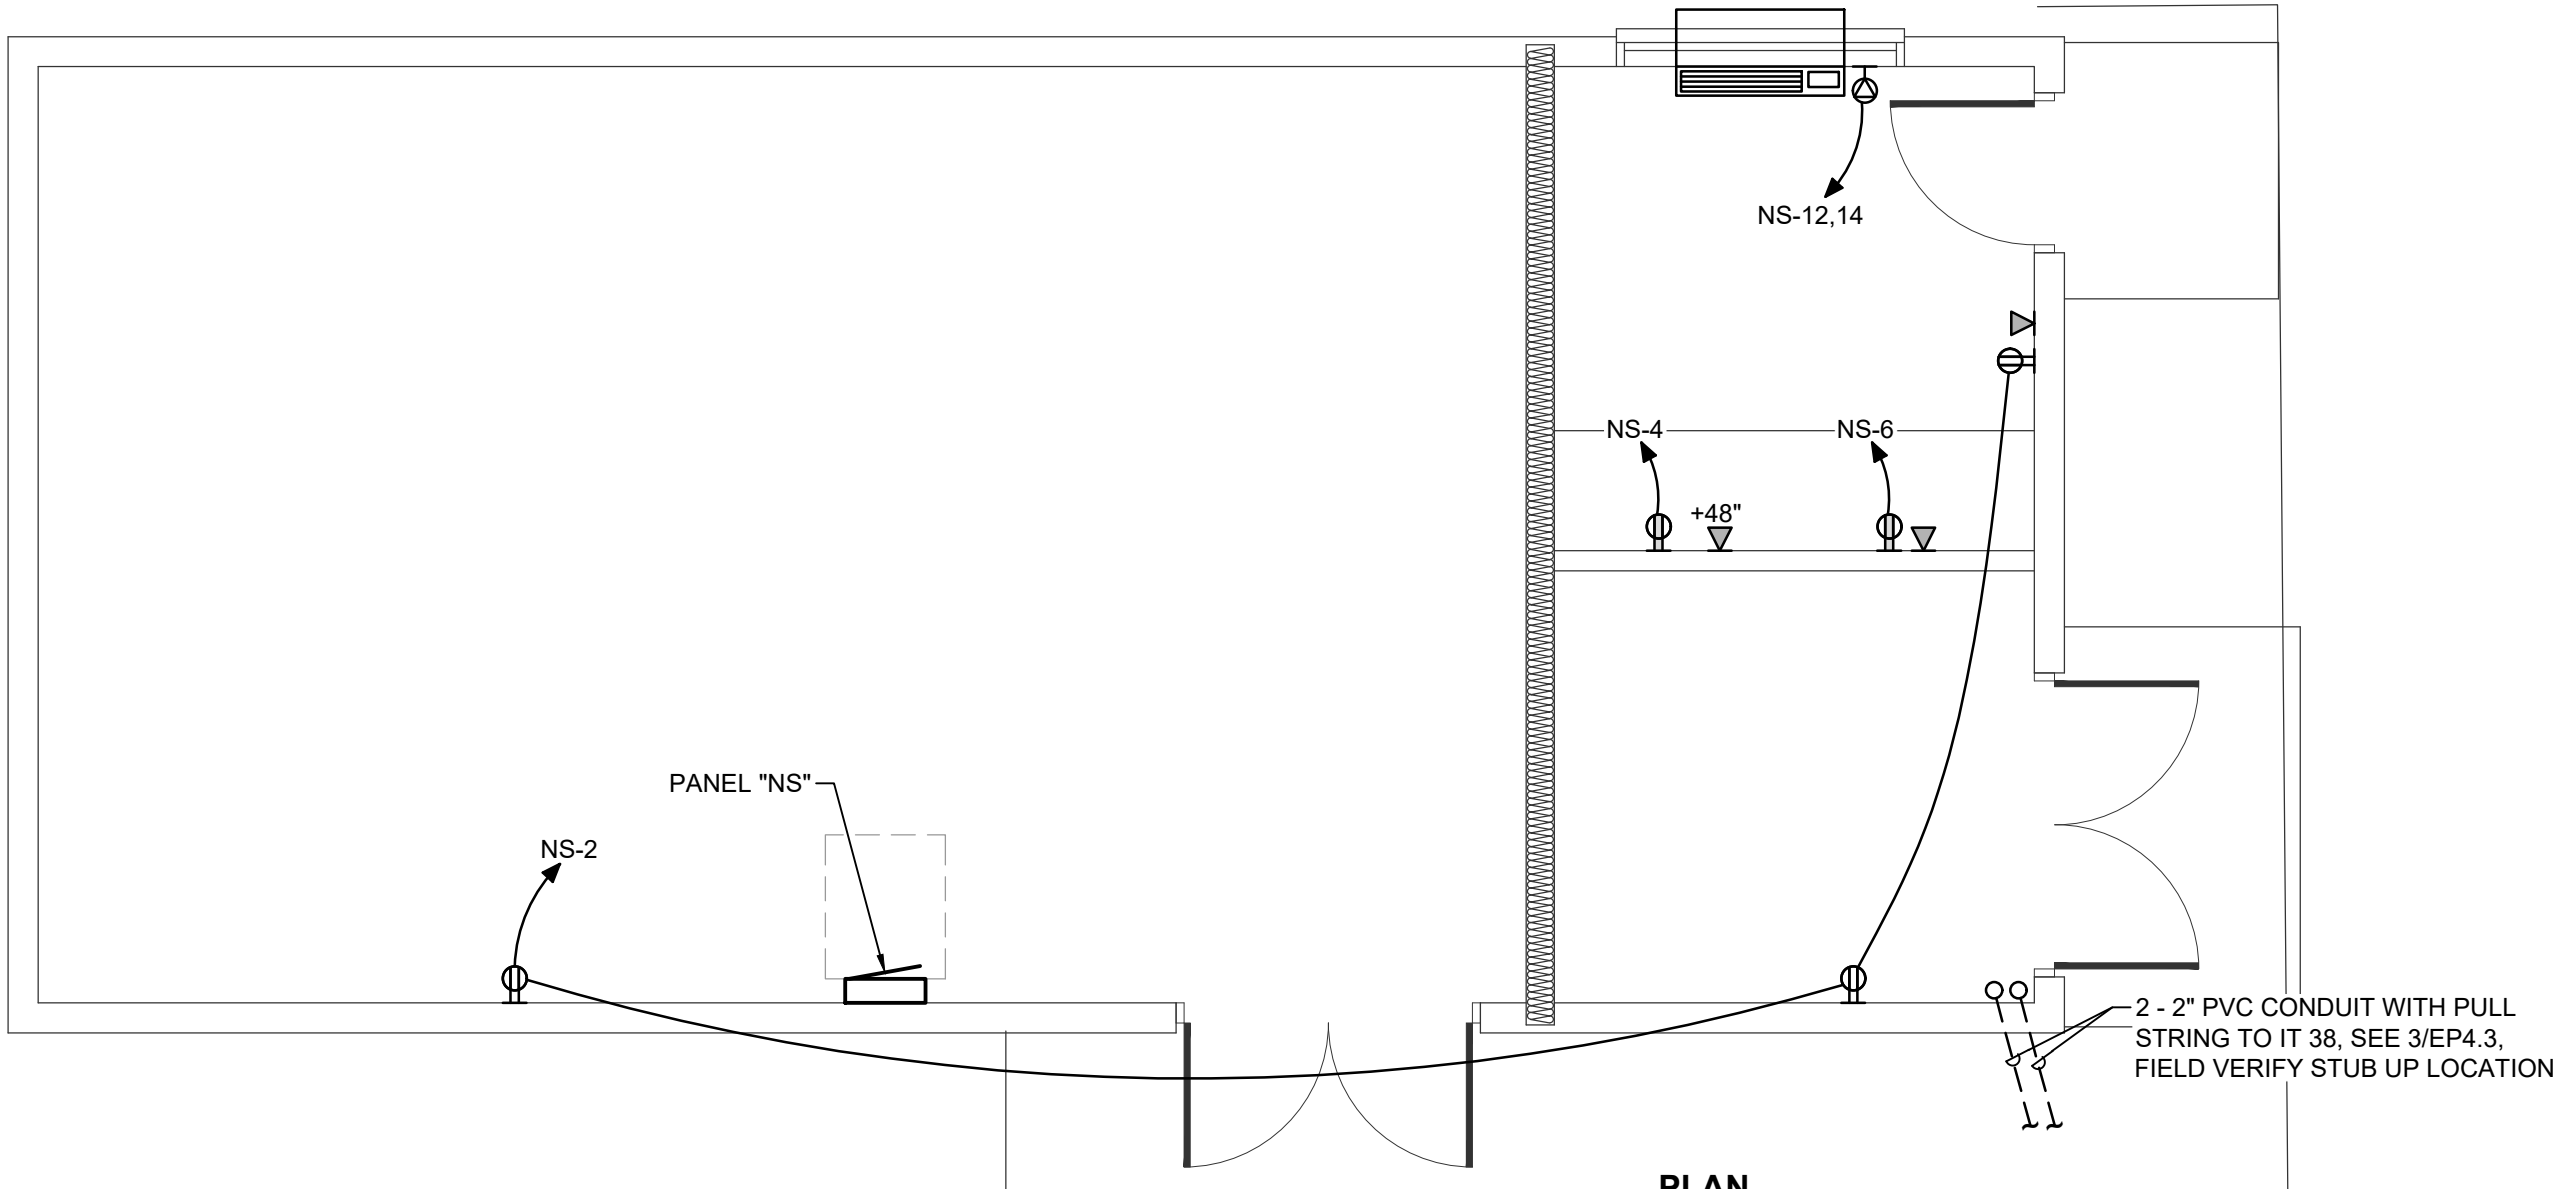


1 MAINTENANCE BUILDING POWER PLAN
1/4" = 1'-0"
0 2' 4' 8'
PLAN NORTH

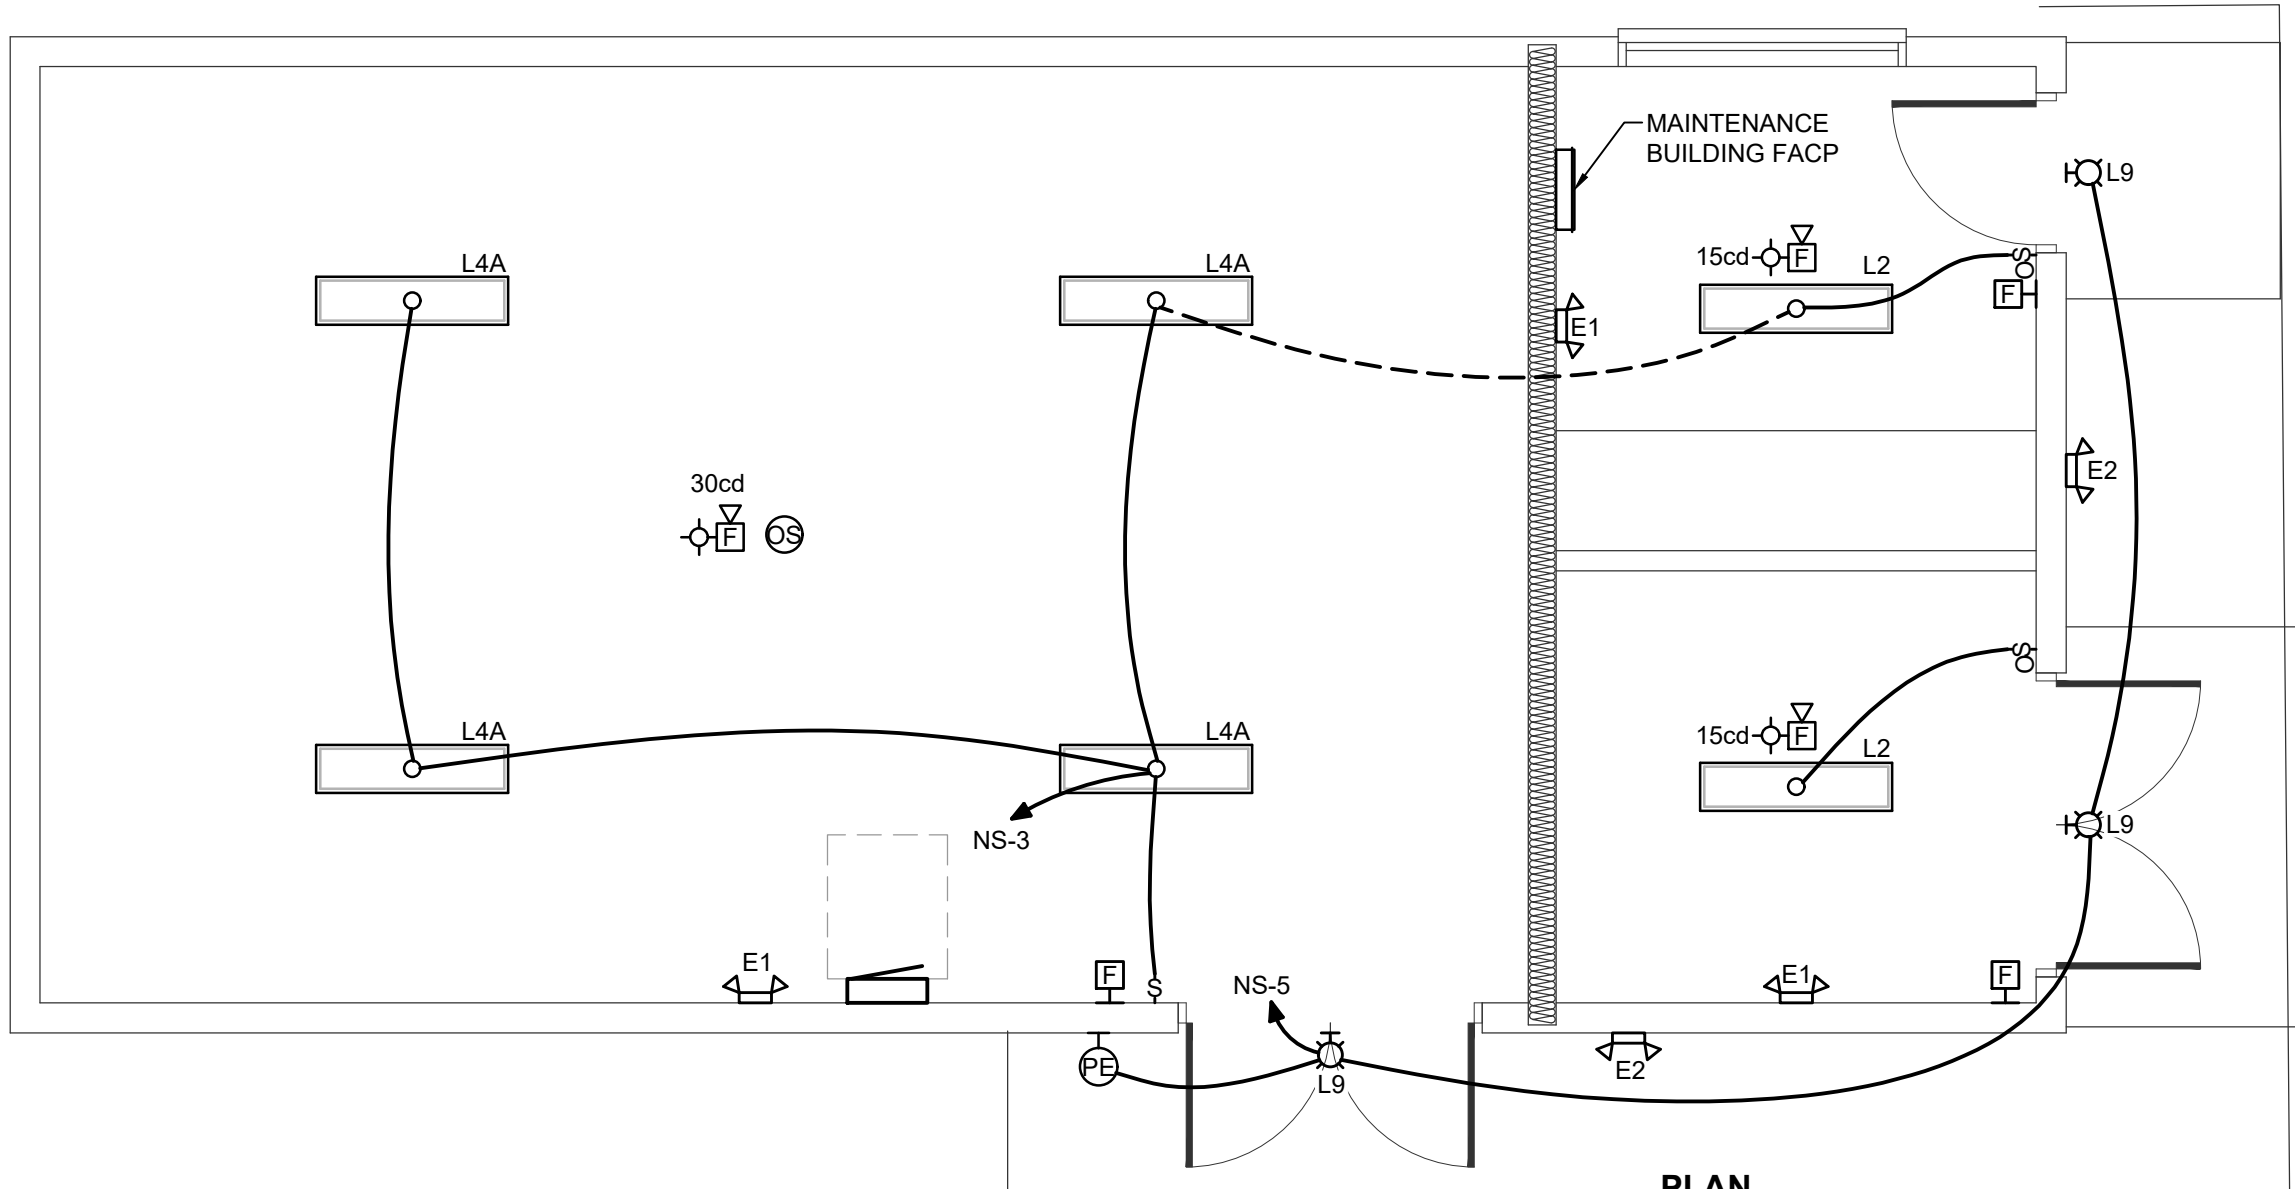

2 MAINTENANCE BUILDING LIGHTING AND FIRE ALARM SYSTEM PLAN
1/4" = 1'-0"
0 2' 4' 8'
PLAN NORTH

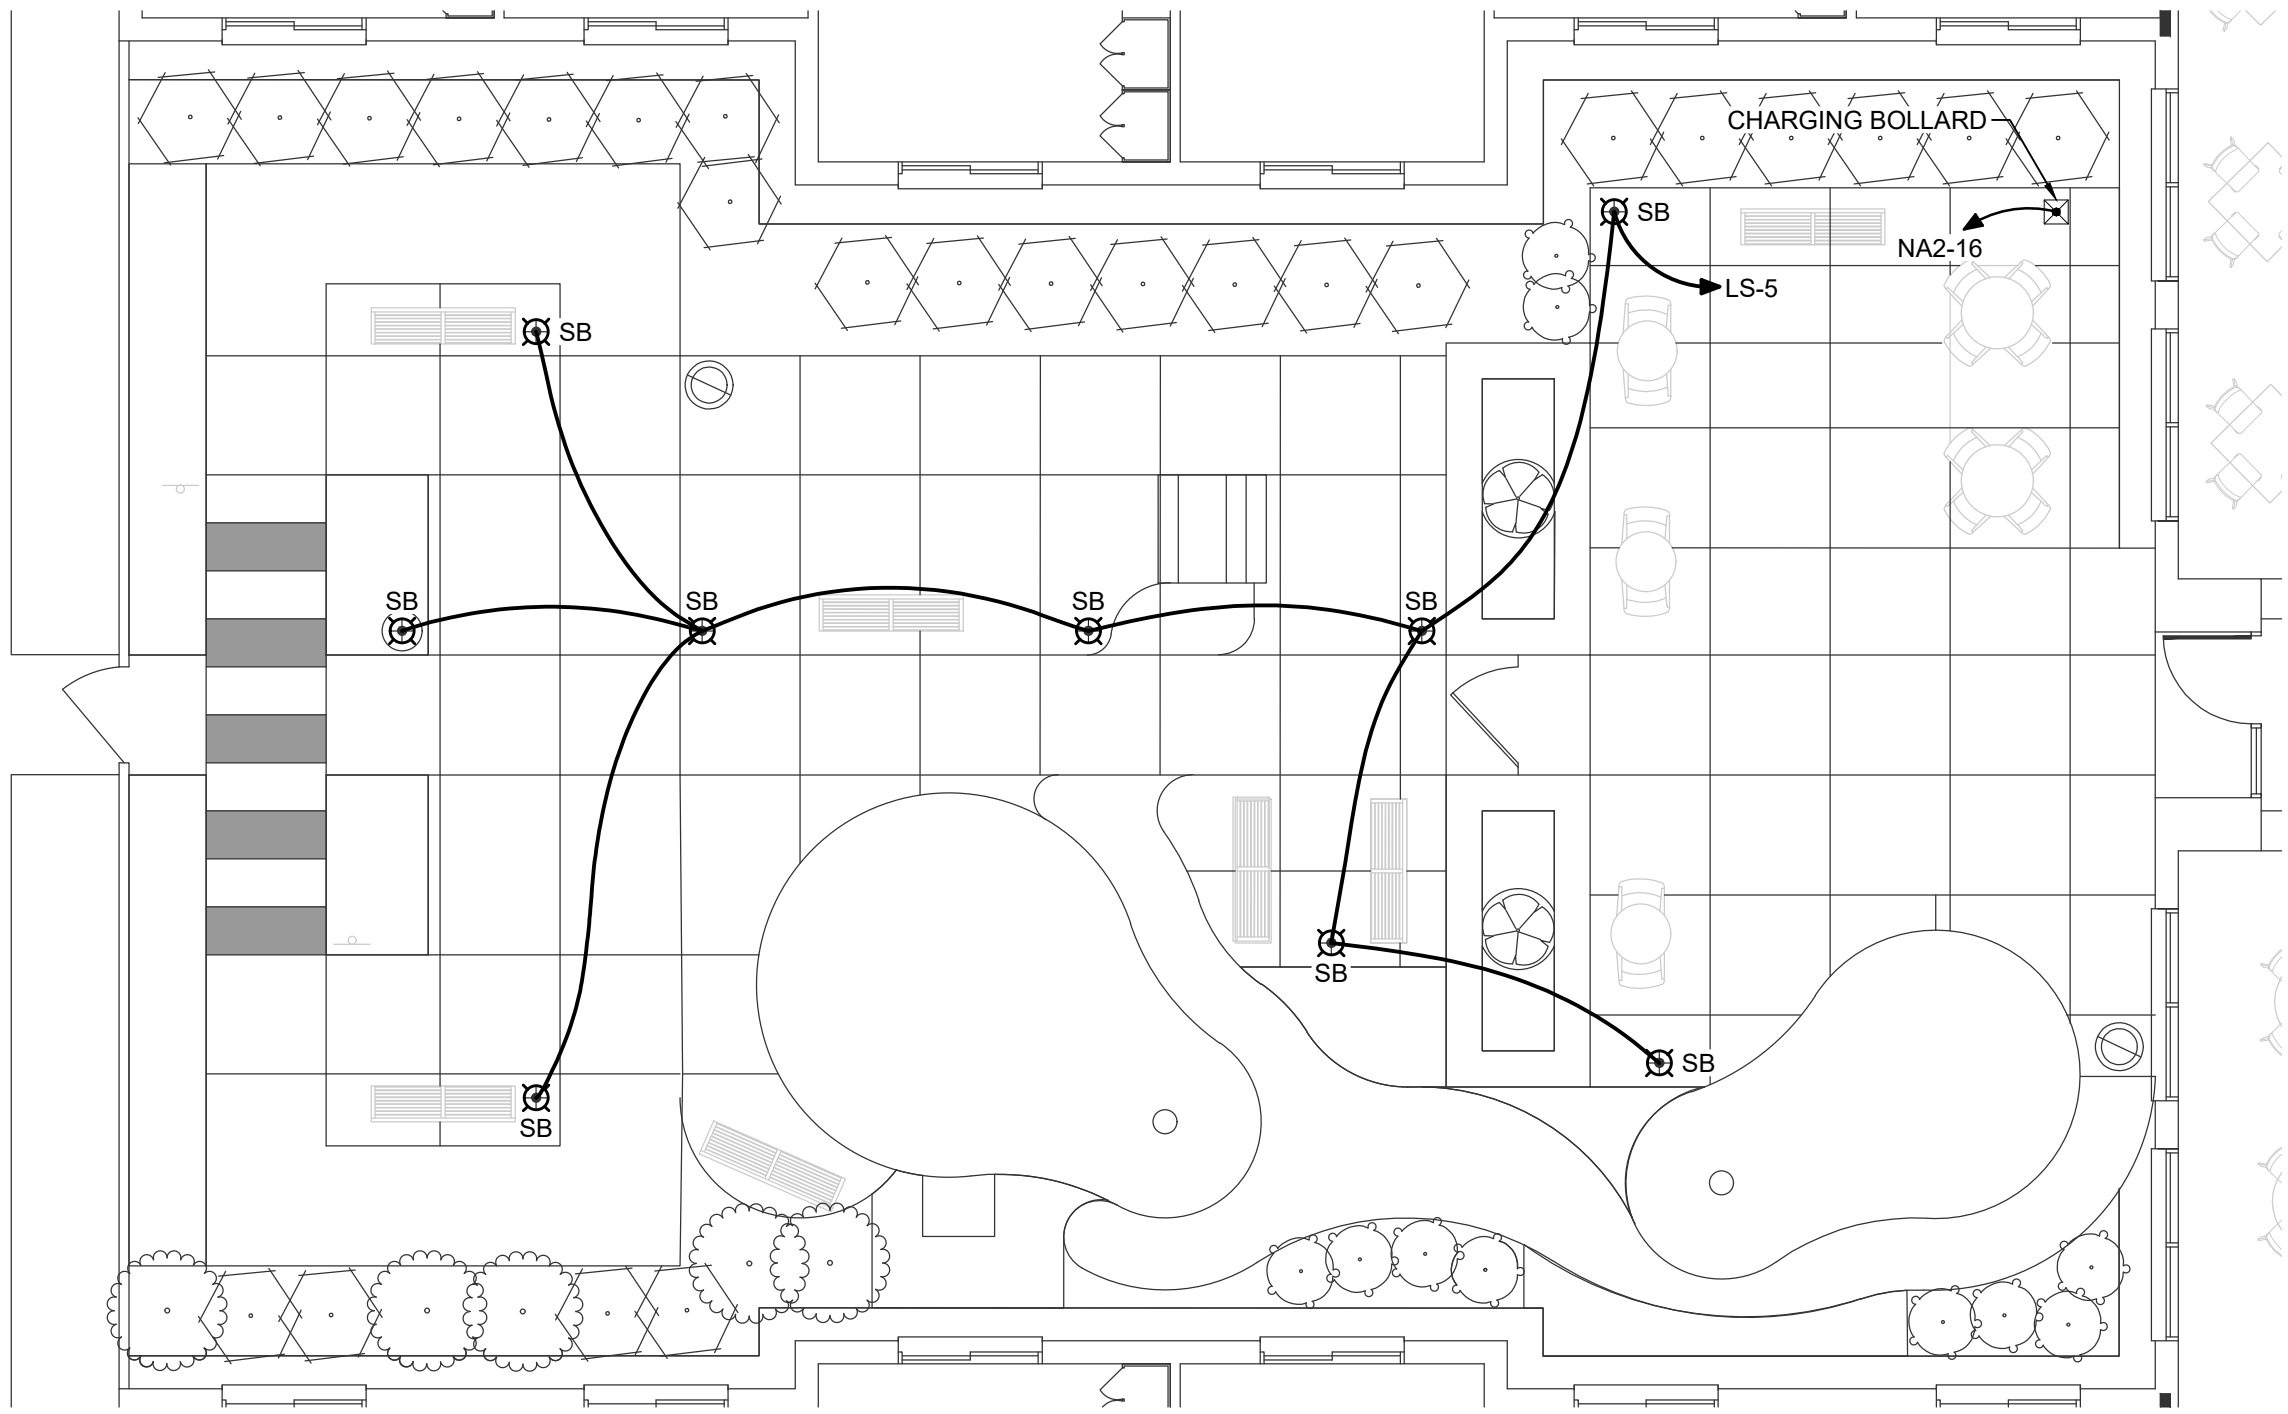

3 WEST COURTYARD PLAN
1/4" = 1'-0"
0 2' 4' 8'
PLAN NORTH

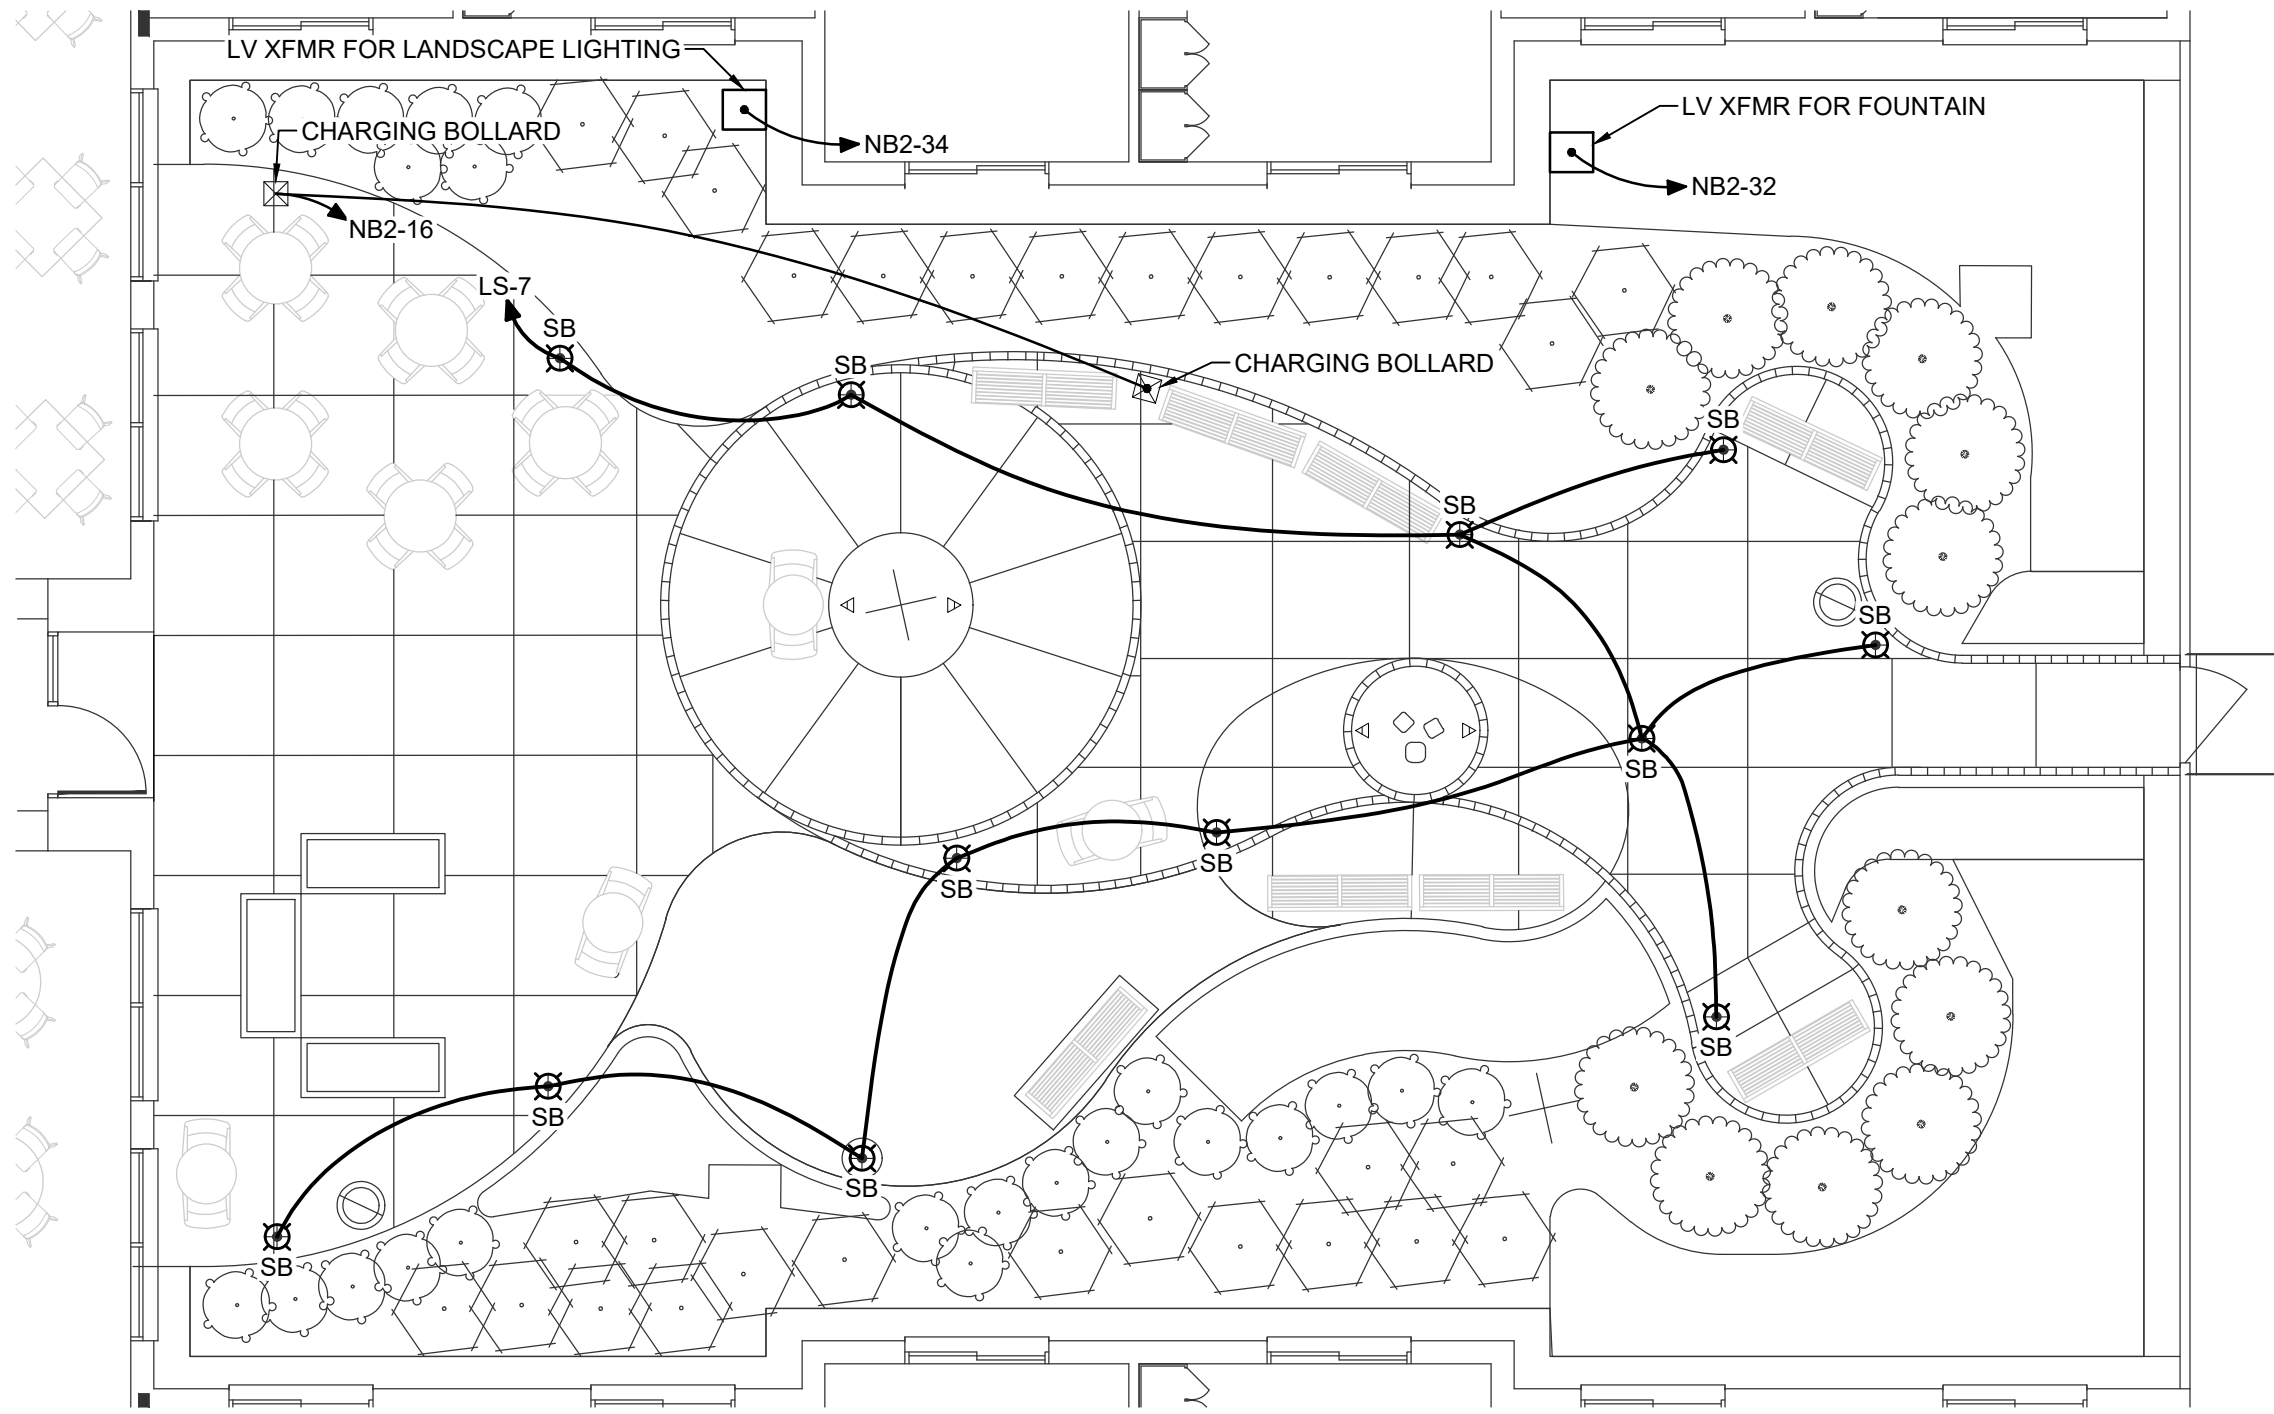

4 EAST COURTYARD PLAN
1/4" = 1'-0"
0 2' 4' 8'
PLAN NORTH

NOTES:



1. ELECTRICAL CLEARANCE NOTE: CONTRACTOR SHALL COORDINATE WITH GENERAL CONTRACTOR FOR PANEL/BOARD CLEAR WORKING SPACE MARKED ON THE FLOOR STATING "ELECTRICAL-NOT FOR STORAGE". REFER TO FBC 450.3.14.5 FOR ADDITIONAL INFORMATION.

2. COORDINATE ELECTRICAL DEVICES, EQUIPMENT, CIRCUITS, MOUNTING HEIGHTS, ETC. AND LOW VOLTAGE SYSTEMS EQUIPMENT LOCATIONS AND DETAILS WITH THE OWNER PRIOR TO ROUGH IN AND INSTALL ELECTRICAL EQUIPMENT AS REQUIRED AND AS DIRECTED BY THE OWNER AND LOW VOLTAGE SYSTEMS VENDORS. DOCUMENT ALL INSTALLATION CHANGES ON THE AS-BUILT DRAWINGS.


WALL TYPE LEGEND	
	1 HOUR FIRE BARRIER WALL
	1 HOUR FIRE/SMOKE BARRIER WALL
	2 HOUR FIRE BARRIER WALL
	SMOKE RESISTANT WALL

NOT FINAL. SUBJECT TO REVISION. NOT FOR PERMITTING. FABRICATION, MATERIAL OR EQUIPMENT PURCHASE, INSTALLATION OR CONSTRUCTION. PRICING SHALL STATE ALL ASSUMPTIONS, EXCLUSIONS, ALLOWANCES, AND CONTINGENCIES AND SHALL BE RECONCILED WITH THE FINAL SIGNED AND SEALED DOCUMENTS.

NOT FINAL SUBJECT TO REVISION. NOT FOR PERMITTING, FABRICATION, MATERIAL OR EQUIPMENT PURCHASE, INSTALLATION, OR CONSTRUCTION. PRICING SHALL STATE ALL ASSUMPTIONS, EXCLUSIONS, ALLOWANCES, AND CONTINGENCIES AND SHALL BE RECONCILED WITH THE FINAL SIGNED AND SEALED DOCUMENTS.

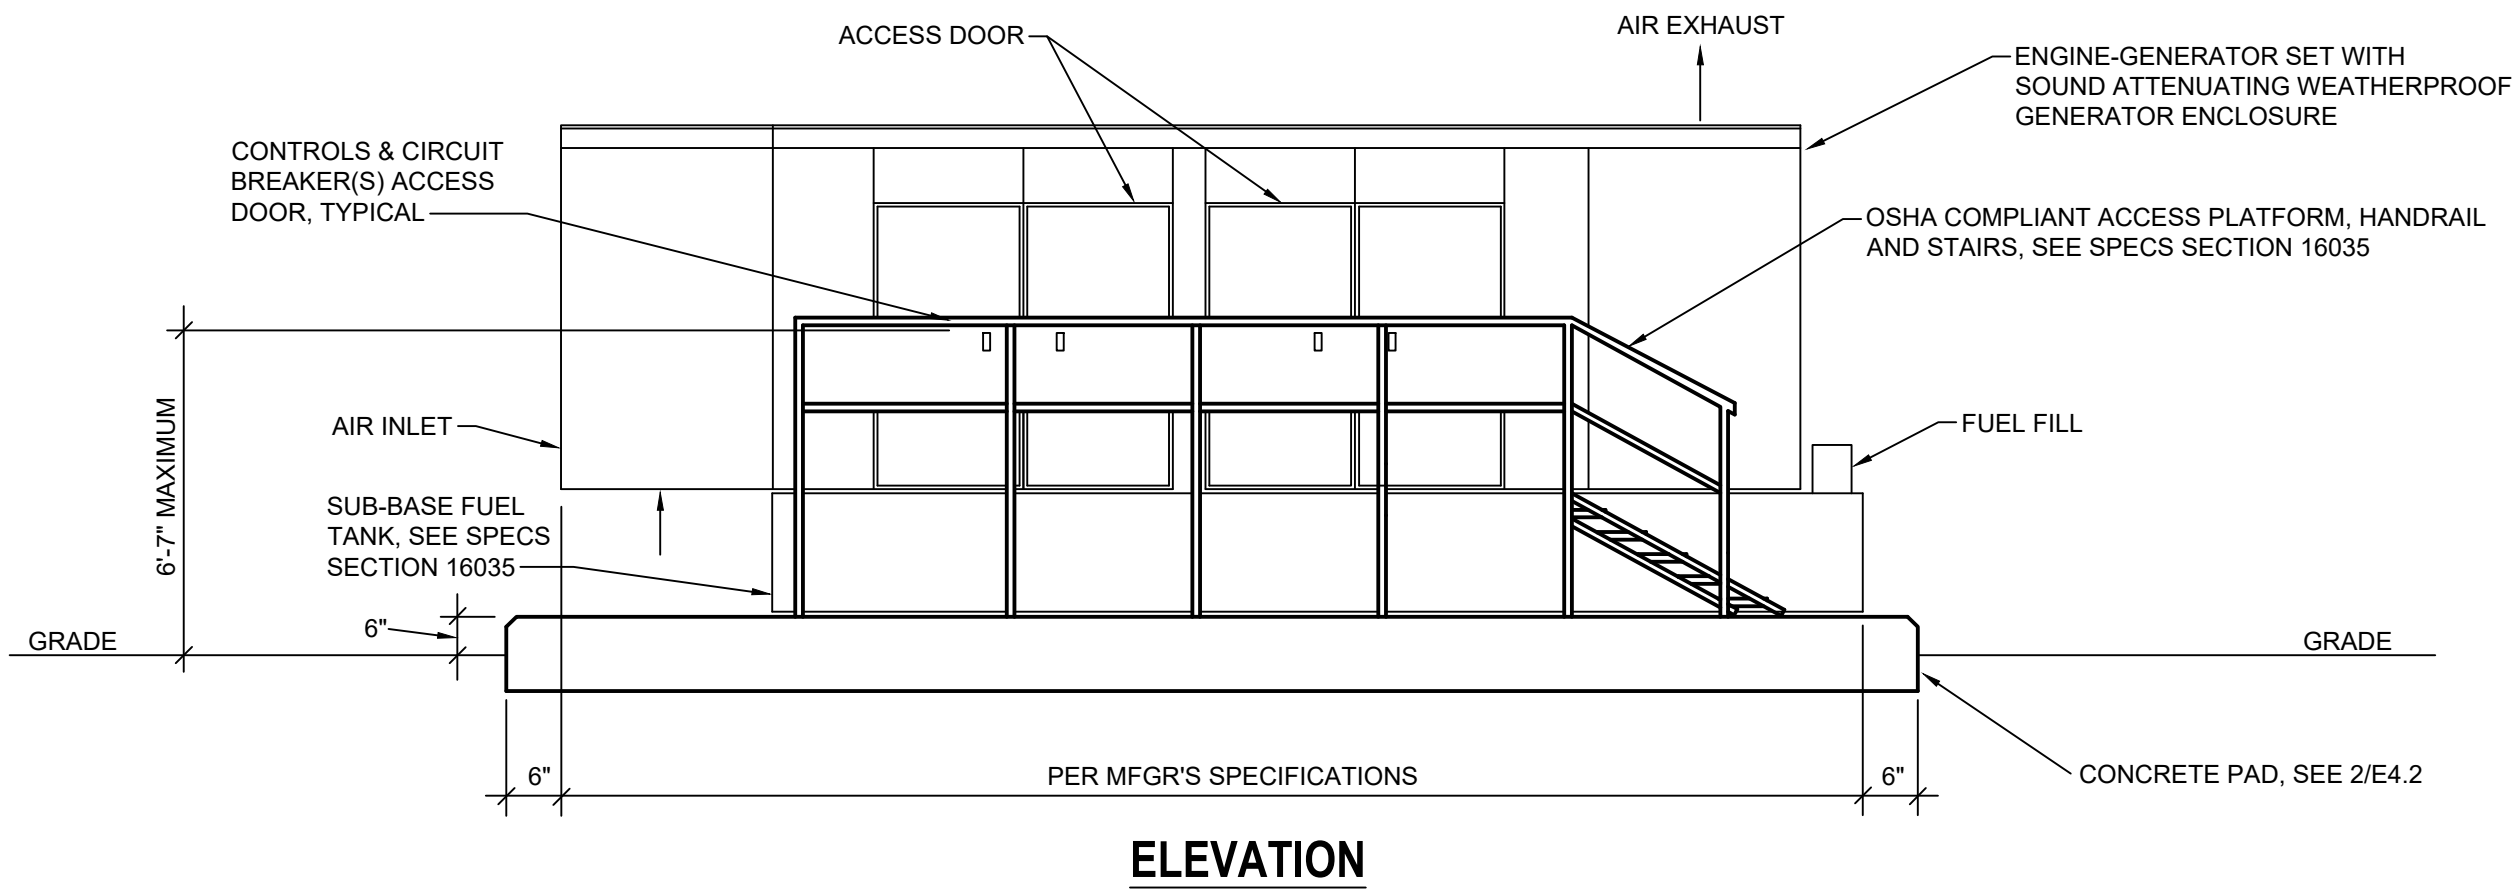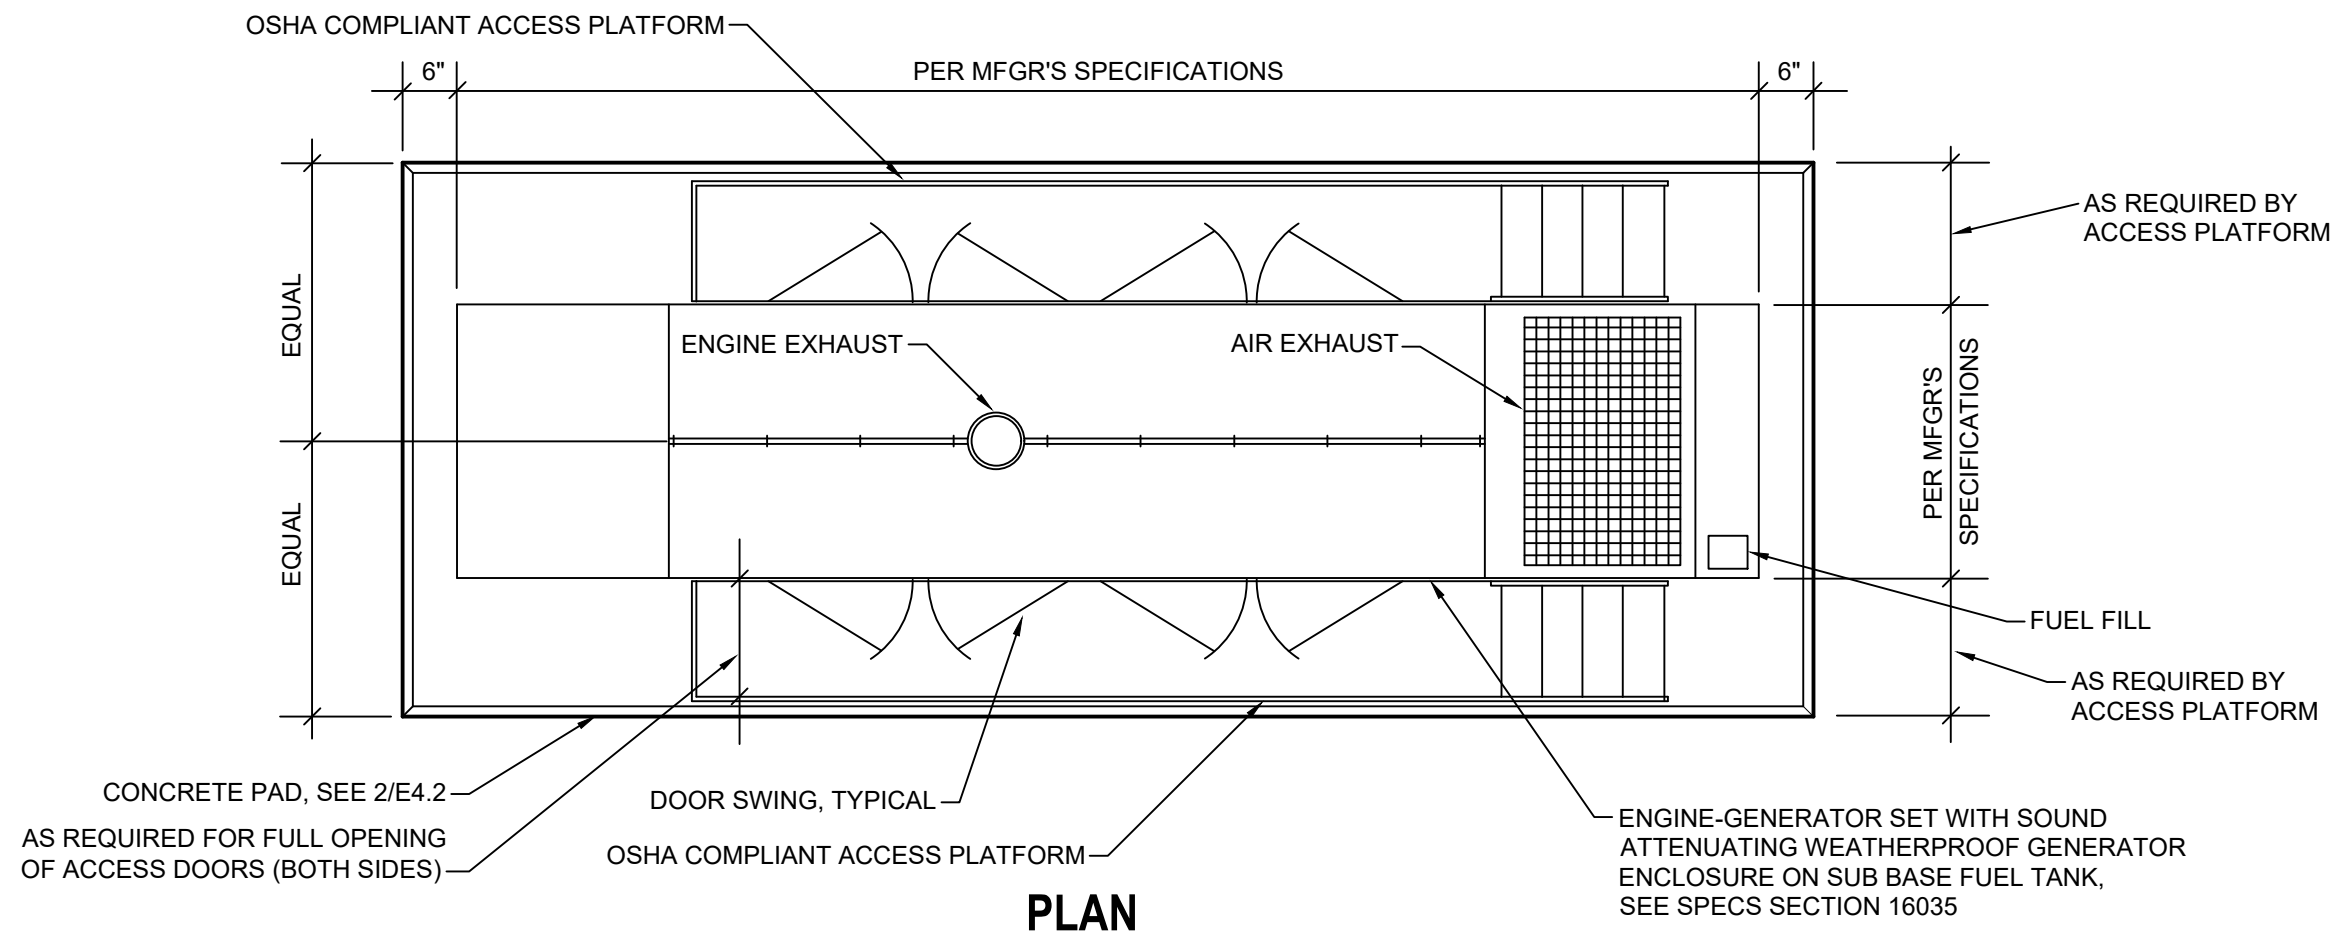


3 ENGINE-GENERATOR SET DETAIL
NOT TO SCALE

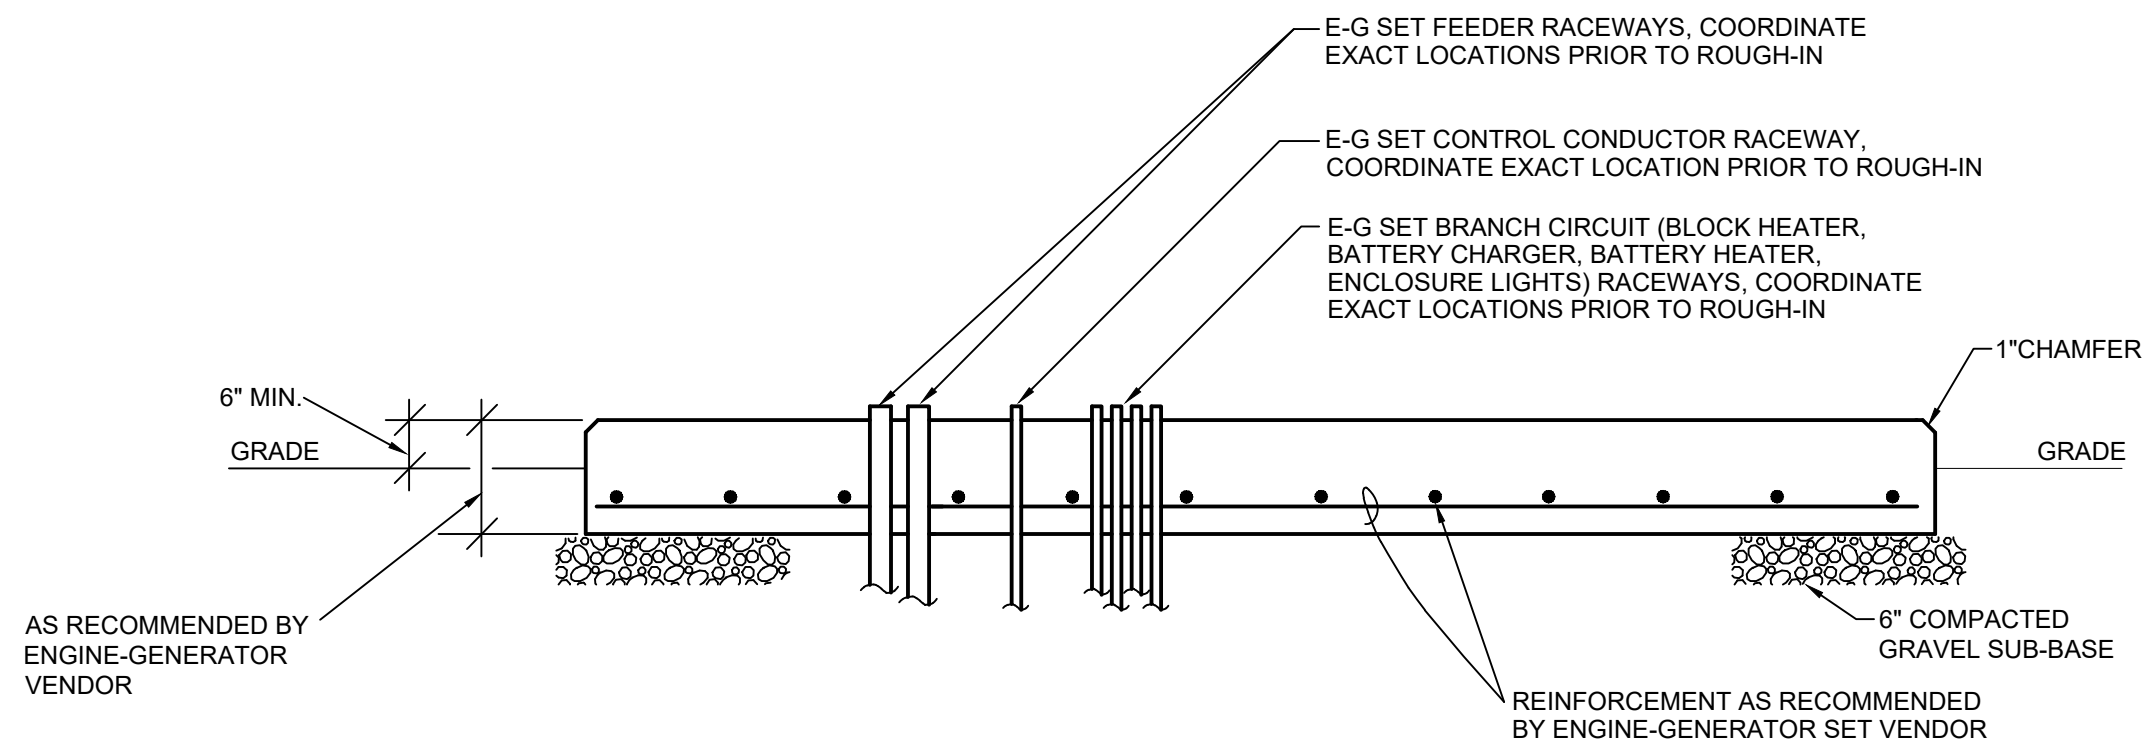


NOTE: FIELD VERIFY EXACT PAD SIZE REQUIREMENTS AND RACEWAY STUB-UP LOCATIONS WITH ENGINE-GENERATOR VENDOR, SUB-BASE FUEL TANK VENDOR AND STRUCTURAL ENGINEER PRIOR TO POURING OF PAD


2 ENGINE-GENERATOR SET CONCRETE PAD DETAIL
NOT TO SCALE

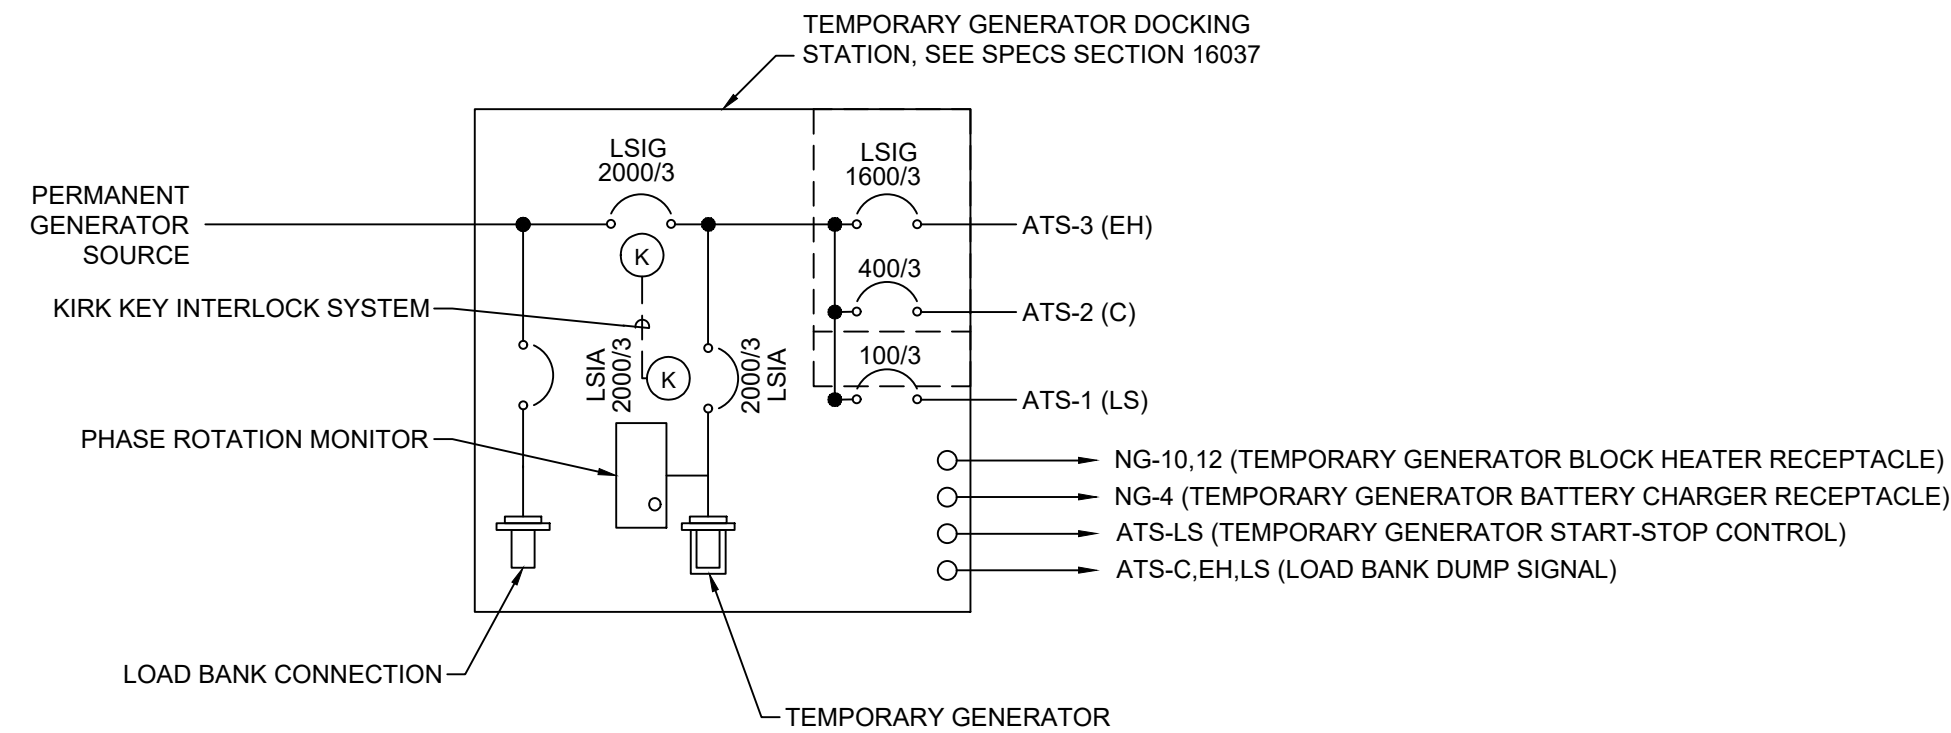





4 TEMPORARY GENERATOR DOCKING STATION DETAIL
NOT TO SCALE

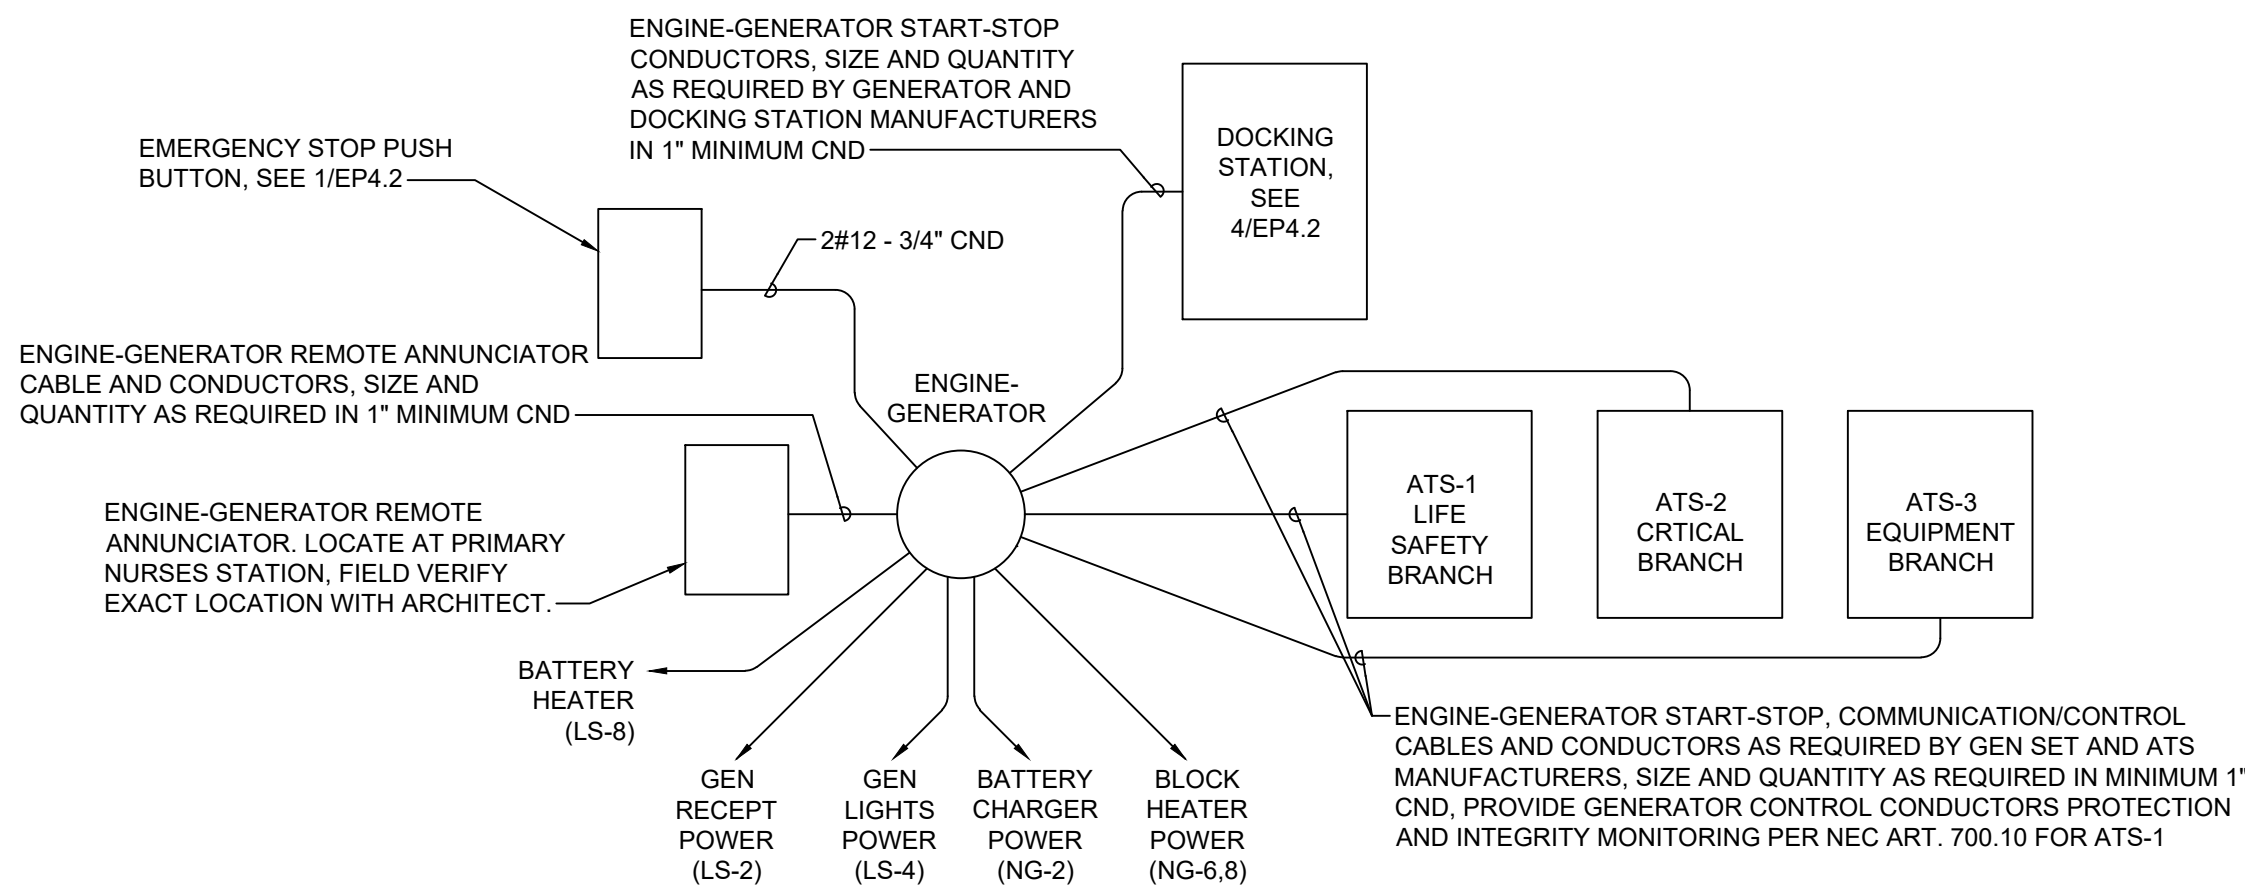

5 GENERATOR CONTROL BLOCK DIAGRAM
NOT TO SCALE

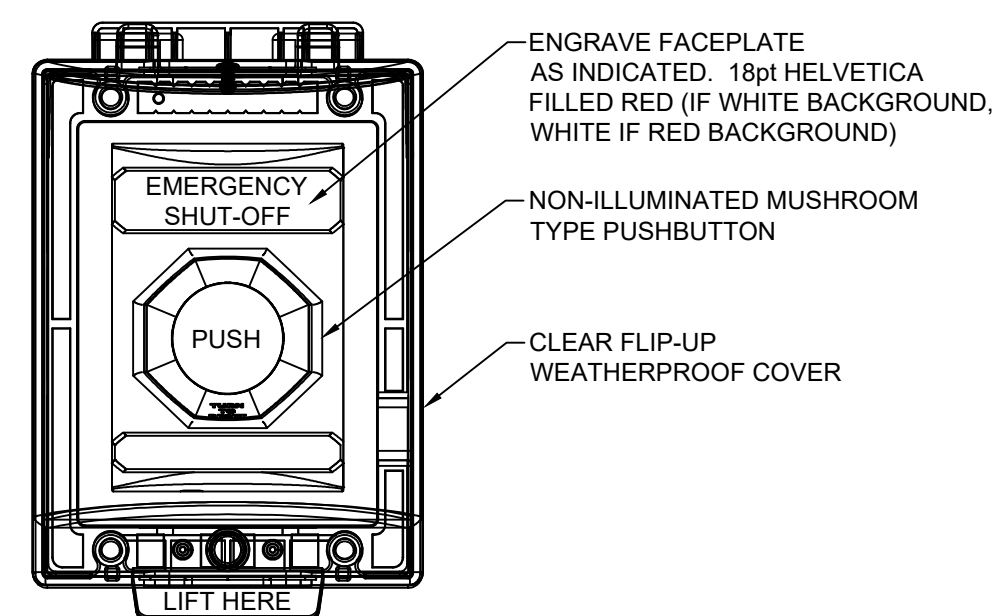

1 ENGINE-GENERATOR REMOTE EMERGENCY SHUTOFF SWITCH
NOT TO SCALE

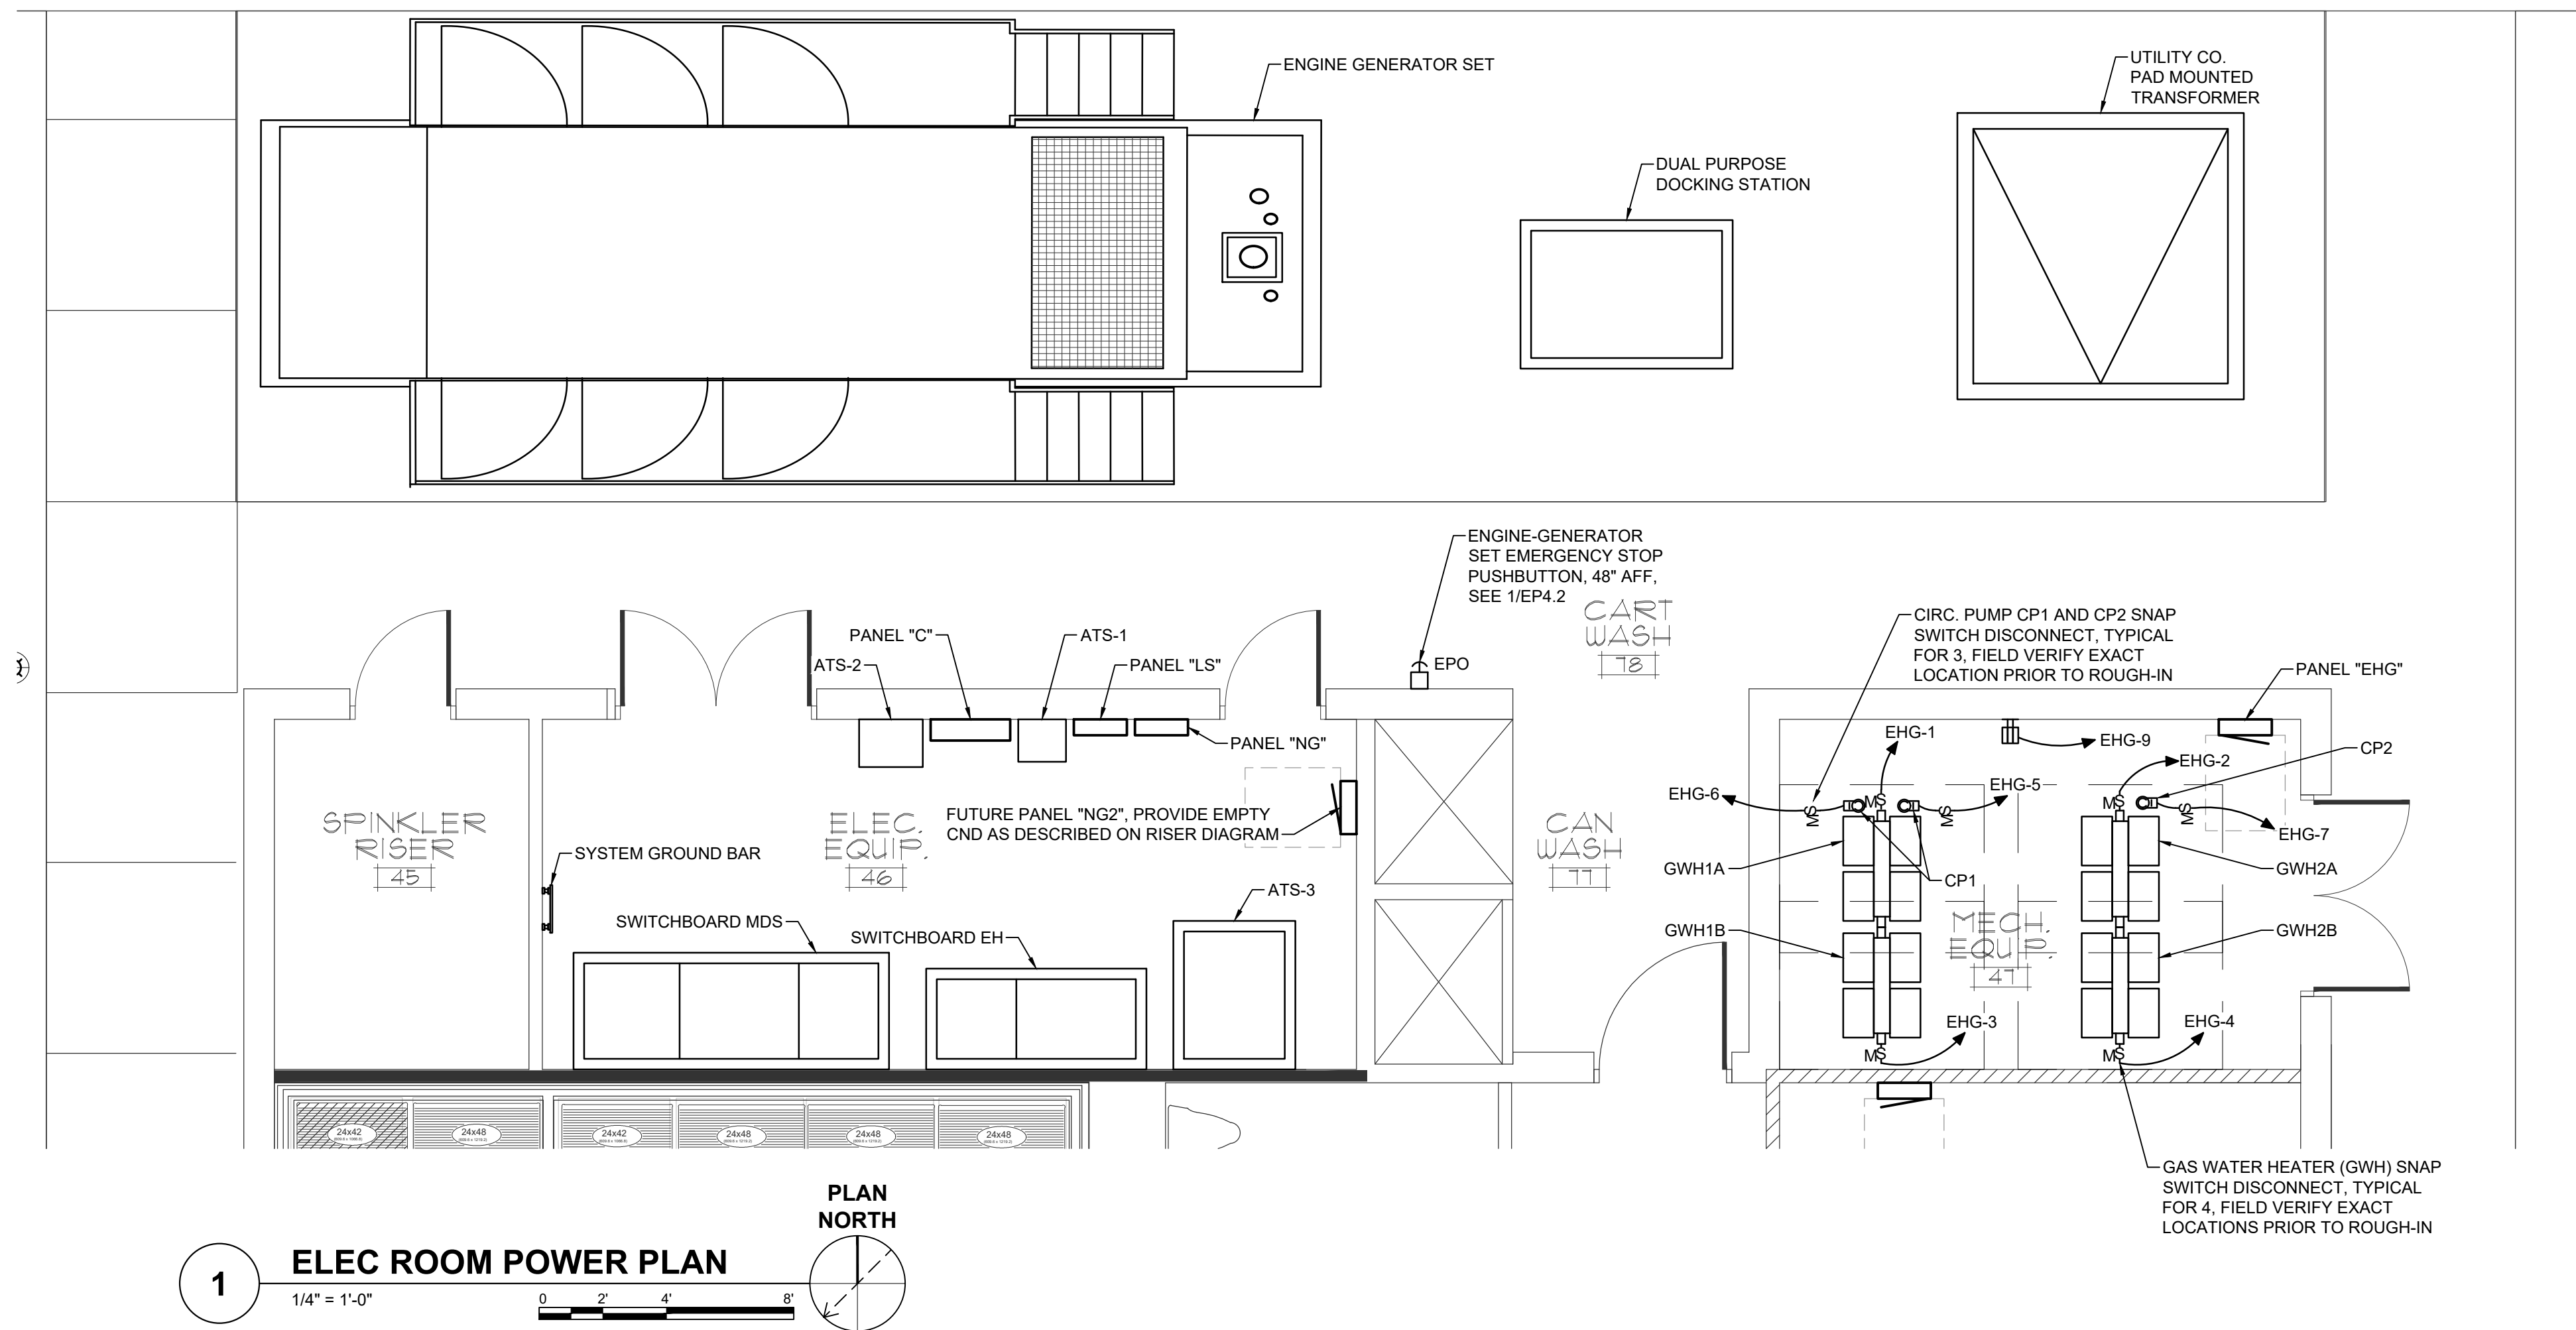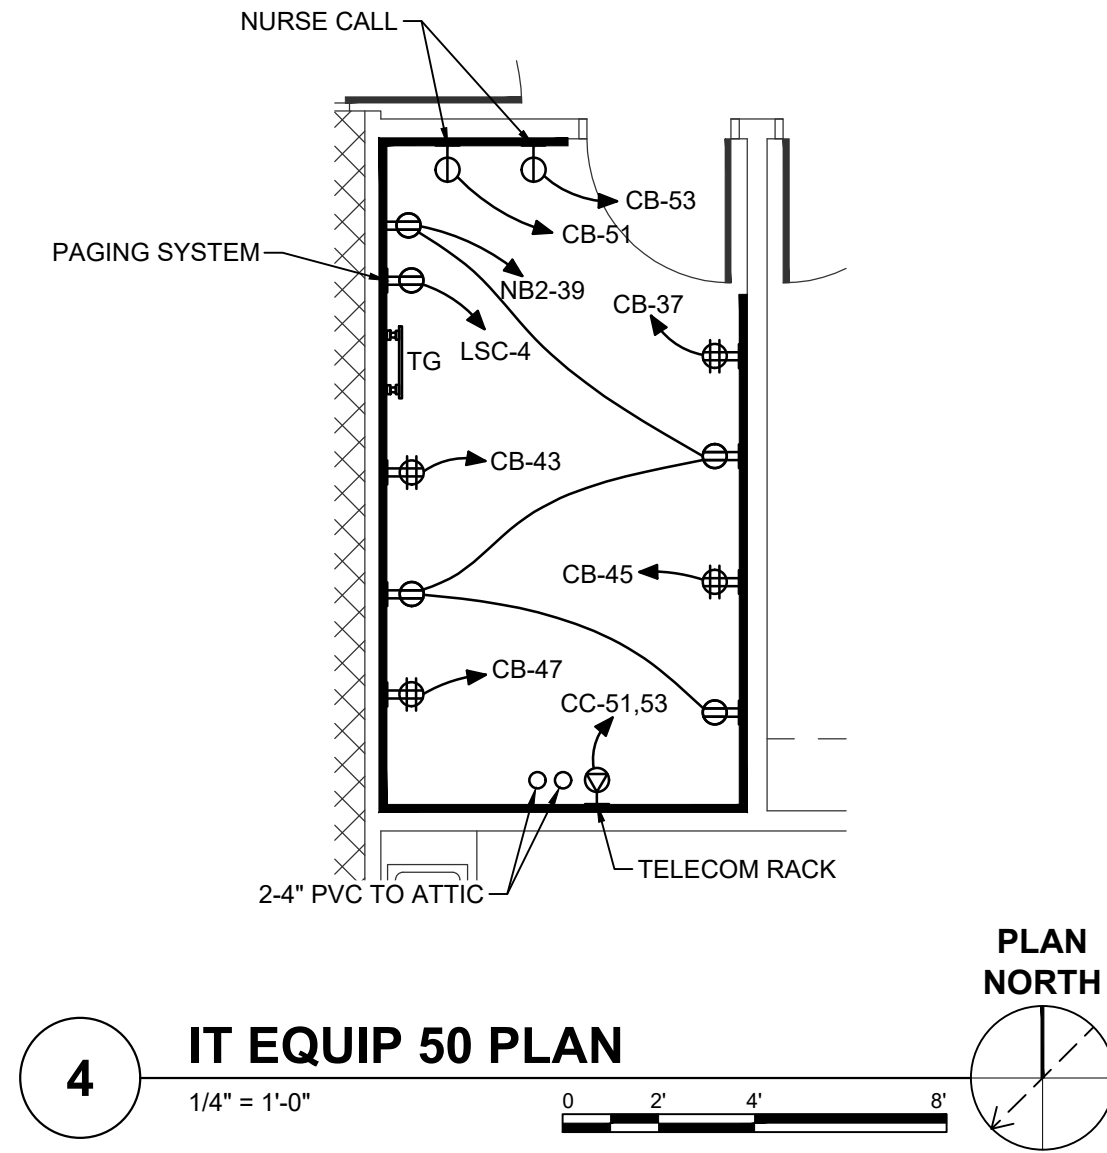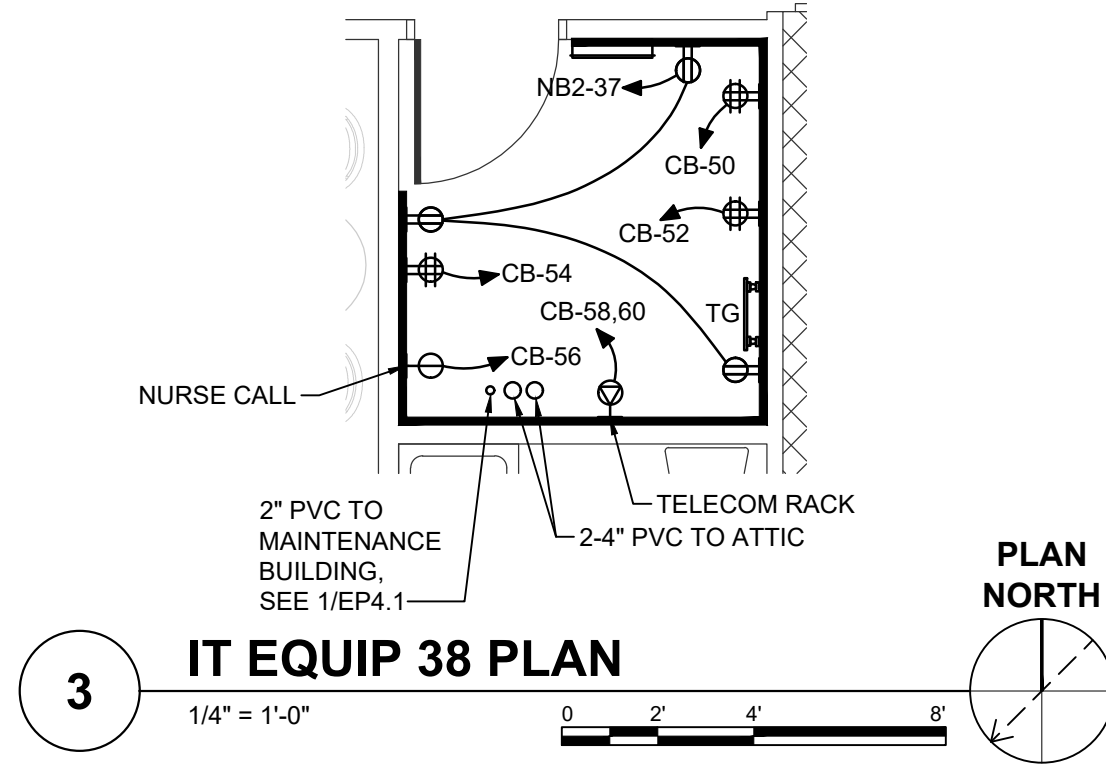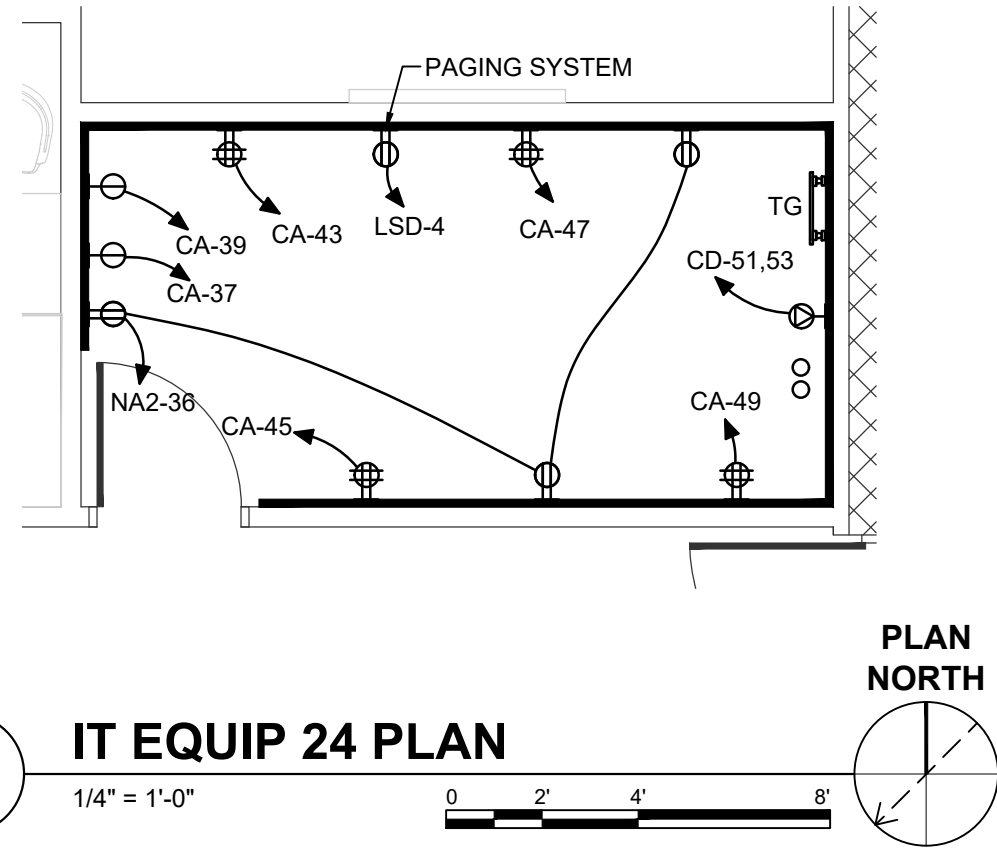

LIGHTING FIXTURE SCHEDULE														
MARK	DESCRIPTION	MANUFACTURER/SERIES (BASIS OF DESIGN)	ALTERNATE FIXTURE	NOM. SIZE	TEMP(°K)	LAMPS	VOLTS	DELIVERED LUMENS	WATTS	LENS	COLOR	MOUNTING HEIGHT	BALLAST/ DRIVER	REMARKS
L1	2x4 SURFACE MOUNTED LED	LITHONIA 2RTLX4 60L EZ1 LP840	METALUX 24CZSCT3-UNV SK-24-WS	2'x4'	4000K	LED	120	5187	55		WHITE	SURFACE CEILING	10% DIMMING	
L2	2x4 SURFACE MOUNTED LED	LITHONIA 2RTLX4 72L EZ1 LP840	METALUX 24CZSCT3-UNV SK-24-WS	2'x4'	4000K	LED	120	6669	72		WHITE	SURFACE CEILING	10% DIMMING	
L4	4' SURFACE MOUNTED WRAPAROUND	LITHONIA LBL4 7200LM 80 CRI 40K MIN1 ZT MVOLT	METALUX 4NWS3C3-UNV	4'	4000K	LED	120	7336	62		WHITE	SURFACE CEILING	10% DIMMING	
L4A	4' SURFACE MOUNTED WRAPAROUND	LITHONIA LBL4 7200LM 80 CRI	METALUX 4NWS3C3-UNV	4'	4000K	LED	120	4253	32		WHITE	SURFACE CEILING	10% DIMMING	
L5	4" RECESSED LED SHOWER LIGHT	LITHONIA LDN4 40/15 L04AR LSS MVOLT EZ10	HALO COMM HC415D010 / HM40525840 / 41PSMDW	4"	4000K	LED	120	1444	20		WHITE	RECESSED CEILING	10% DIMMING	WET LOCATION LABEL, WHITE PAINTED FLANGE
L6	6" RECESSED LED DOWNLIGHT	LITHONIA LDN6 40/40 L06AR LSS MVOLT EZ10	HALO COMM HC630D010 / HM63040840 / 61WDC	6"	4000K	LED	120	3978	44		WHITE	RECESSED CEILING	10% DIMMING	WHITE PAINTED FLANGE
L7	4" RECESSED LED DOWNLIGHT	LITHONIA LDN4 40/15 L04AR LSS MVOLT EZ10	HALO COMM HC410D010 / HM40525840 / 41WDC	4"	4000K	LED	120	1444	20		WHITE	RECESSED CEILING	10% DIMMING	WET LOCATION LABEL, WHITE PAINTED FLANGE
L8	4' VAPOR TIGHT LED	PHILIPS V3W516840UNVDM	METALUX 4APVTLD-SL3C3		3500K	LED	120	3700	35			SURFACE CEILING		WET LOCATION LABEL
L9	WALL MOUNTED LED	BROWNLEE 7704-4-BL-C24-40K	SONNEMAN 7472.74-WL		4000K	LED	120	1400	23		WHITE	WALL FIELD VERIFY		WET LOCATION LABEL
L10	SURFACE MOUNTED LED PATIENT BATHROOMS	PROGRESS LIGHTING P7251 0903K9	ASD LIGHTING CORP ASD-LFMDR-10D16CC-NK		3000K	LED	120	1027	22		WHITE	SURFACE CEILING		
L14	SURFACE MOUNTED LED	LEVITON 49875	HALO LIGHTING VT0840L		4000K	LED	120		14			SURFACE MOUNTED IN ATTIC		100 WATT EQUIVALENT A19 LED LAMP, WIRE GUARD
X1	LED EXIT FIXTURE	LITHONIA EXR LED M6	SURE-LITES APX7R			LED	120		1		WHITE	WALL OR CEILING AS INDICATED		SINGLE FACE, 90 MINUTE BATTERY BACKUP
X2	LED EXIT FIXTURE	LITHONIA EXR LED M6	SURE-LITES APX7R			LED	120		1		WHITE	WALL OR CEILING AS INDICATED		DOUBLE FACE, 90 MINUTE BATTERY BACKUP
E1	EMERGENCY FIXTURE	LITHONIA ELM4L	SURE-LITES APEL			LED	120	640	3		WHITE	WALL AT 7'-6"		90 MINUTE BATTERY BACKUP
E2	EMERGENCY FIXTURE WET LOCATION	LITHONIA ELM4L ELM4L WPVS LRG W	SURE-LITES APEL			LED	120	640	3		WHITE	WALL AT 7'-6"		90 MINUTE BATTERY BACKUP WET LOCATION LABEL
GENERAL NOTES: A. THE CONTRACTOR SHALL VERIFY THE LEAD TIME OF ALL PRODUCTS SPECIFIED IN THIS SCHEDULE AT THE TIME OF PACKAGE QUOTE. B. DURING THE BID PROCESS, THE CONTRACTOR SHALL NOTIFY THE ARCHITECT/ENGINEER OF ANY DELIVERY/SCHEDULING ISSUES. C. NO SUBSTITUTIONS WILL BE ALLOWED DUE TO THE LACK OF COORDINATION OF DELIVERY DATES AND CONSTRUCTION SCHEDULE AFTER BID. D. ALL EXPEDITED EXPENSES SHALL BE THE RESPONSIBILITY OF THE CONTRACTORS. E. THE ELECTRICAL CONTRACTOR MUST RECEIVE APPROVAL FOR ALL LIGHTING FIXTURES FROM THE ARCHITECT/OWNER PRIOR TO PURCHASE AND ROUGH-IN. F. FIXTURES INSTALLED IN CEILINGS INDICATED ON THE ARCHITECTURAL PLANS AS HAVING INSULATION IN CONTACT WITH THE CEILING SURFACE MUST BE MANUFACTURER RATED "IC". G. ALL LIGHTING FIXTURES PENETRATING RATED FLOOR/CEILING ASSEMBLY MUST BE PROVIDED WITH ACCESSORIES TO MAINTAIN ASSEMBLY FIRE RATING. REFER TO ARCHITECTURAL DRAWINGS FOR ADDITIONAL RATINGS. H. "NL" ADJACENT TO FIXTURE INDICATES AN UNSWITCHED 24 HOUR NIGHT LIGHT. THE FIXTURE MUST BE CONNECTED TO THE UNSWITCHED INDICATED CIRCUIT. I. LED MODULES MUST BE REPLACEABLE. J. ACRYLIC PRISMATIC LENSES MUST BE 0.125" NOMINAL MINIMUM THICKNESS. K. ALL EXIT AND EMERGENCY FIXTURES MUST COMPLY WITH NCSCB STANDARDS AND HAVE AUTOMATIC TESTING DEVICES. L. LED EMERGENCY BATTERY MUST PROVIDE A MINIMUM OF 90% RATED FIXTURE OUTPUT FOR 90 MINUTES MINIMUM. M. THE ABOVE FIXTURE TYPES ARE LISTED AS THE DESIGN BASIS. IF THE CONTRACTOR ELECTS TO SUBMIT A FIXTURE OTHER THAN THE BASIS OF DESIGN FIXTURE, REQUIREMENTS OF NOTES O, AND P, APPLY. N. LIGHTING FIXTURES HAVE BEEN SELECTED AND SPECIFIED TO ACHIEVE REQUIRED/DESIRED ILLUMINATION LEVELS AND OTHER CHARACTERISTICS IN THEIR RESPECTIVE AREAS. SPECIFIED FIXTURES HAVE SPECIFIC CHARACTERISTICS WHICH MAY CREATE UNIQUE ILLUMINATION RESULTS ESSENTIAL TO THE PROJECT. LIGHTING FIXTURES PROVIDED MUST MEET THE AESTHETICS, DETAILS, AND SPECIFICATIONS STATED ABOVE AND IN THE DIVISION 16 SPECIFICATIONS, AND MOUNTING HEIGHTS AND SPACINGS SHOWN ON THE DRAWINGS. ANY DEVIATIONS FROM THE SPECIFIED FIXTURES MUST DEEM ALL PARTIES IN THE SUPPLY CHAIN AND CONTRACTOR RESPONSIBLE FOR PROVIDING DETAILED COMPARISONS OF THE SPECIFIED FIXTURE AND THE PROPOSED FIXTURE FOR THE ARCHITECT AND ENGINEER REVIEW IN DETERMINING EQUALITY. PROVIDE COMPLETE POINT BY POINT ILLUMINATION STUDIES FOR ALL SUBSTITUTIONS. O. SUBSTITUTIONS MAY BE APPROVED BY THE ARCHITECT AND ENGINEER IF THEY ARE JUDGED TO BE EQUAL TO THE SPECIFIED FIXTURES. "EQUAL" MAY INCLUDE, AT THE SOLE DISCRETION OF THE ARCHITECT AND ENGINEER, LENS MATERIAL AND CHARACTERISTICS, COLORS, REFLECTORS, HOUSING MATERIAL AND CONFIGURATION, FINISHES, PHOTOMETRICS, EFFICIENCY, OPTIONS, FUNCTIONALITY, ETC.														

WALL TYPE LEGEND	
	1 HOUR FIRE BARRIER WALL
	1 HOUR FIRE/SMOKE BARRIER WALL
	2 HOUR FIRE BARRIER WALL
	SMOKE RESISTANT WALL

CBHF

Engineers, PLLC

2246 Yaupon Drive

Wilmington, NC 28401

Phone: 910.791.4000

www.cbhfengineers.com

© Copyright 2026 CBHF Engineers, PLLC

NC# P-0506

120 BED
NURSING FACILITY
LIGHTING
FIXTURE SCHEDULE

David R. Polston - Architect
3806 Park Ave. Suite C, Wilmington, NC 28403
Architecture Planning Design

PRINCIPLE HEALTH CARE
WAKE COUNTY
Holly Springs, North Carolina

PRELIMINARY
PRICING ONLY
NOT FOR
CONSTRUCTION

2018 APPENDIX B BUILDING CODE SUMMARY

ELECTRICAL SUMMARY

ELECTRICAL SYSTEMS AND EQUIPMENT

METHOD OF COMPLIANCE:

ENERGY CODE:

☒

 PRESCRIPTIVE

☐

 PERFORMANCE

ASHRAE 90.1:

☐

 PRESCRIPTIVE

☐

 PERFORMANCE

LIGHTING SCHEDULE (EACH FIXTURE TYPE)

LAMP TYPE REQUIRED IN FIXTURE: SEE FIXTURE SCHEDULE

NUMBER OF LAMPS IN FIXTURE: SEE FIXTURE SCHEDULE

BALLAST TYPE USED IN THE FIXTURE: SEE FIXTURE SCHEDULE

NUMBER OF BALLASTS IN FIXTURE: SEE FIXTURE SCHEDULE

TOTAL WATTAGE PER FIXTURE: SEE FIXTURE SCHEDULE

TOTAL INTERIOR WATTAGE: WHOLE BUILDING

ALLOWED = 63,307 WATTS

ADDITIONAL 10% = 56,976 WATTS

SPECIFIED = 54,402 WATTS

EXTERIOR ALLOWANCE:
(TRADEABLE SURFACES)

ALLOWED = 6,396 WATTS

SPECIFIED = 3,118 WATTS

(NON-TRADEABLE SURFACES:)

ALLOWED = N/A WATTS

SPECIFIED = N/A WATTS

(FIXTURE EFFICACY:) NOTE: GROUNDS LIGHTING, LANDSCAPE, AREA ETC...

FIXTURE

LUMENS WATTS / FIXTURE

LUMENS / WATT

L9

1,400

23

61

SB

425

7

61

SP3B

11,539

129

89

SP4A

12,402

129

96

SP4B

12,402

129

96

ADDITIONAL PRESCRIPTIVE COMPLIANCE

☐

 C406.2 MORE EFFICIENT HVAC EQUIPMENT PERFORMANCE

☒

 C406.3 REDUCED LIGHTING POWER DENSITY

☐

 C406.4 ENHANCED DIGITAL LIGHTING CONTROLS

☐

 C406.5 ON-SITE RENEWABLE ENERGY

☐

 C406.6 DEDICATED OUTSIDE AIR SYSTEM

☐

 C406.7 REDUCED ENERGY USE IN SERVICE WATER HEATING


NOT FINAL SUBJECT TO REVISION. NOT FOR PERMITTING, FABRICATION, MATERIAL OR EQUIPMENT PURCHASE, INSTALLATION, OR CONSTRUCTION. PRICING SHALL STATE ALL ASSUMPTIONS, EXCLUSIONS, ALLOWANCES, AND CONTINGENCIES AND SHALL BE RECONCILED WITH THE FINAL SIGNED AND SEALED DOCUMENTS.

WALL TYPE LEGEND

	1 HOUR FIRE BARRIER WALL
	1 HOUR FIRE/SMOKE BARRIER WALL
	2 HOUR FIRE BARRIER WALL
	SMOKE RESISTANT WALL

CBHF
Engineers, PLLC

2246 Yaupon Drive
Wilmington, NC 28401
Phone: 910.791.4000
www.cbhfengineers.com
© Copyright 2026 CBHF Engineers, PLLC NC# P-0506

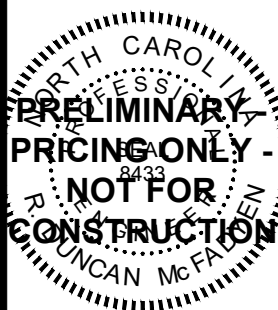

PRINCIPLE HEALTH CARE
WAKE COUNTY
Holly Springs, North Carolina


David R. Polston - Architect
3806 Park Ave. Suite C, Wilmington, NC 28403
Architecture Planning Design

120 BED
NURSING FACILITY
DECORATIVE LIGHTING
FIXTURE SCHEDULE

EL
0.2

DECORATIVE LIGHTING FIXTURE SCHEDULE													
MARK	DESCRIPTION	MANUFACTURER/SERIES (BASIS OF DESIGN)	NOM. SIZE	TEMP(oK)	LAMPS	VOLTS	DELIVERED LUMENS	WATTS	COLOR	MOUNTING HEIGHT	BALLAST/ DRIVER	REMARKS	
D1	WALL SCONCE	JAMES ALLEN QZBF8634 KENTON INDOOR LIGHT BAR	4.75"H 28.25"W	3000K	LED	120	1650	23	AGED BRASS	WALL MOUNTED 66" AFF			
D2	CEILING LIGHT FIXTURE	ALORA LIGHTING BRISBANE FM556216AGWH	16"DIA 4 1/8"H	3500K	LED	120		30	AGED GOLD/ WHITE	CEILING MOUNTED			3 - 60W E26 MEDIUM BULBS
D3	WALL SCONCE	ALORA LIGHTING WV355116 WYNWOOD INDOOR LIGHTING	15.75"H 3.68"W 5"EXT	3500K	LED	120		10	URBAN BRONZE	WALL MOUNTED 66" AFF			60W E26 MEDIUM BASE BULB
D4	VANITY LIGHT FIXTURE	PROGRESS LIGHTING MERRY COLLECTION THREE-LIGHT ETCHED GLASS BATH VANITY WALL LIGHT	24"W 10.5"H 6.5"D	3500K	LED	120		50	MATTE BLACK	WALL MOUNTED ABOVE MIRROR			3 - 100W E26 MEDIUM BASE BULBS
D5	SEMI-FLUSH CEILING FIXTURE	FOSS & MAIN FLAIRE LINEN BLEND SEMI-FLUSH MOUNT	9.5"H 22"DIA	3500K	LED	120		50	BRUSHED NICKEL/ OFF WHITE	CEILING MOUNTED			5 - 60W E26 MEDIUM BASE BULBS
D6	MINI-PENDANT	JAMES ALLEN INEZ 13" WIDE PENDANT	11.75"H 13.25"DIA	3500K	LED	120		10	BLACK MATTE/ HERITAGE GOLD	SUSPENDED 75" AFF			60W E26 MEDIUM BASE BULB
D7	CEILING FIXTURE	ALORA LIGHTING SF473710 BETTY INDOOR LIGHTING	13.375"H 13"W 13 13/16"D	3500K	LED	120		10	AGED GOLD/ OPAN WHITE	CEILING MOUNTED			60W E26 MEDIUM BASE BULB
D8	VANITY LIGHT FIXTURE PUBLIC RESTROOMS	CAPITAL LIGHTING 652621BN THEO DUAL SCONCE	5"W 20.5"H	3500K	LED	120		34	BRUSHED NICKEL	WALL MOUNTED ABOVE MIRROR			2 - 100W E26 MEDIUM BASE BULBS
D9	OVERBED LIGHT FIXTURE	AFX LIGHTING RANDOLPH COLLECTION LED OVERBED LIGHT	38"x 4"x 4.88"	3000K	LED	120	4050	60	JUTE/ SATIN NICKEL	WALL MOUNTED AT 5'-6" AFF			PROVIDE SWITCH
D10	VANITY LIGHT FIXTURE RESIDENT RESTROOMS	GENERATION LIGHTING 4424503EN3-962 HANFORD THREE LIGHT WALL	24"W 10.5"H 6.5"D	3000K	LED	120		28	BRUSHED NICKEL	WALL MOUNTED ABOVE MIRROR			3 - 9.3W A19 MEDIUM BASE BULBS
D11	CEILING FIXTURE RESIDENT RESTROOMS	PROGRESS LIGHTING EDESSA FLUSH MOUNT	16"DIA 4.5"H	3000K	LED	120		45	BRUSHED NICKEL	CEILING MOUNTED	10% DIMMING		3 - 15W E26 MEDIUM BASE BULBS
D12	WALL SCONCE	PROGRESS LIGHTING LED WALL BRACKET	4.75"W 11"H 2.75"D	3000K	LED	120	918	16	BRUSHED NICKEL	AS INDICATED ON ARCHITECTURAL DRAWINGS			
D13	CEILING FIXTURE RESIDENT RESTROOMS	PROGRESS LIGHTING APOGEE P350071-009-30 CLOSE-TO-CEILING LIGHT	21"DIA 4.5"H	3000K	LED	120	2550	41	BRUSHED NICKEL	CEILING MOUNTED			
D14	CHANDELIER	VISUAL COMFORT & CO. KLEE 6-LIGHT CHANDELIER	56"DIA 8.5"H	3000K	LED	120	3490	45.6	NIGHT-SHADE BLACK				
D15	CEILING FIXTURE	MILLENIUM LIGHTING LAPHIA THREE LIGHT SEMI-FLUSH MOUNT	15.75"DIA 11.25"H	3500K	LED	120		30	BRUSHED NICKEL, ETCHED OPAL				3 - 60W E26 MEDIUM BASE BULBS
GENERAL NOTES: A. THE CONTRACTOR SHALL VERIFY THE LEAD TIME OF ALL PRODUCTS SPECIFIED IN THIS SCHEDULE AT THE TIME OF PACKAGE QUOTE. B. DURING THE BID PROCESS, THE CONTRACTOR SHALL NOTIFY THE ARCHITECT/ENGINEER OF ANY DELIVERY/SCHEDULING ISSUES. C. NO SUBSTITUTIONS WILL BE ALLOWED DUE TO THE LACK OF COORDINATION OF DELIVERY DATES AND CONSTRUCTION SCHEDULE AFTER BID. D. ALL EXPEDITED EXPENSES SHALL BE THE RESPONSIBILITY OF THE CONTRACTORS. E. FIXTURES TO BE INSTALLED IN CEILINGS INDICATED ON THE ARCHITECTURAL PLANS AS HAVING INSULATION IN CONTACT WITH THE CEILING SURFACE, SHALL BE IC RATED BY MANUFACTURER. F. ACRYLIC PRISMATIC LENSES SHALL BE 0.125" NOMINAL MINIMUM THICKNESS. G. LED MODULES SHALL BE REPLACEABLE. H. ELECTRICAL CONTRACTOR SHALL RECEIVE APPROVAL FOR ALL LIGHTING FIXTURES FROM ARCHITECT/OWNER PRIOR TO PURCHASE AND ROUGH-IN. I. REFER TO ARCHITECTURAL DRAWINGS FOR ADDITIONAL RATINGS.													

NOT FINAL SUBJECT TO REVISION. NOT FOR PERMITTING. FABRICATION, MATERIAL OR EQUIPMENT PURCHASE, INSTALLATION, OR CONSTRUCTION. PRICING SHALL STATE ALL ASSUMPTIONS, EXCLUSIONS, ALLOWANCES, AND CONTINGENCIES AND SHALL BE RECONCILED WITH THE FINAL SIGNED AND SEALED DOCUMENTS.

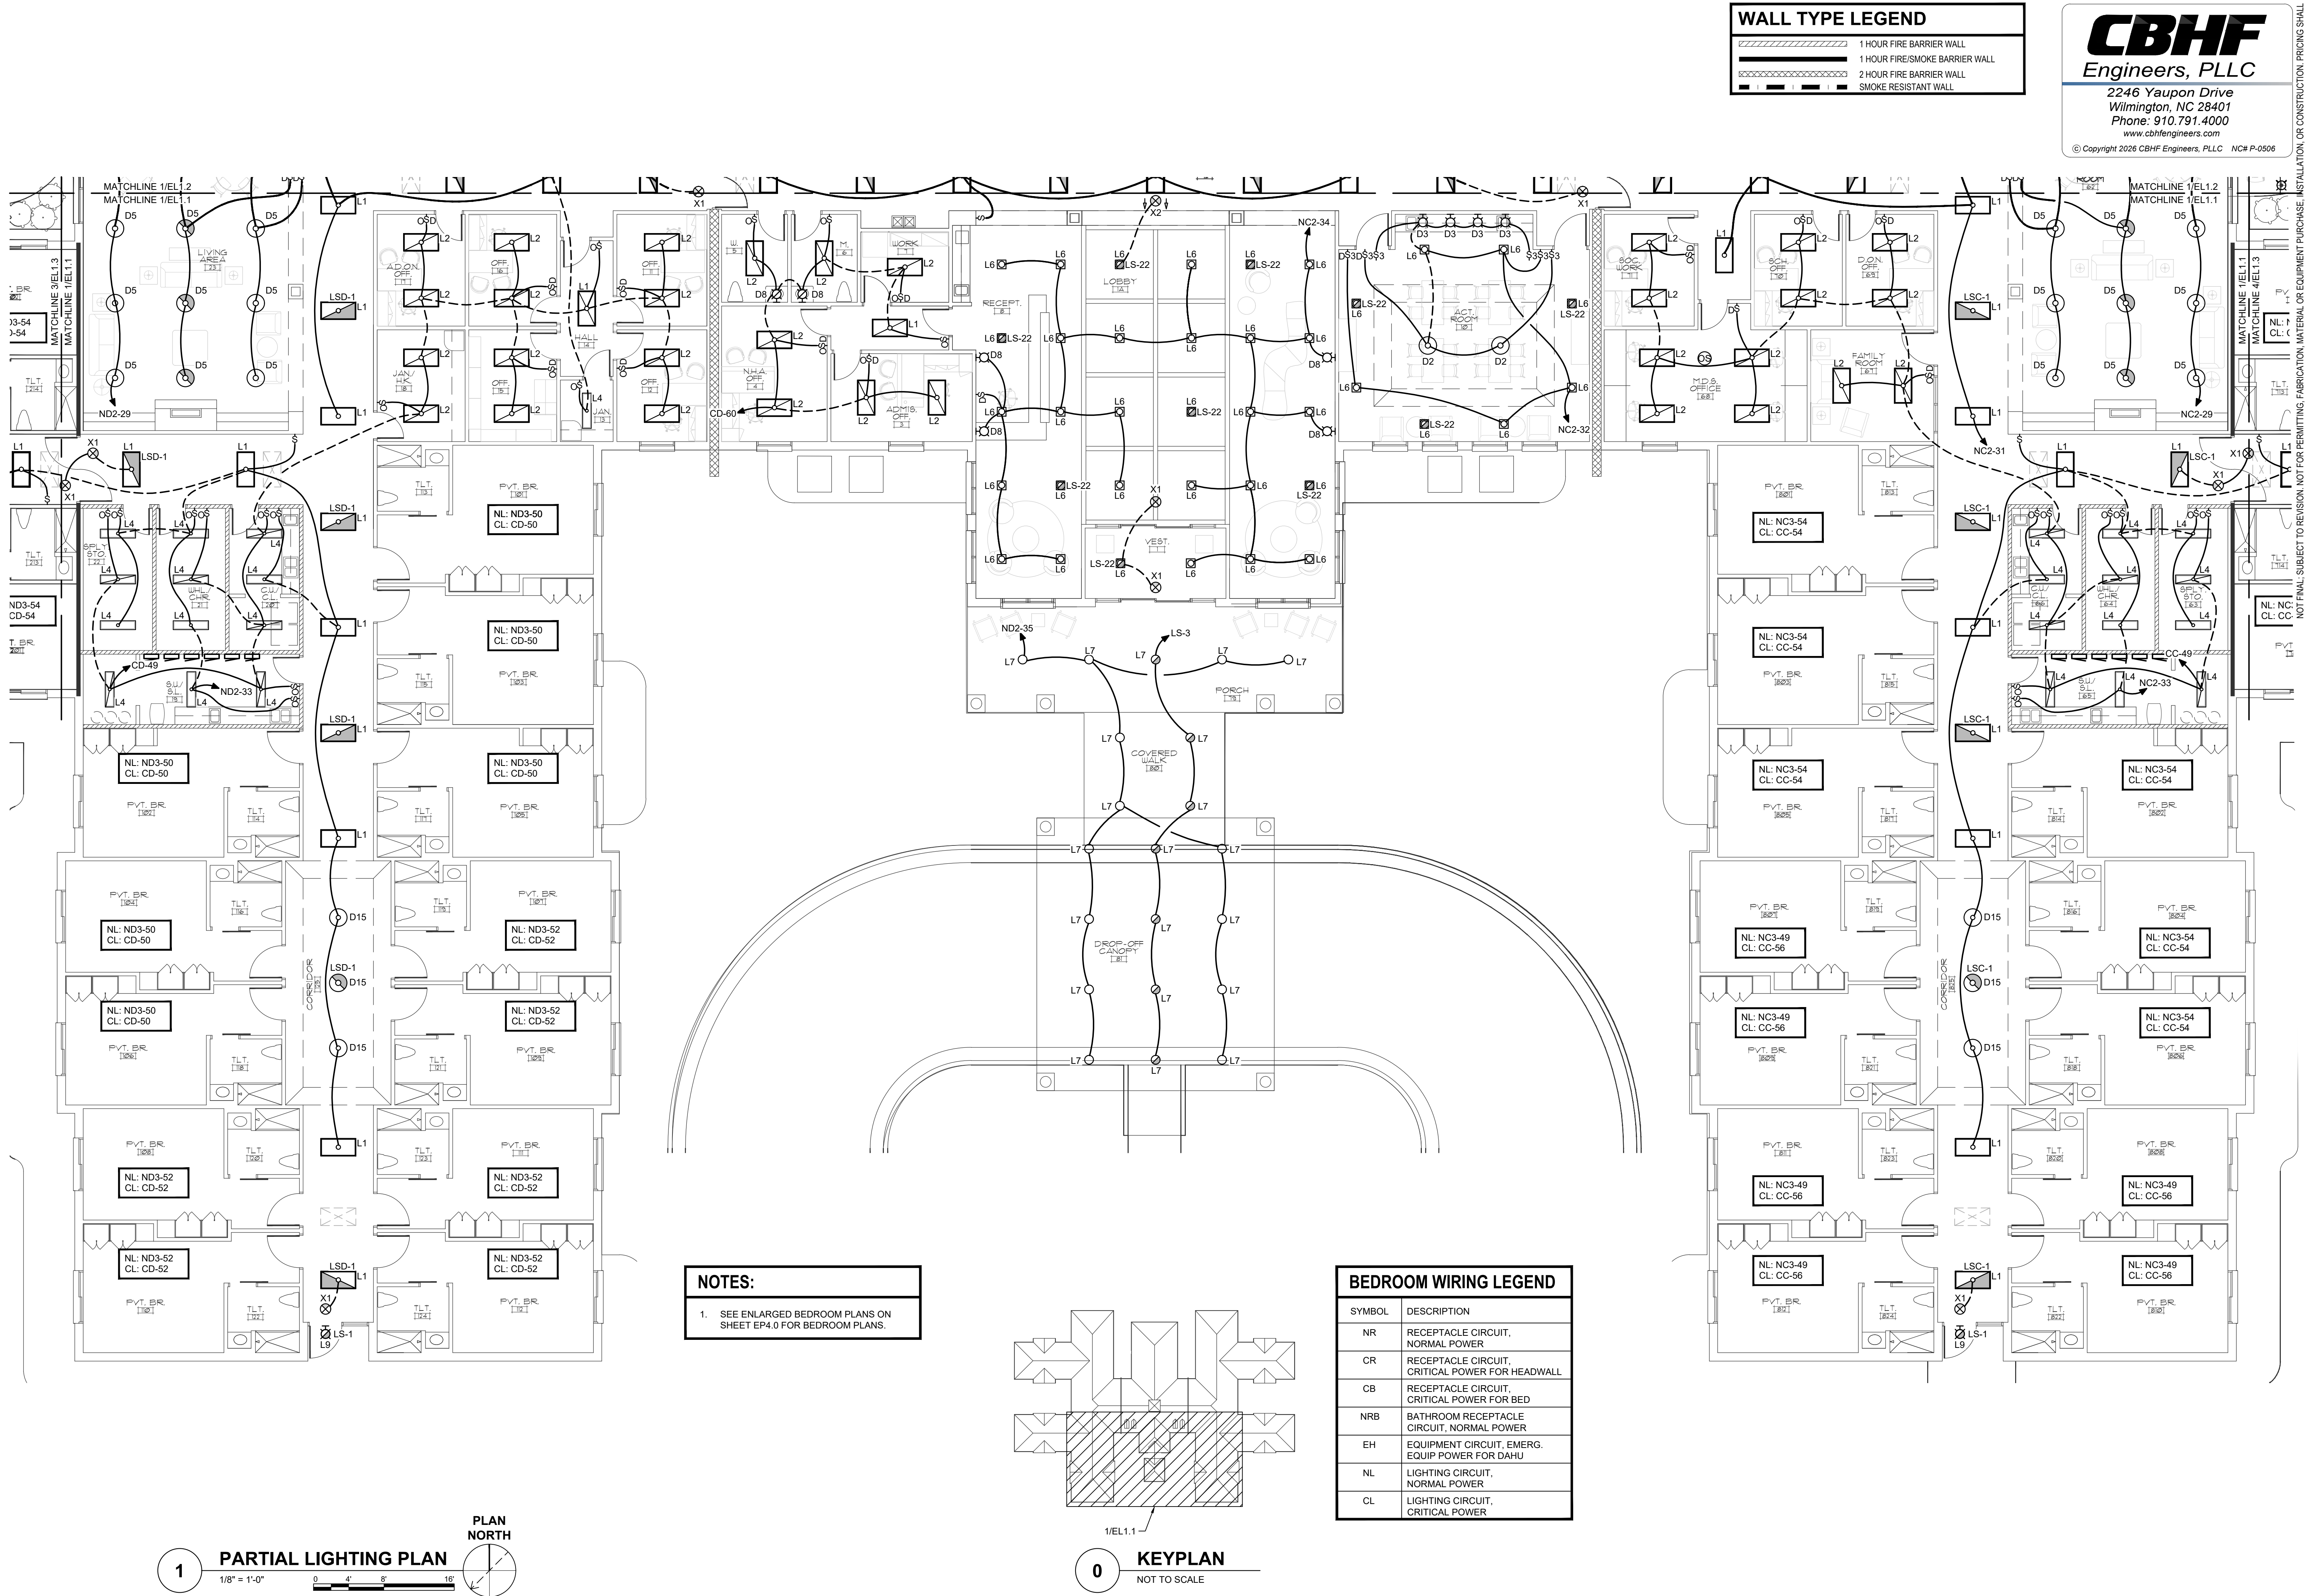

WALL TYPE LEGEND

- 1 HOUR FIRE BARRIER WALL
- 1 HOUR FIRE/SMOKE BARRIER WALL
- 2 HOUR FIRE BARRIER WALL
- SMOKE RESISTANT WALL

CBHF
Engineers, PLLC

2246 Yaupon Drive
Wilmington, NC 28401
Phone: 910.791.4000
www.cbhfengineers.com
© Copyright 2026 CBHF Engineers, PLLC NCH P-0506

PRELIMINARY
PRICING ONLY
NOT FOR
CONSTRUCTION

PRINCIPLE HEALTH CARE
WAKE COUNTY
Holly Springs, North Carolina

David R. Polston - Architect
3806 Park Ave. Suite C, Wilmington, NC 28403
Architecture Planning Design

120 BED
NURSING FACILITY
ELECTRICAL
PARTIAL LIGHTING PLAN

EL
1.1



NOTES:

- SEE ENLARGED BEDROOM PLANS ON SHEET EP4.0 FOR BEDROOM PLANS.

BEDROOM WIRING LEGEND

SYMBOL	DESCRIPTION
NR	RECEPTACLE CIRCUIT, NORMAL POWER
CR	RECEPTACLE CIRCUIT, CRITICAL POWER FOR HEADWALL
CB	RECEPTACLE CIRCUIT, CRITICAL POWER FOR BED
NRB	BATHROOM RECEPTACLE CIRCUIT, NORMAL POWER
EH	EQUIPMENT CIRCUIT, EMERG. EQUIP POWER FOR DAHU
NL	LIGHTING CIRCUIT, NORMAL POWER
CL	LIGHTING CIRCUIT, CRITICAL POWER

1 PARTIAL LIGHTING PLAN

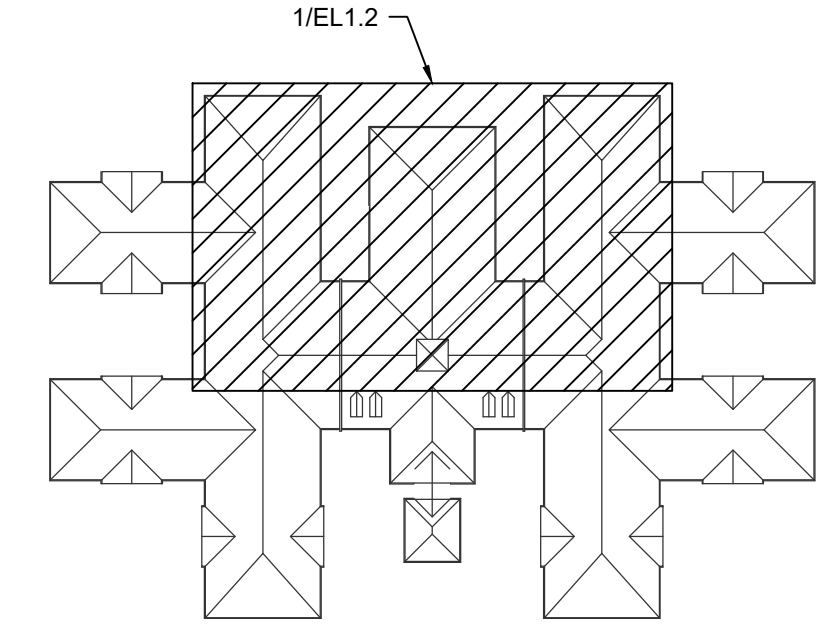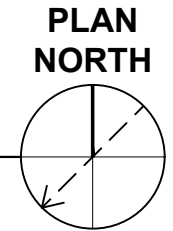


0 KEYPLAN
NOT TO SCALE

NOTES:
1. SEE ENLARGED BEDROOM PLANS ON SHEET EP4.0 FOR BEDROOM PLANS.

BEDROOM WIRING LEGEND	
SYMBOL	DESCRIPTION
NR	RECEPTACLE CIRCUIT, NORMAL POWER
CR	RECEPTACLE CIRCUIT, CRITICAL POWER FOR HEADWALL
CB	RECEPTACLE CIRCUIT, CRITICAL POWER FOR BED
NRB	BATHROOM RECEPTACLE CIRCUIT, NORMAL POWER
EH	EQUIPMENT CIRCUIT, EMERG. EQUIP POWER FOR DAHU
NL	LIGHTING CIRCUIT, NORMAL POWER
CL	LIGHTING CIRCUIT, CRITICAL POWER

WALL TYPE LEGEND	
	1 HOUR FIRE BARRIER WALL
	1 HOUR FIRE/SMOKE BARRIER WALL
	2 HOUR FIRE BARRIER WALL
	SMOKE RESISTANT WALL

CBHF
Engineers, PLLC
2246 Yaupon Drive
Wilmington, NC 28401
Phone: 910.791.4000
www.cbhfenr.com
© Copyright 2026 CBHF Engineers, PLLC NC# P-0506

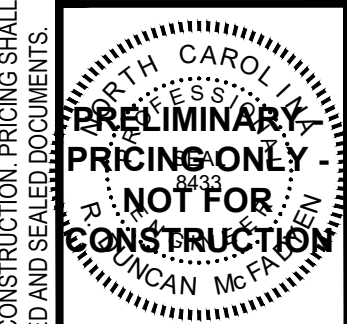






PRINCIPLE HEALTH CARE
WAKE COUNTY
Holly Springs, North Carolina

David R. Polston - Architect
3806 Park Ave. Suite C, Wilmington, NC 28403
Architecture Planning Design

120 BED
NURSING FACILITY
ELECTRICAL
PARTIAL LIGHTING PLAN

EL
1.2

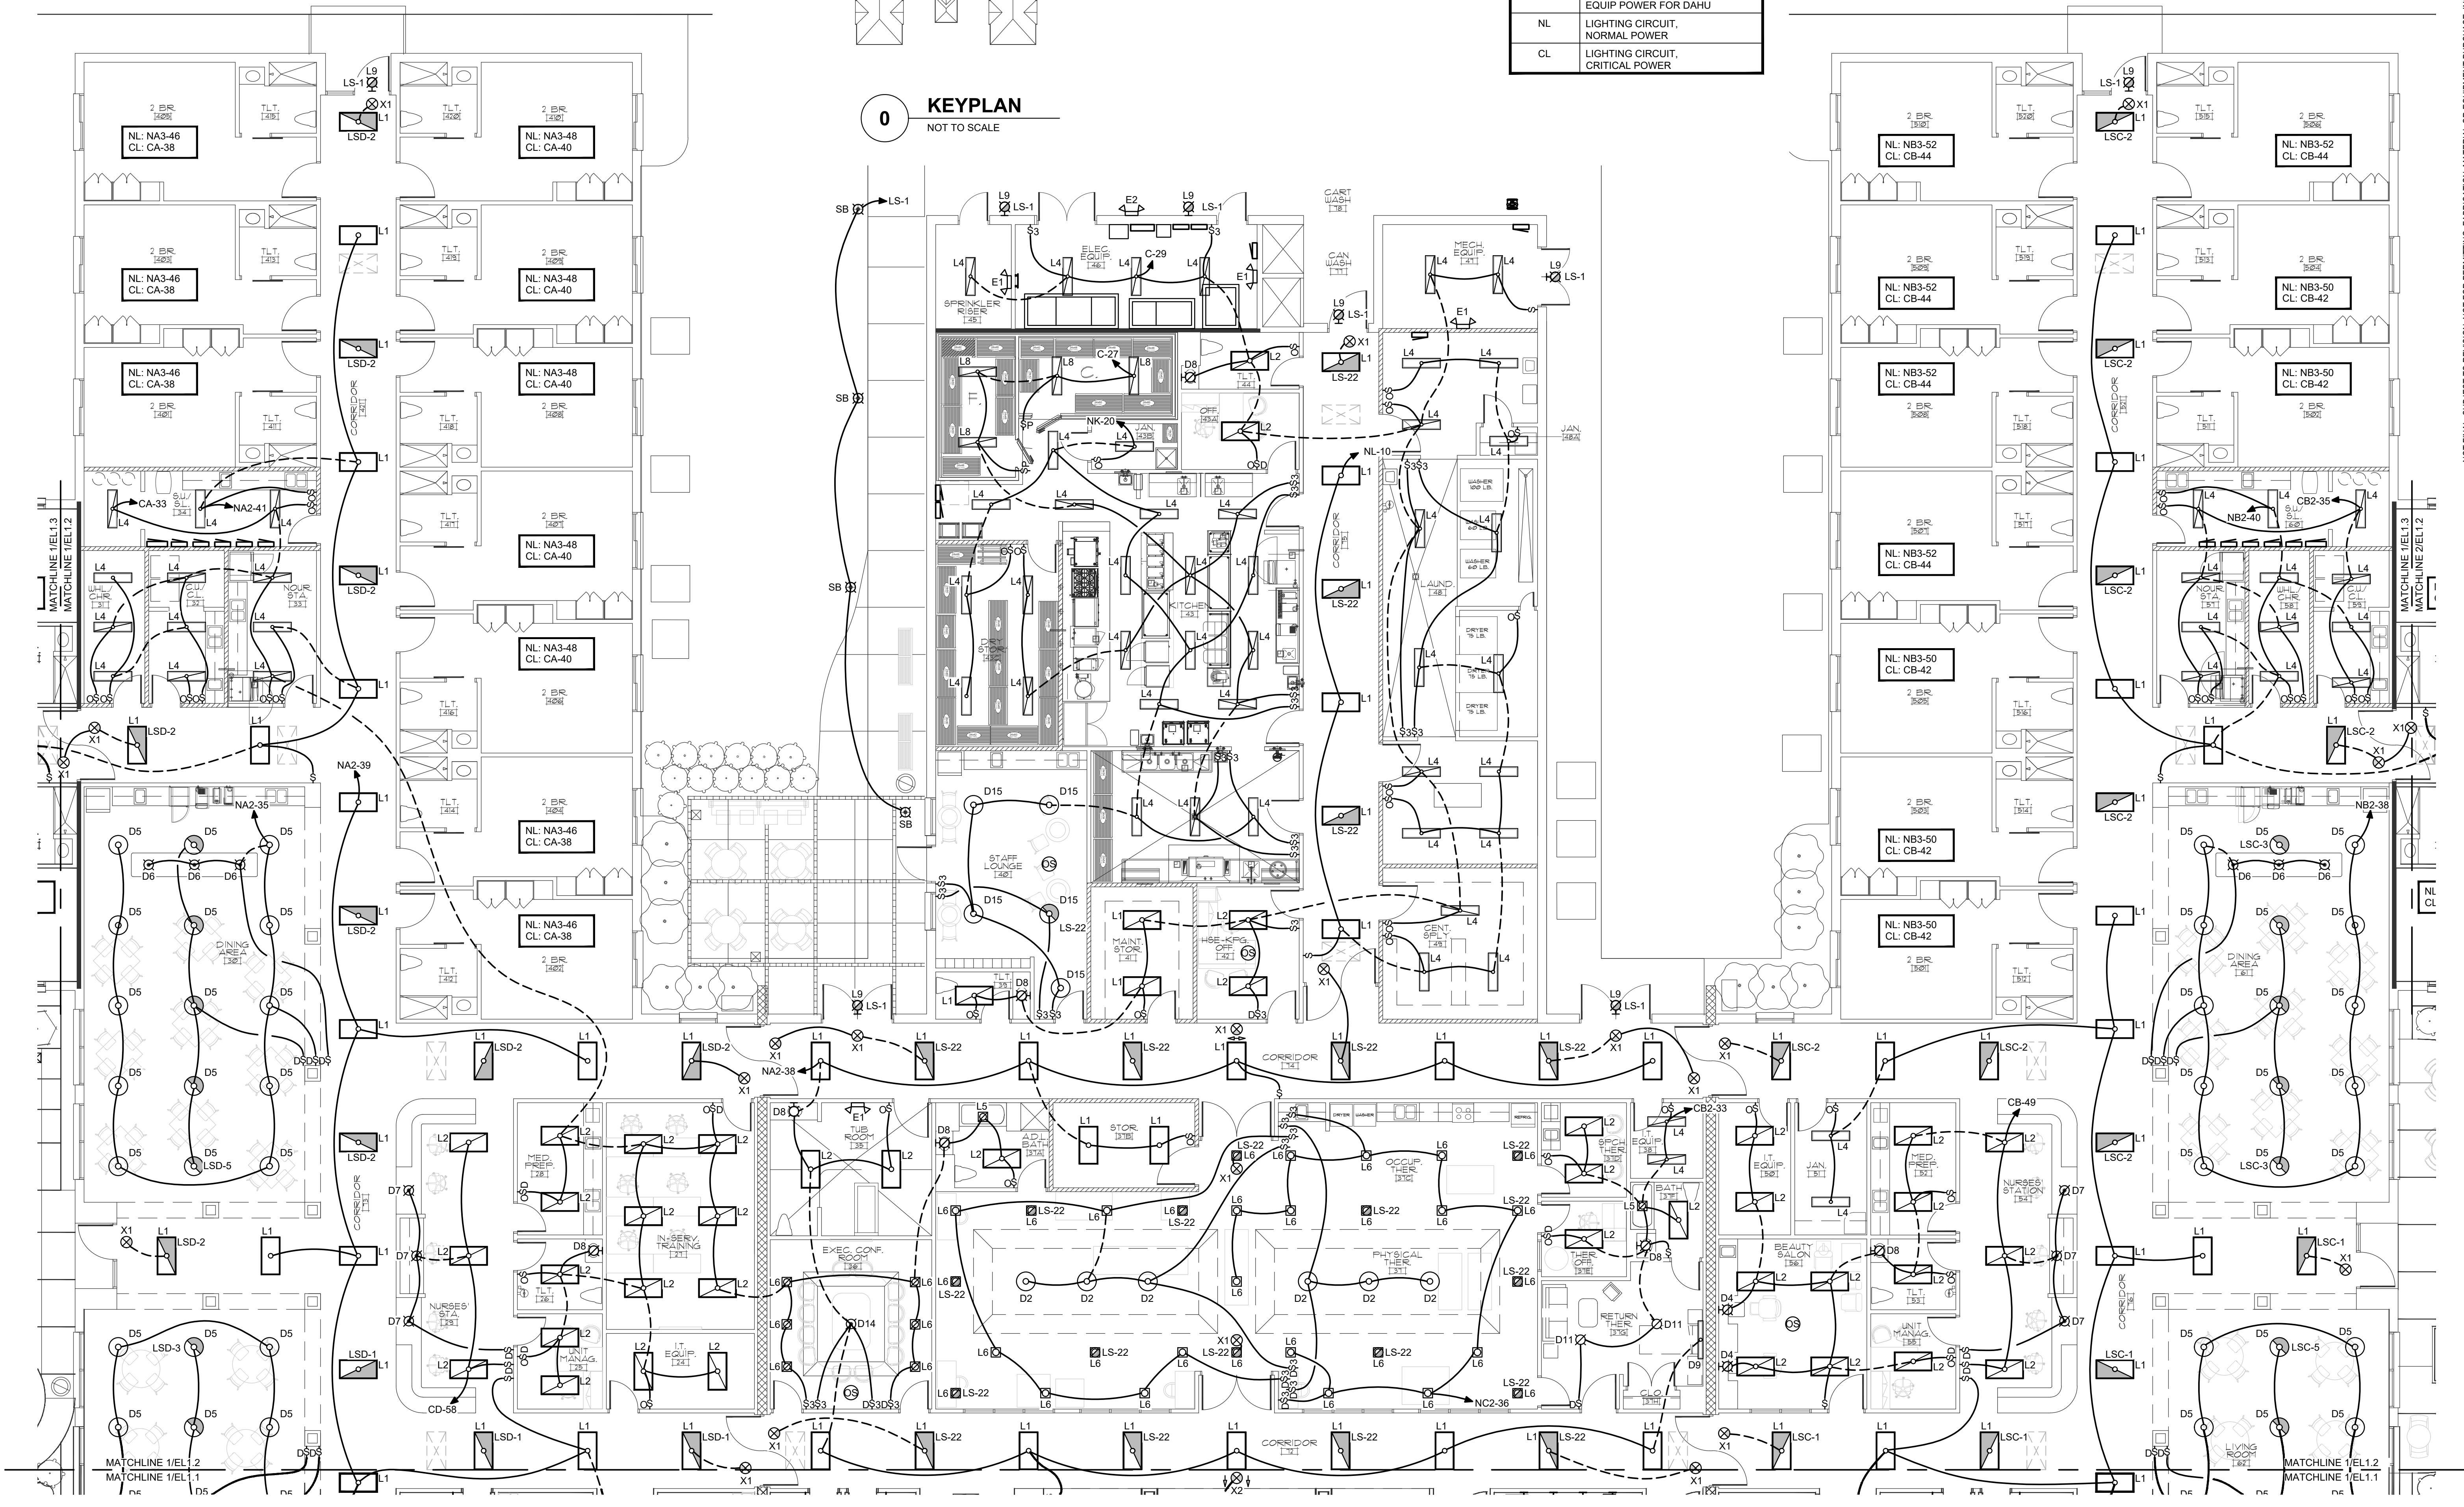

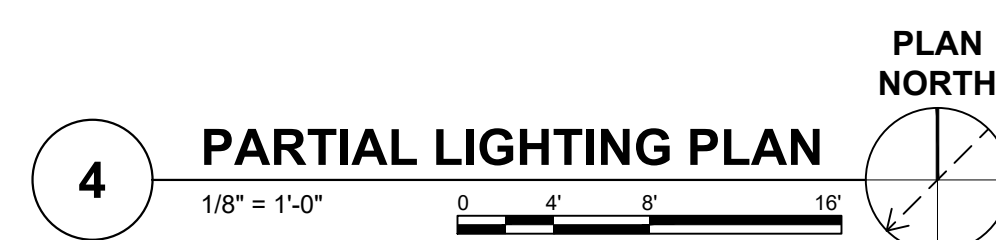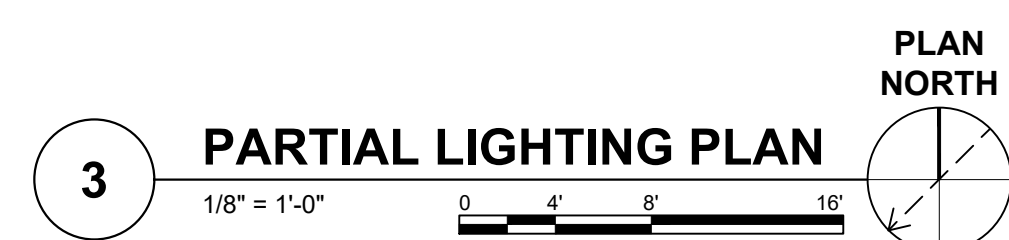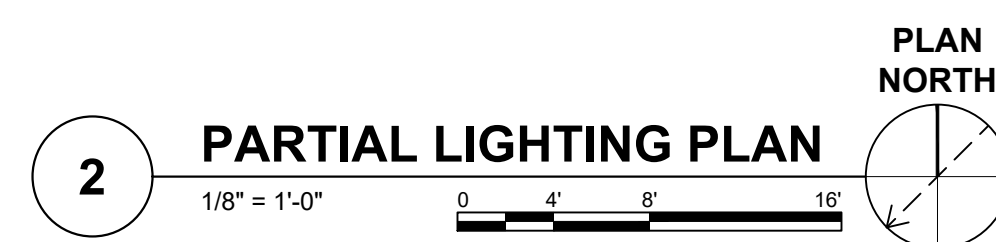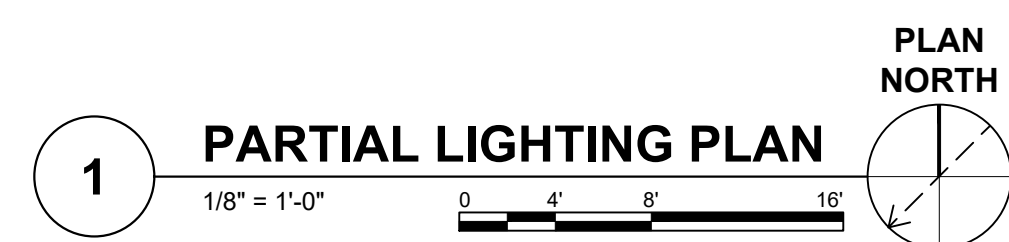

CBHF
Engineers, PLLC


2246 Yaupon Drive
Wilmington, NC 28401
Phone: 910.791.4000
www.cbhfengineers.com

© Copyright 2026 CBHF Engineers, PLLC NC# P-0506

NOTES:

1. SEE ENLARGED BEDROOM PLANS ON SHEET EP4.0 FOR BEDROOM PLANS.



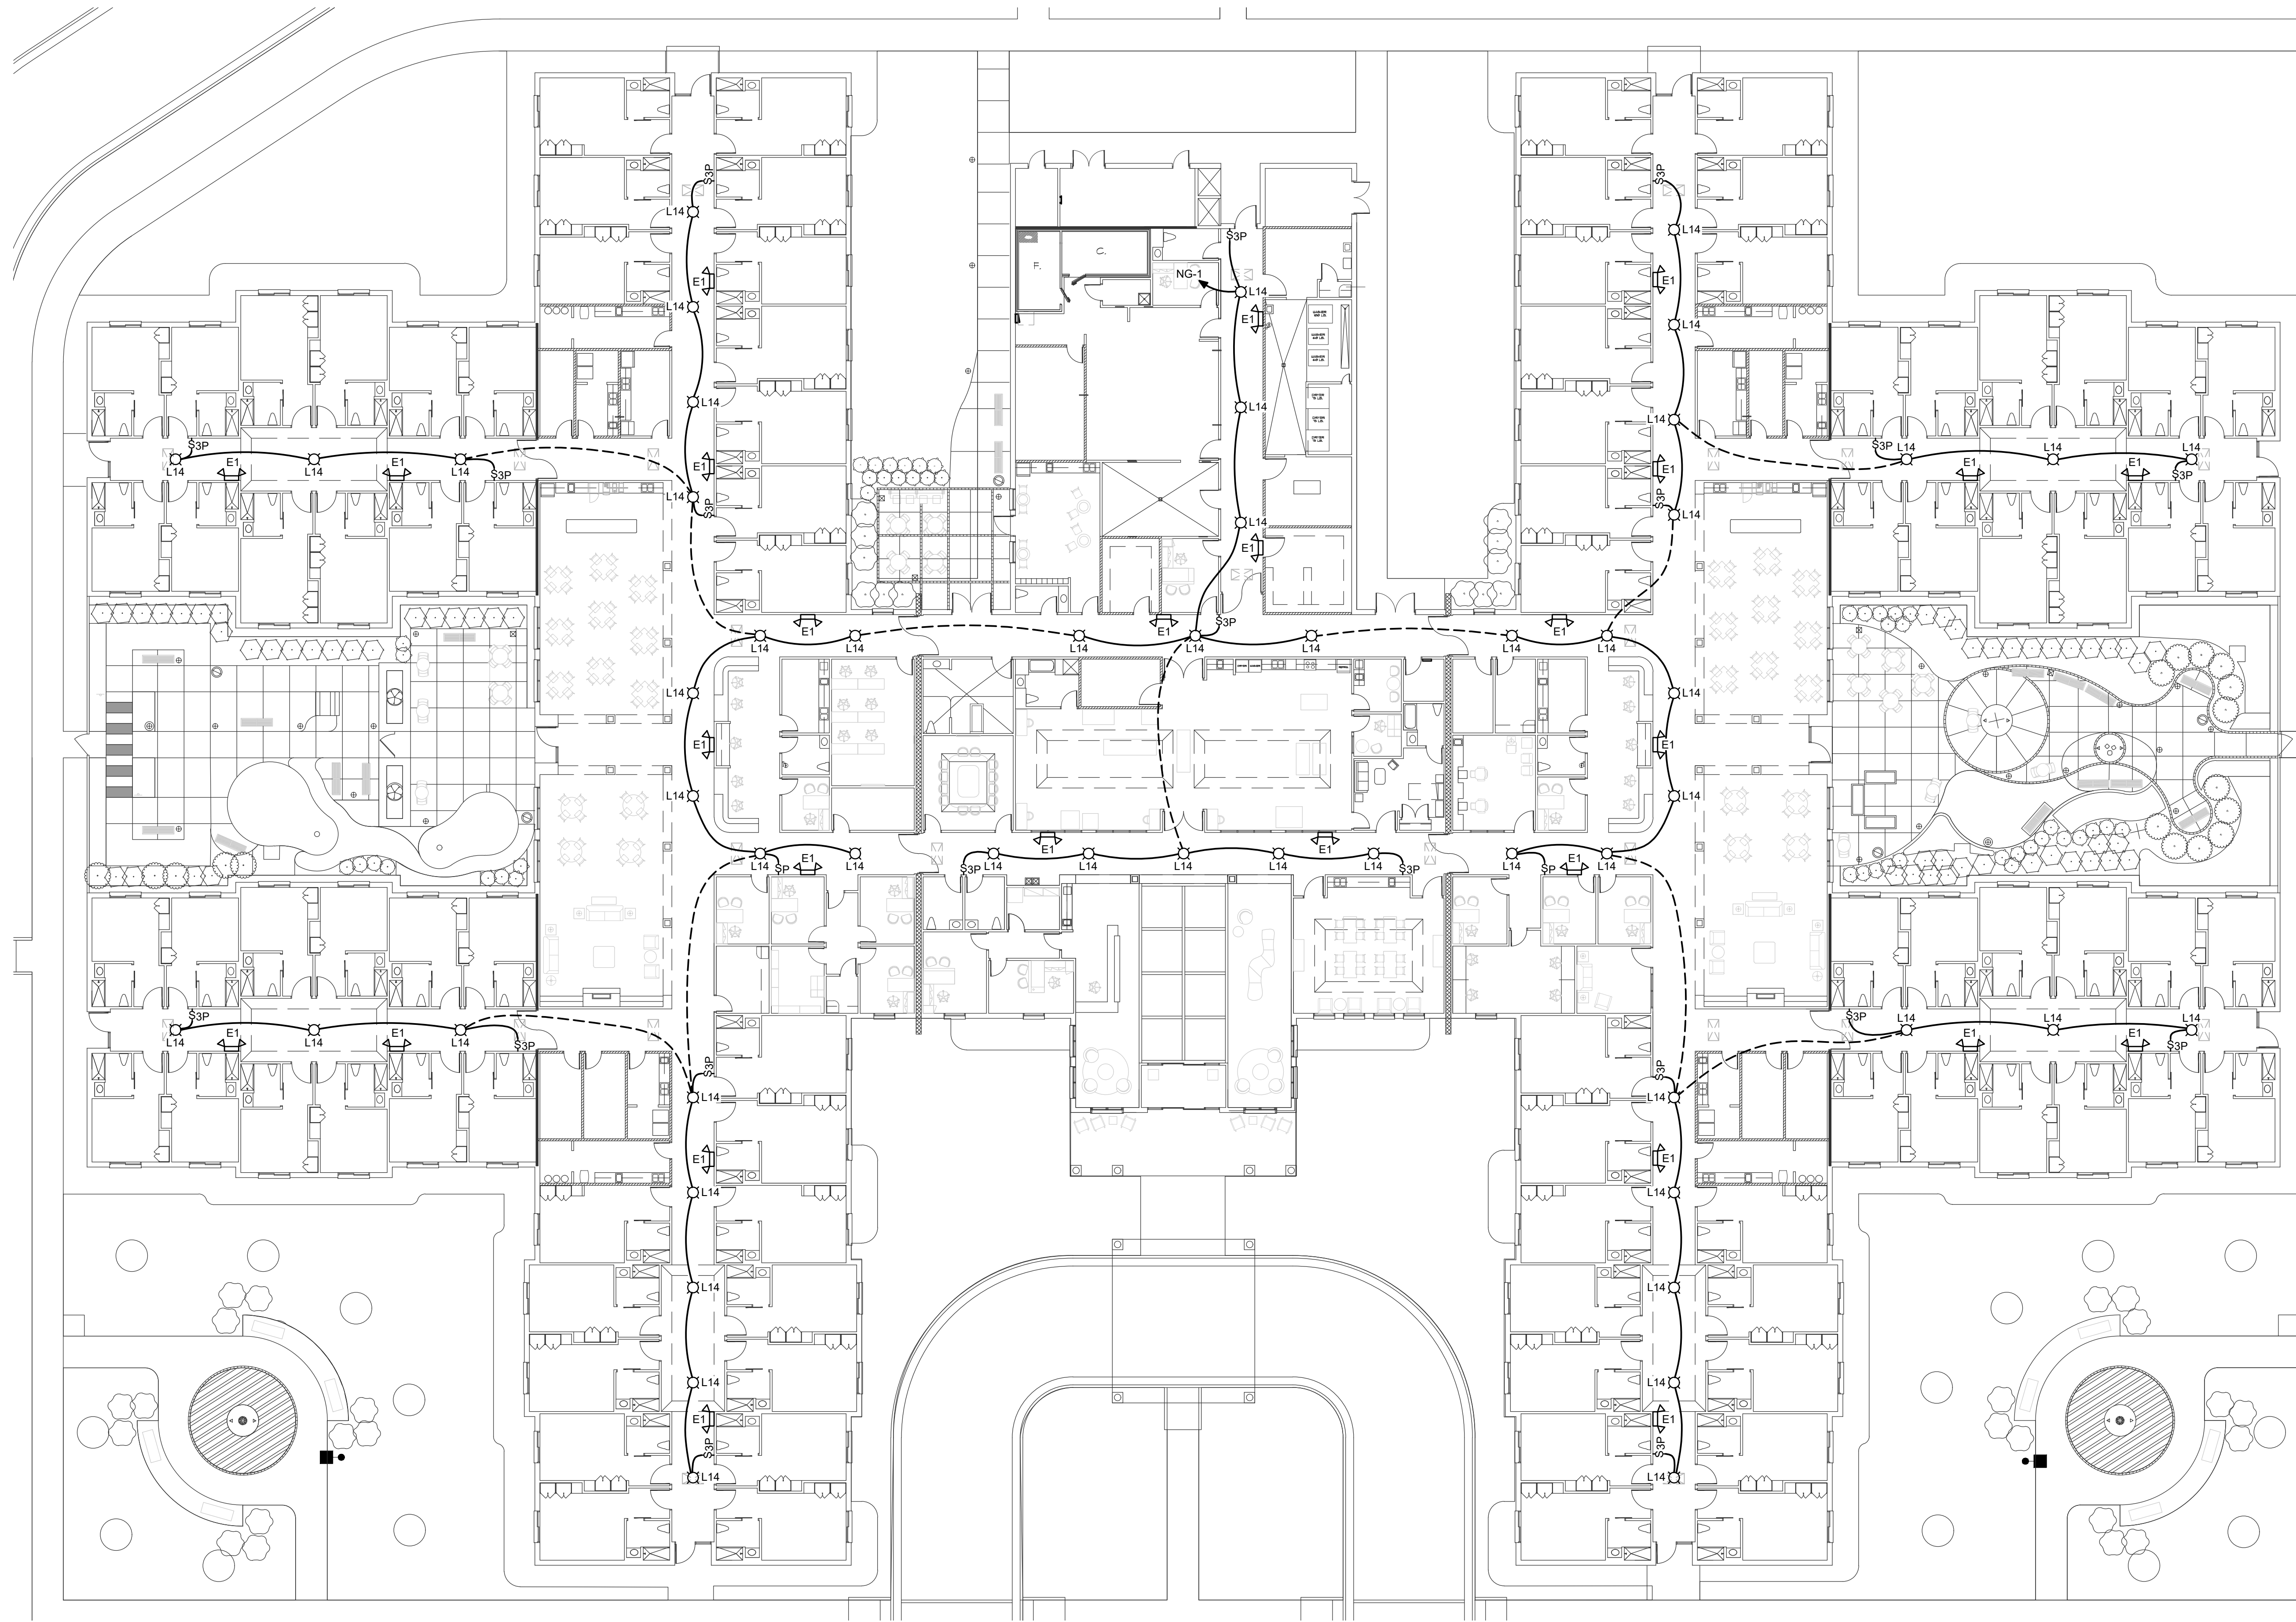

WALL TYPE LEGEND	
	1 HOUR FIRE BARRIER WALL
	1 HOUR FIRE/SMOKE BARRIER WALL
	2 HOUR FIRE BARRIER WALL
	SMOKE RESISTANT WALL

CBHF
Engineers, PLLC

2246 Yaupon Drive
Wilmington, NC 28401
Phone: 910.791.4000
www.cbhfengineers.com

© Copyright 2026 CBHF Engineers, PLLC NC# P-0506

NOT FINAL SUBJECT TO REVISION. NOT FOR PERMITTING, FABRICATION, MATERIAL OR EQUIPMENT PURCHASE, INSTALLATION, OR CONSTRUCTION. PRICING SHALL STATE ALL ASSUMPTIONS, EXCLUSIONS, ALLOWANCES, AND CONTINGENCIES AND SHALL BE RECONCILED WITH THE FINAL SIGNED AND SEALED DOCUMENTS.

PRINCIPLE HEALTH CARE
WAKE COUNTY
Holly Springs, North Carolina

David R. Polston - Architect
3806 Park Ave. Suite C, Wilmington, NC 28403
Architecture Planning Design

120 BED
NURSING FACILITY
ELECTRICAL
ATTIC POWER PLAN

EL
1.4

1


ATTIC LIGHTING PLAN

1/16" = 1'-0"

NOTE: COORDINATE ALL ATTIC LIGHTING FIXTURE SWITCH LOCATIONS WITH FINAL ATTIC ACCESS PANEL LOCATIONS, SEE ARCHITECTURAL SHEETS

LOW VOLTAGE SYSTEMS ELECTRICAL COORDINATION NOTES


1. THE ELECTRICAL CONTRACTOR SHALL COORDINATE ELECTRICAL WORK REQUIRED BY THE OWNER AND THE GENERAL CONTRACTOR.
2. THE ELECTRICAL CONTRACTOR SHALL COORDINATE LOCATIONS OF ELECTRICAL EQUIPMENT INCLUDING RECEPTACLES, LIGHTING FIXTURES, ETC. WITH THE LOW VOLTAGE DEVICES AND EQUIPMENT.
3. SEE SPECIFICATIONS SECTIONS 16041 – PAGING SYSTEM, 16042 – NURSE CALL SYSTEM, 16043 – TELEPHONE AND DATA RACEWAY SYSTEM, 16044 – ACCESS CONTROL/SPECIAL LOCKING (MAG LOCK) RACEWAY SYSTEM, 16045 – CABLE TELEVISION RACEWAY SYSTEM, 16046 – SECURITY CAMERA RACEWAY SYSTEM, 16047 – AIPHONE SYSTEM RACEWAY SYSTEM AND 16049 – ELECTRICAL WORK IN CONNECTION WITH OTHER CONTRACTS FOR ADDITIONAL REQUIREMENTS AND CONTRACTOR RESPONSIBILITIES WITH REGARD TO THESE SYSTEMS.
4. THE CONTRACTOR SHALL PROVIDE, AS PART OF THIS CONTRACT, SOURCES OF POWER; POWER, RECEPTACLES, CONTROL AND COMMUNICATIONS CONDUCTORS, CABLES AND RACEWAYS; EMPTY RACEWAYS; JUNCTION, OUTLET AND PULL BOXES; MOUNTING HARDWARE; FINAL CONNECTIONS; CONNECTION HARDWARE; TESTING AND TESTING SUPPORT; ETC., FOR THE LOW VOLTAGE SYSTEMS AS SHOWN ON THE CONTRACT DRAWINGS.

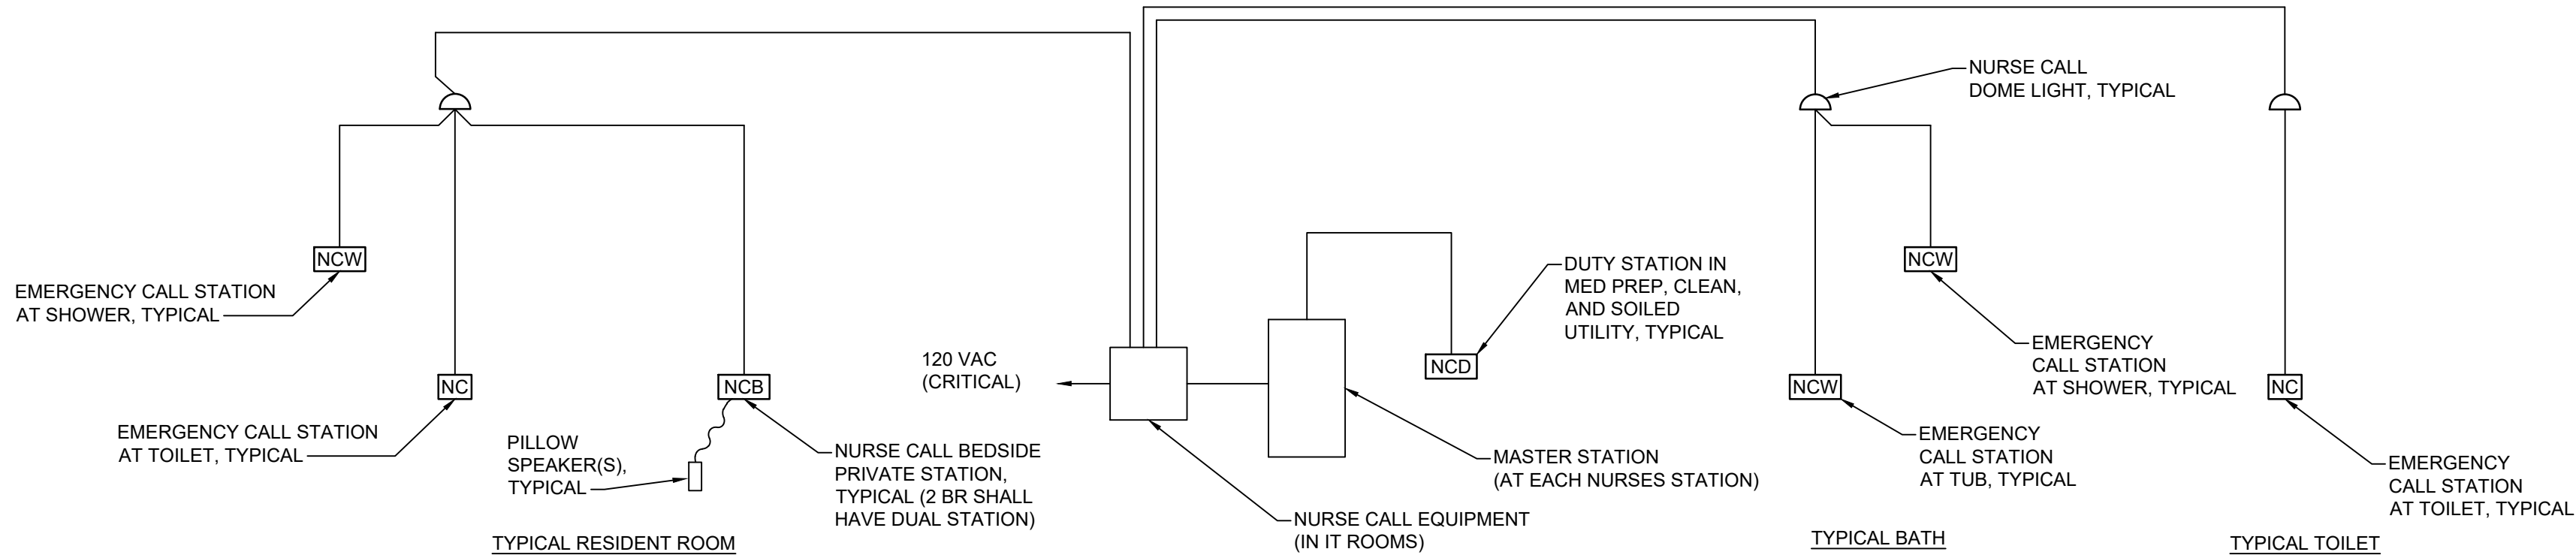

- NOTES:
- NURSE CALL SYSTEM CABLING SHALL BE ROUTED EXPOSED IN ATTIC SPACE. PROVIDE 3/4" RACEWAY FROM ALL WALL MOUNTED DEVICES TO ATTIC SPACE AND BETWEEN DEVICES AND EQUIPMENT AS REQUIRED.
 - RISER DIAGRAM IS DEPICTIVE AND FUNCTIONAL ONLY. ALL DEVICES ARE NOT SHOWN.

1 FUNCTIONAL NURSE CALL RISER DIAGRAM

NOT TO SCALE

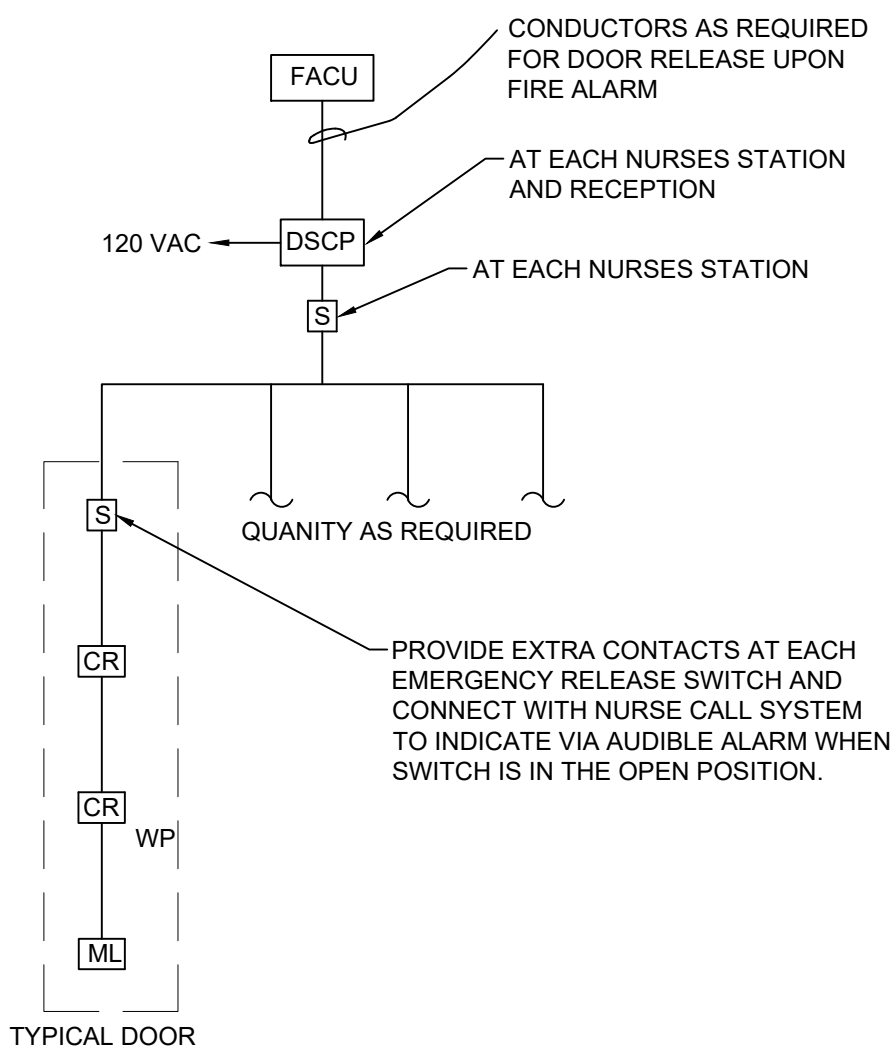

- NOTES:
- MAGNETIC LOCK SYSTEM CABLING SHALL BE ROUTED EXPOSED IN ATTIC SPACE. PROVIDE 3/4" RACEWAY FROM ALL WALL MOUNTED DEVICES TO ATTIC SPACE AND BETWEEN DEVICES AND EQUIPMENT AS REQUIRED.
 - RISER DIAGRAM IS DEPICTIVE AND FUNCTIONAL ONLY. ALL DEVICES ARE NOT SHOWN.

2 FUNCTIONAL MAGNETIC LOCK DOOR SYSTEM

NOT TO SCALE

SYSTEMS LEGEND

SYMBOL	DESCRIPTION
NURSE CALL SYSTEM, SEE SPECIFICATIONS SECTION 16042	
NCB	NURSE CALL BED STATION
NCB _D	NURSE CALL DUAL BED STATION
ND	NURSE CALL DOME LIGHT
ND _Z	NURSE CALL ZONE LIGHT
NCD	NURSE CALL DUTY STATION
NCS	NURSE CALL STAFF STATION
CCL	NURSE CALL CODE LIGHT
NCM	NURSE CALL MASTER STATION
NC	NURSE CALL STATION WITH PULL CORD
NCW	NURSE CALL STATION WITH PULL CORD, WEATHERPROOF, UL LISTED FOR SHOWERS
CCA	CODE CALL ANNUNCIATOR
CCB	CODE CALL BUTTON
LED	LED NURSE CALL ALPHANUMERIC ANNUNCIATOR, ARROWS INDICATE (2) SIDED, WALL OR CEILING MOUNTED AS SHOWN ON PLANS
LED	LED NURSE CALL ALPHANUMERIC ANNUNCIATOR, ARROW INDICATE (1) SIDED, WALL OR CEILING MOUNTED AS SHOWN ON PLANS
PAGING SYSTEM, SEE SPECIFICATIONS SECTION 16041	
S	CEILING MOUNTED SPEAKER
S _T	WALL MOUNTED SPEAKER
V	SPEAKER VOLUME CONTROL, 42" AFF
MAGNETIC LOCK SYSTEM	
CR	CARD READER
S	EMERGENCY RELEASE PULL STATION
ML	MAG LOCK
DSCP	DOOR SECURITY CONTROL PANEL
ES	ELECTRIC STRIKE
RE	REQUEST TO EXIT
PIR	MOTION SENSOR
SECURITY SYSTEM	
IC	SECURITY CAMERA

(SYMBOLS SHOWN FOR REFERENCE ONLY AND MAY NOT IMPLY CONTRACTUAL REQUIREMENTS)

NOTE: NURSE CALL, PAGING, MAGNETIC LOCK, AND SECURITY SYSTEMS CABLING SHALL BE ROUTED EXPOSED IN ATTIC SPACE. PROVIDE 4" x 4" x 2 1/8" BOX AND 3/4" MINIMUM RACEWAY FROM ALL WALL MOUNTED DEVICES TO ATTIC SPACE AND BETWEEN DEVICES AND EQUIPMENT AS REQUIRED.

ATTIC LOW VOLTAGE SYSTEMS CABLE INSTALLATION NOTES:

- ALL LOW VOLTAGE SYSTEM CABLE INSTALLED FREE RUN IN THE ATTIC SHALL BE INSTALLED ON J HOOKS. CABLES SHALL BE INSTALLED IN A MANNER TO PROTECT THE CABLES FROM DAMAGE DURING INSTALLATION. FACILITATE CABLE MANAGEMENT AND IDENTIFICATION, AND PROVIDE A NEAT AND GROOMED APPEARANCE.
- EACH CABLE SYSTEM SHALL BE INSTALLED AND SUPPORTED INDEPENDENTLY.
- CABLING SHALL BE INSTALLED IN STRAIGHT PATHS IN A NEAT AND ORDERLY FASHION FOLLOWING MAINTENANCE WALKWAYS AND AT NINETY-DEGREE ANGLES. DIAGONAL, BEELINE AND OR NON-SUPPORTED CABLING ARE UNACCEPTABLE. CABLING SHALL BE ROUTED AS HIGH AS POSSIBLE AND ABOVE OTHER BUILDING FACILITIES IN THE PATH WITH THE LEAST OBSTRUCTIONS IN THE SPACE. PATHWAYS SHALL BE AT LEAST 2 FEET AWAY FROM ALL LIGHTING FIXTURES AND OTHER POTENTIAL EMF SOURCES. CABLES SHALL NOT BE STRAPPED TO ELECTRICAL POWER CONDUITS, PIPING OR OTHER SYSTEMS. THE PLACING OF CABLE TIES SHALL NOT DEFORM THE CABLES.
- THE CABLE SUPPORT STRUCTURE SHALL UTILIZE APPROVED J HOOK CABLE SUPPORTS AND BE SIZED TO ACCOMMODATE CHANGE. J HOOK TYPE CABLE SUPPORTS SHALL BE SECURELY FASTENED TO THE BUILDING STRUCTURE AND BE SPACED AT A MAXIMUM DISTANCE OF FOUR (4) FEET SO THAT SAG BETWEEN SUPPORTS DOES NOT EXCEED 12 INCHES. ALL J HOOKS SHALL BE SIZED WITH 20% SPARE CAPACITY. ALL ATTACHMENT HARDWARE SHALL BE APPROVED FOR THE TYPE OF INSTALLATION AND MAXIMUM LOAD RATING OF THE PRODUCTS INSTALLED.
- ALL PENETRATIONS THROUGH WALL AND CEILINGS SHALL BE SLEEVED. ALL SLEEVES SHALL HAVE PERMANENTLY ATTACHED PLASTIC BUSHINGS. SLEEVES SHALL BE SIZED TO ACCEPT 50% GROWTH. ALL SLEEVES SHALL BE FIRE-STOPPED USING THIRD PARTY TESTING AGENCY APPROVED METHODS AND SHALL MAINTAIN ASSEMBLY FIRE RATINGS.
- THE ELECTRICAL CONTRACTOR SHALL COORDINATE ELECTRICAL WORK REQUIRED BY THE OWNER'S LOW VOLTAGE SYSTEMS VENDOR'S DRAWINGS, THE OWNER AND THE GENERAL CONTRACTOR.
- THE ELECTRICAL CONTRACTOR SHALL COORDINATE LOCATIONS OF ELECTRICAL EQUIPMENT INCLUDING RECEPTACLES, LIGHTING FIXTURES, ETC. WITH THE LOW VOLTAGE DEVICES AND EQUIPMENT SHOWN ON THE LOW VOLTAGE SYSTEMS VENDOR'S DRAWINGS.
- SEE SPECIFICATIONS SECTIONS 16041 - PAGING SYSTEM, 16042 - NURSE CALL SYSTEM, 16043 - TELEPHONE AND DATA RACEWAY SYSTEM, 16044 - ACCESS CONTROL/SPECIAL LOCKING (MAG LOCK) RACEWAY SYSTEM, 16045 - CABLE TELEVISION RACEWAY SYSTEM, 16046 - SECURITY CAMERA RACEWAY SYSTEM AND 16049 - ELECTRICAL WORK IN CONNECTION WITH OTHER CONTRACTS FOR ADDITIONAL REQUIREMENTS AND CONTRACTOR RESPONSIBILITIES WITH REGARD TO THESE SYSTEMS.
- THE LOW VOLTAGE SYSTEMS DRAWINGS, OBTAINED BY THE CONTRACTOR FROM THE OWNER'S LOW VOLTAGE SYSTEMS VENDORS, SHALL BE CONSIDERED AN ESSENTIAL COMPONENT OF THE CONTRACT DOCUMENTS. SOME ELECTRICAL WORK SHOWN ON THESE DRAWINGS IS INTENTIONALLY NOT DUPLICATED ON THE ELECTRICAL DRAWINGS. THE CONTRACTOR SHALL PROVIDE, AS PART OF THIS CONTRACT, SOURCES OF POWER; POWER, RECEPTACLES, CONTROL AND COMMUNICATIONS CONDUCTORS, CABLES AND RACEWAYS; EMPTY RACEWAYS; JUNCTION, OUTLET AND PULL BOXES; MOUNTING HARDWARE; FINAL CONNECTIONS; CONNECTION HARDWARE; TESTING AND TESTING SUPPORT; ETC., FOR THE LOW VOLTAGE SYSTEMS AS SHOWN ON THE CONTRACT DRAWINGS AND THE LOW VOLTAGE SYSTEMS DRAWINGS. IF NOT SHOWN ON THE ELECTRICAL DRAWINGS, USE SPARE CIRCUIT BREAKERS IN ELECTRICAL PANELBOARDS FOR ADDITIONAL CIRCUITS SHOWN ON THE REFERENCE DRAWINGS AND MARK AS-BUILT DRAWINGS ACCORDINGLY.
- THE CONTRACTOR IS CAUTIONED TO THOROUGHLY REVIEW BOTH THE CONTRACT DRAWINGS AND THE LOW VOLTAGE SYSTEMS DRAWINGS PRIOR TO SUBMITTING A BID. ELECTRICAL ITEMS SHOWN AND/OR NOTED ON THESE DRAWINGS TO BE PROVIDED BY THE "ELECTRICIAN" OR SIMILAR TERM SHALL BE PROVIDED BY THE CONTRACTOR AND SHALL BE CONSIDERED AS BINDING AS MATERIAL, EQUIPMENT AND LABOR SHOWN ON THE CONTRACT DRAWINGS. NO EXTRAS WILL BE CONSIDERED OR APPROVED FOR ITEMS SHOWN ON EITHER DRAWINGS TO BE PROVIDED BY THE ELECTRICAL CONTRACTOR.

CBHF
Engineers, PLLC

2246 Yaupon Drive
Wilmington, NC 28401
Phone: 910.791.4000
www.cbhfengineers.com

© Copyright 2026 CBHF Engineers, PLLC NC# P-0506

PRELIMINARY
PRICING ONLY
NOT FOR
CONSTRUCTION

NC

WAKE COUNTY

PLANNING & DESIGN

DAVID R. POLSTON - ARCHITECT

3806 PARK AVE. SUITE C, WILMINGTON, NC 28403


ARCHITECTURE PLANNING DESIGN

120 BED
NURSING FACILITY
ELECTRICAL SYSTEM
LEGEND, RISER, & NOTES

SO.1

PRINCIPLE HEALTH CARE
WAKE COUNTY
Holly Springs, North Carolina

NOT FINAL, SUBJECT TO REVISION. NOT FOR PERMITTING, FABRICATION, MATERIAL OR EQUIPMENT PURCHASE, INSTALLATION, OR CONSTRUCTION. PRICING SHALL STATE ALL ASSUMPTIONS, EXCLUSIONS, ALLOWANCES, AND CONTINGENCES AND SHALL BE RECONCILED WITH THE FINAL SIGNED AND SEALED DOCUMENTS.

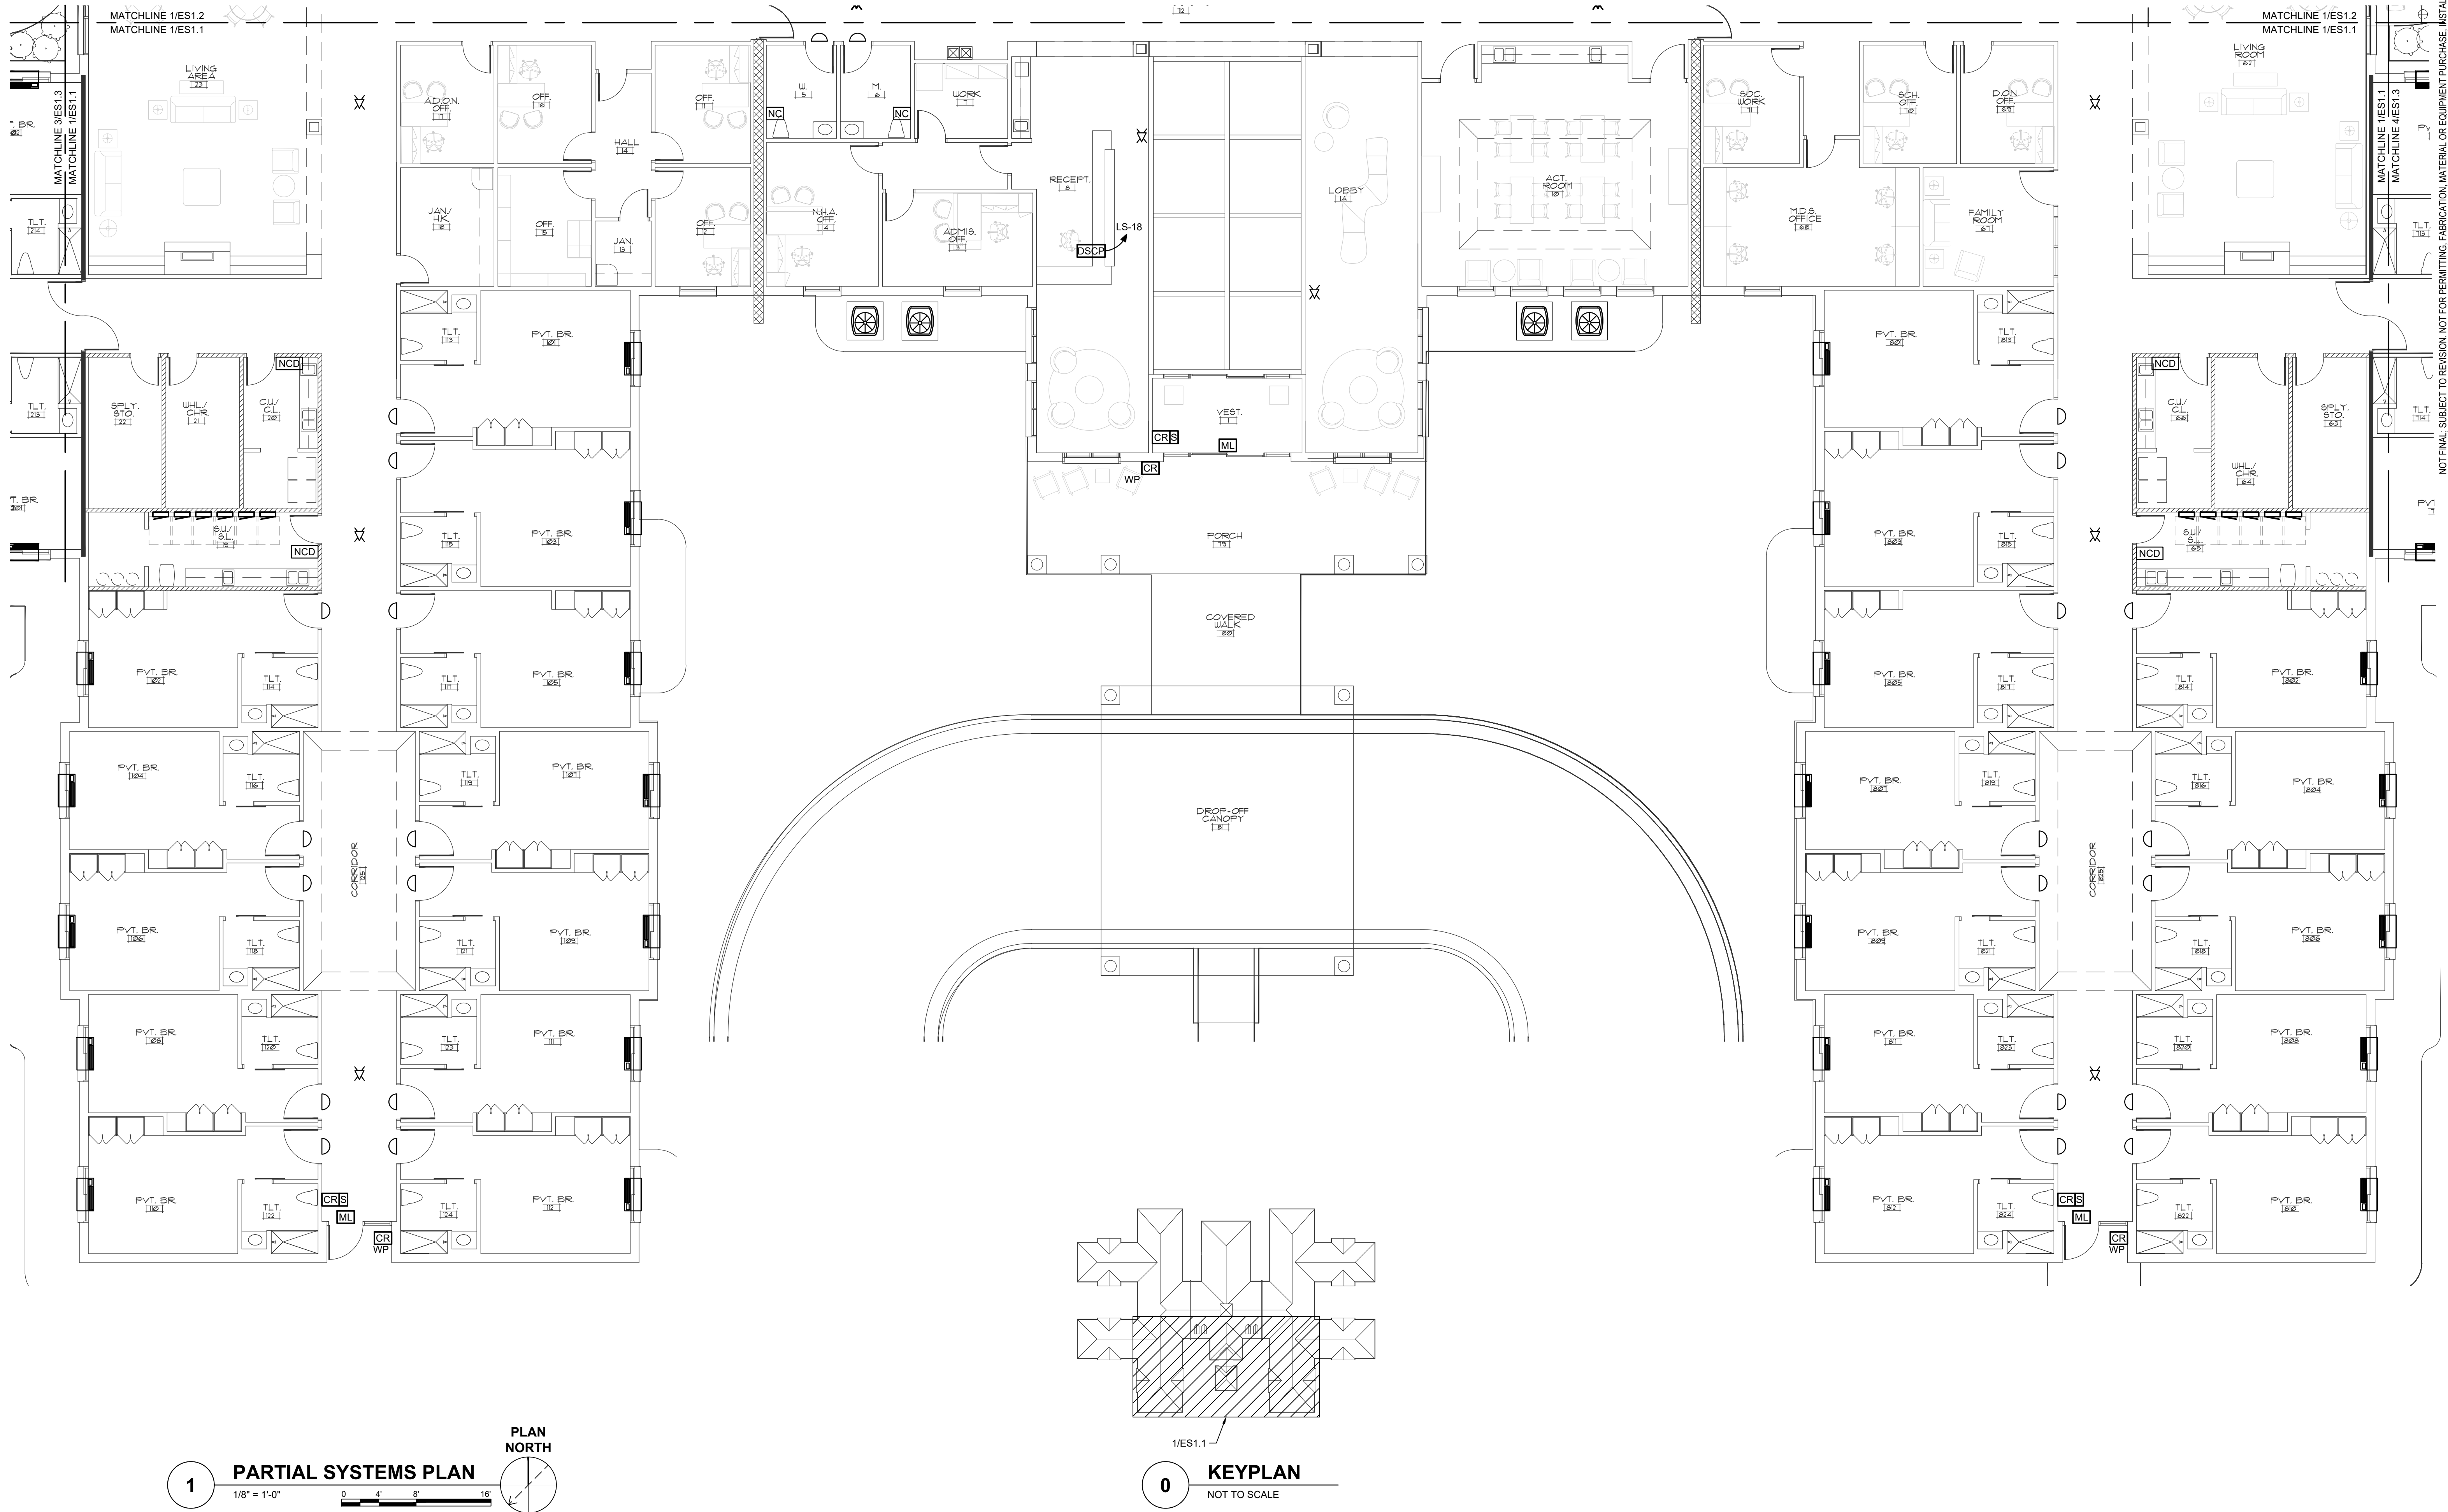

CBHF
Engineers, PLLC
2246 Yaupon Drive
Wilmington, NC 28401
Phone: 910.791.4000
www.cbhfengineers.com
© Copyright 2026 CBHF Engineers, PLLC NCH P-0506

120 BED NURSING FACILITY ELECTRICAL PARTIAL SYSTEMS PLAN





ES 1.1

David R. Polston - Architect
3806 Park Ave. Suite C, Wilmington, NC 28403
Architecture Planning Design

PRINCIPLE HEALTH CARE
WAKE COUNTY
Holly Springs, North Carolina


PRELIMINARY PRICING ONLY NOT FOR CONSTRUCTION

NOT FINAL. SUBJECT TO REVISION. NOT FOR PERMITTING. FABRICATION, MATERIAL OR EQUIPMENT PURCHASE, INSTALLATION, OR CONSTRUCTION. PRICING SHALL STATE ALL ASSUMPTIONS, EXCLUSIONS, ALLOWANCES, AND CONTINGENCIES AND SHALL BE RECONCILED WITH THE FINAL SIGNED AND SEALED DOCUMENTS.

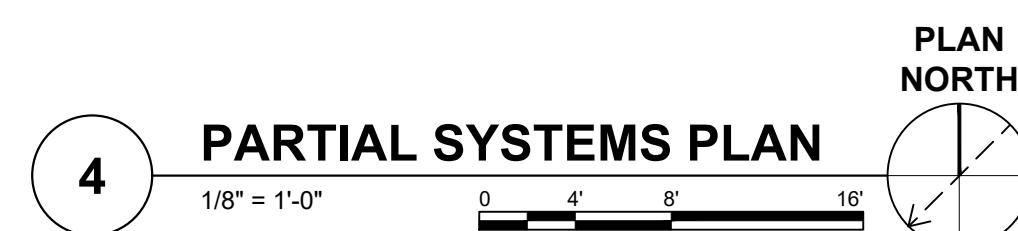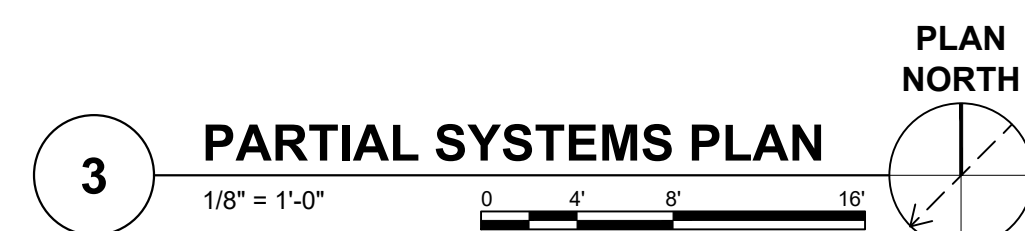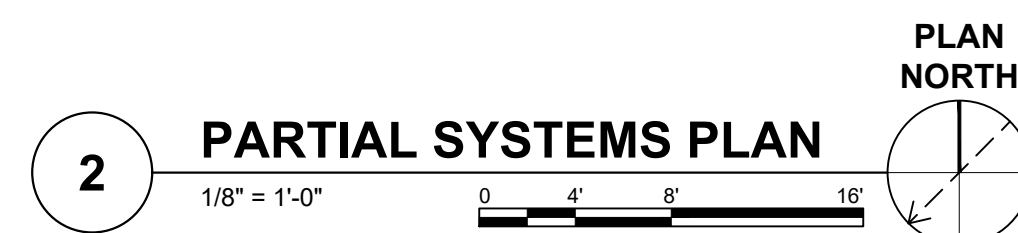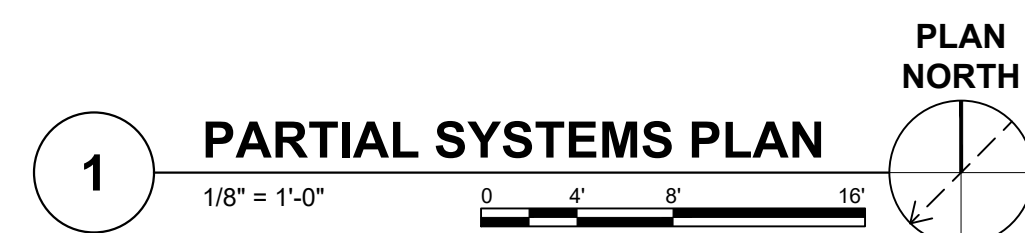

CBHF
Engineers, PLLC
2246 Yaupon Drive
Wilmington, NC 28401
Phone: 910.791.4000
www.cbhfengineers.com
© Copyright 2026 CBHF Engineers, PLLC NC# P-0506

NOT FINAL; SUBJECT TO REVISION. NOT FOR PERMITTING, FABRICATION, MATERIAL, OR EQUIPMENT PURCHASE, INSTALLATION, OR CONSTRUCTION. PRICING SHALL STATE ALL ASSUMPTIONS, EXCLUSIONS, ALLOWANCES, AND CONTINGENCIES AND SHALL BE RECONSIDERED UPON THE FINAL OWNER'S AND/OR ALLIED DOCUMENTS.

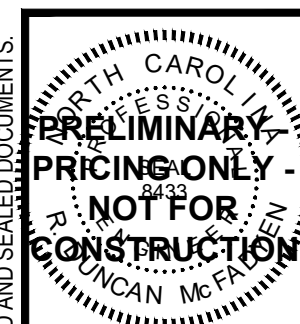


PRINCIPLE HEALTH CARE
WAKE COUNTY
Holly Springs, North Carolina


David R. Polston - Architect
3806 Park Ave. Suite C, Wilmington, NC 28403
Architecture Planning Design

120 BED
NURSING FACILITY
ELECTRICAL
PARTIAL SYSTEMS PLAN


ES 1.3

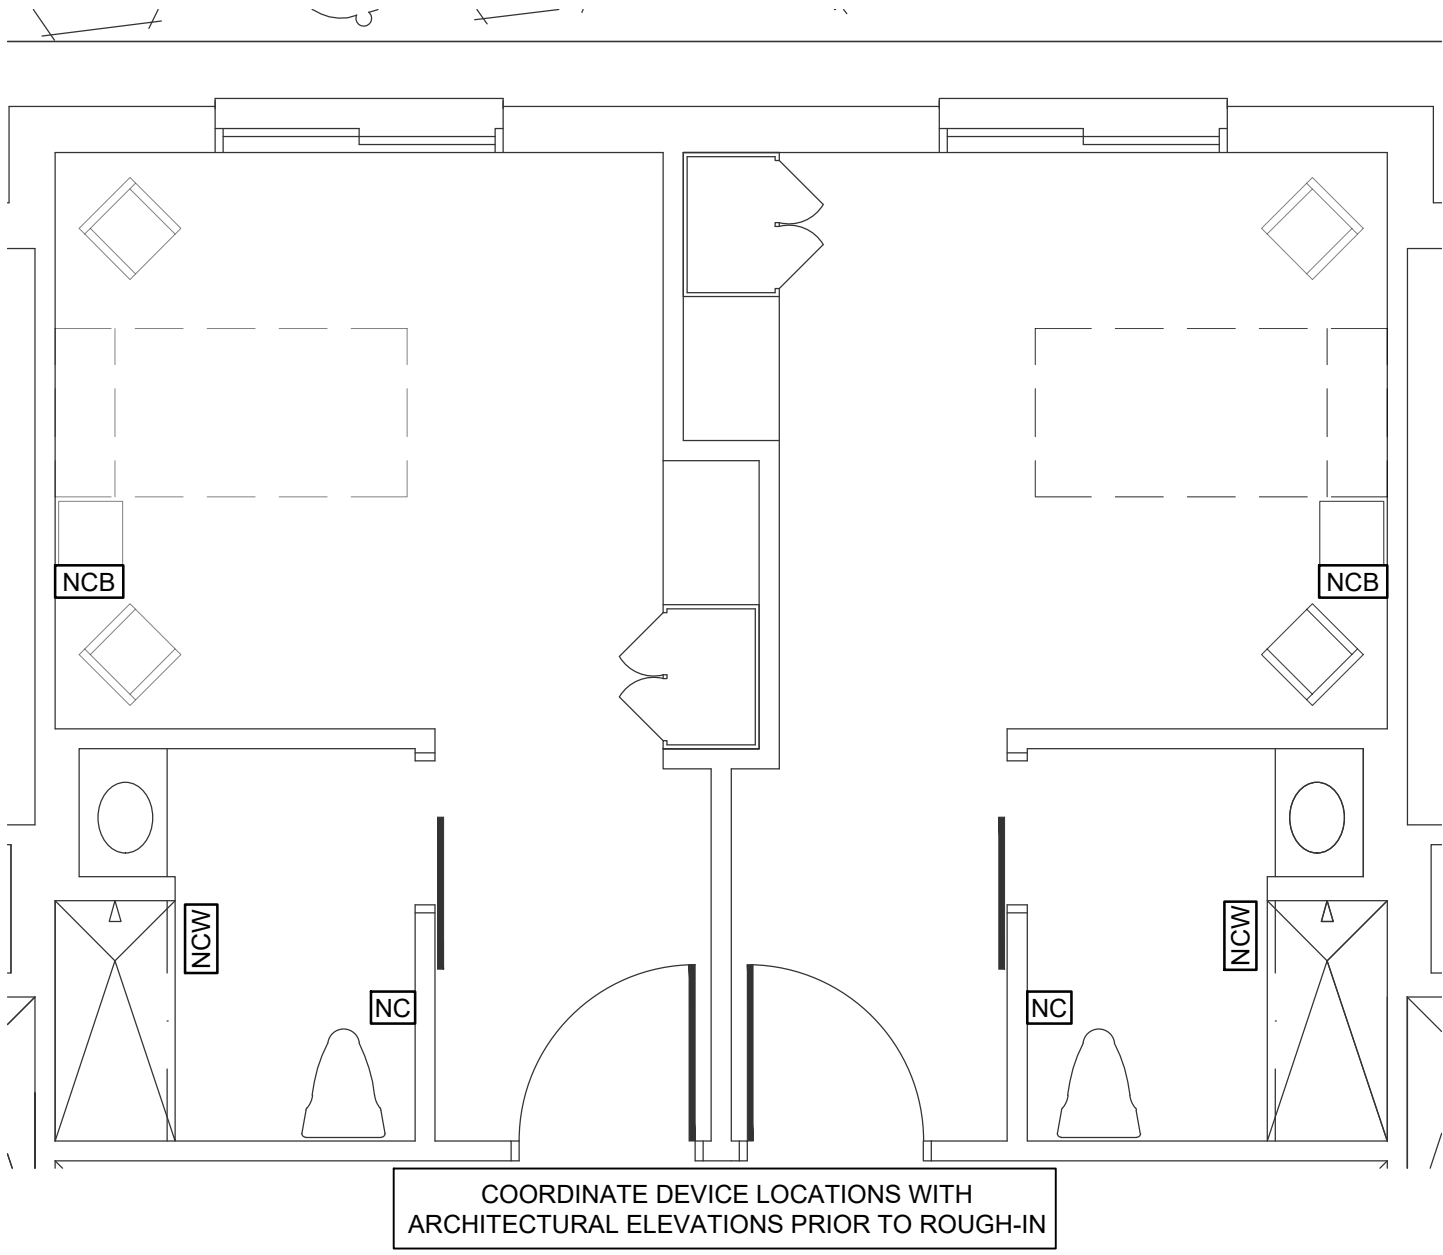


1
TYPICAL ENLARGED PLAN -
PRIVATE BEDROOM SUITE
1/4" = 1'-0"

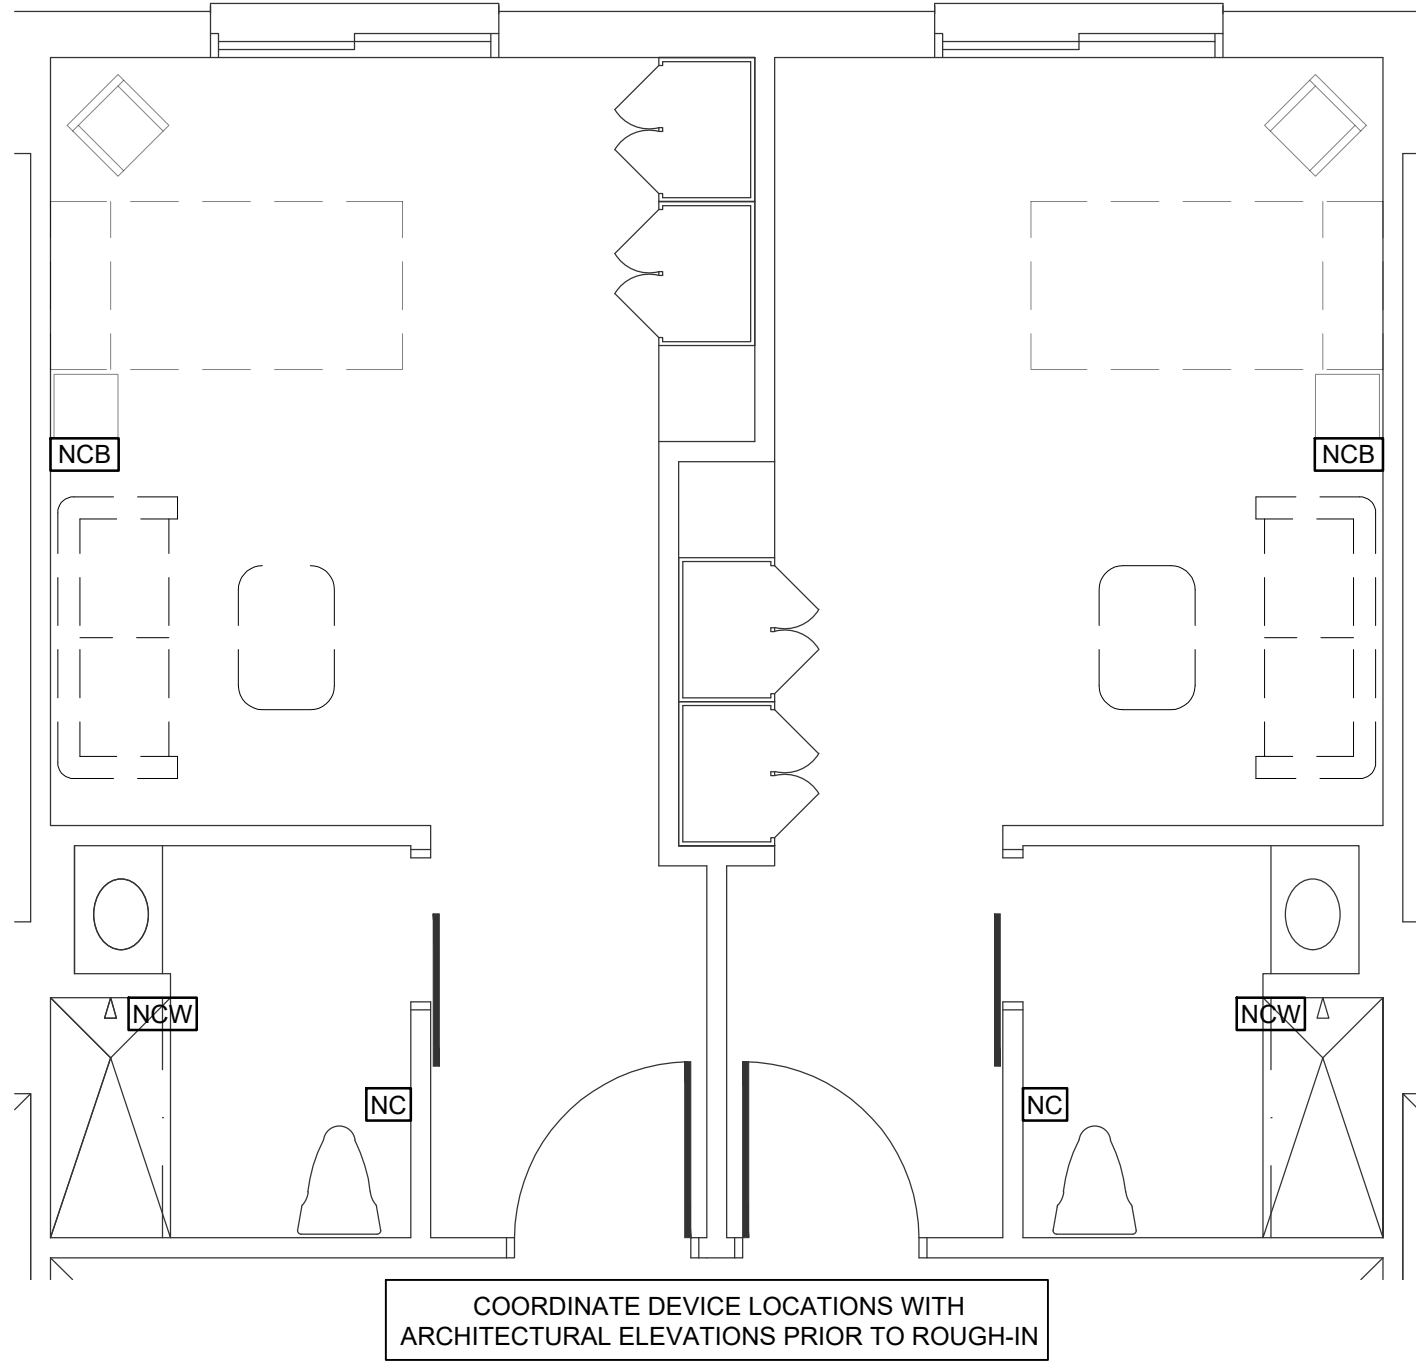


2
TYPICAL ENLARGED PLAN -
LARGE PRIVATE BEDROOM SUITE
1/4" = 1'-0"

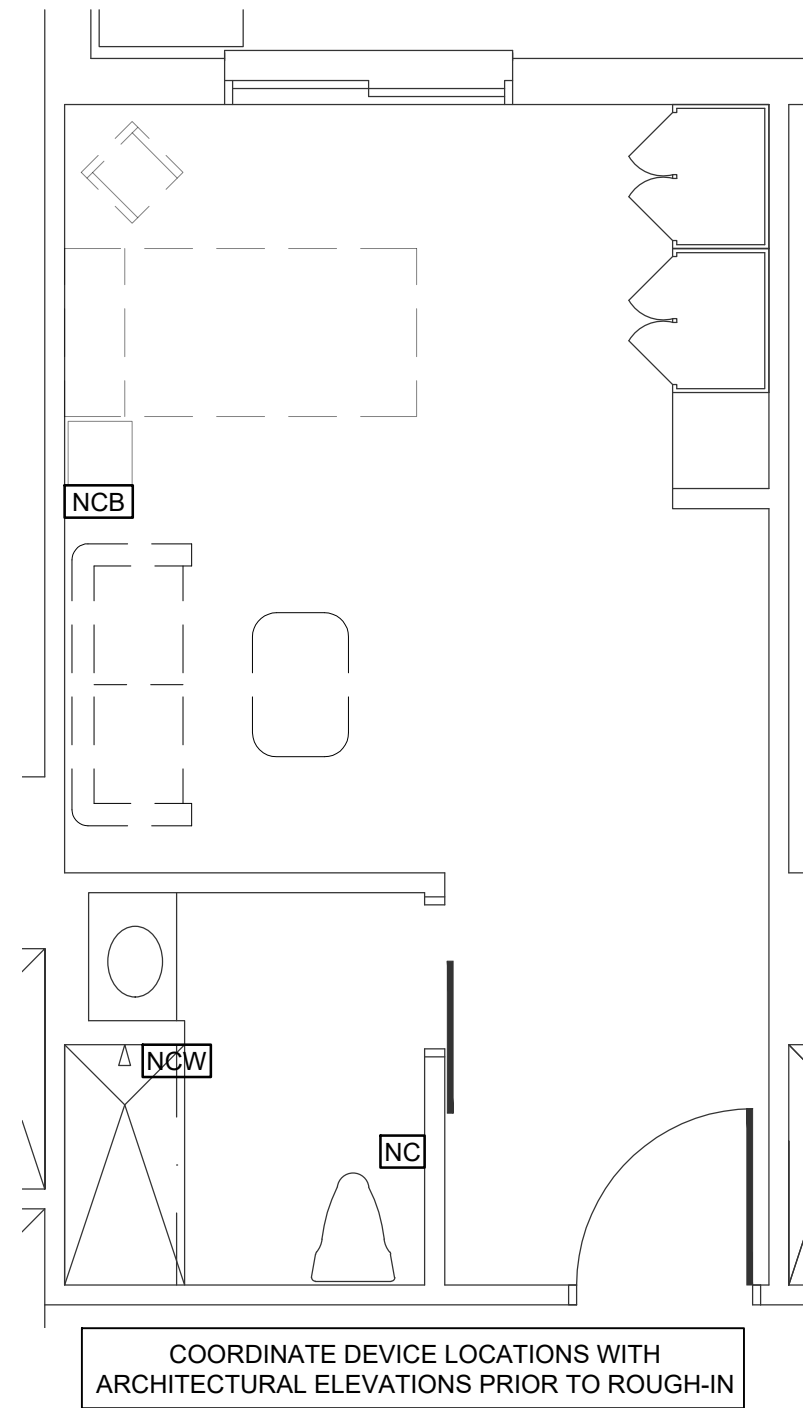

3
TYPICAL ENLARGED PLAN -
LARGE PRIVATE BEDROOM "HALF" SUITE
1/4" = 1'-0"

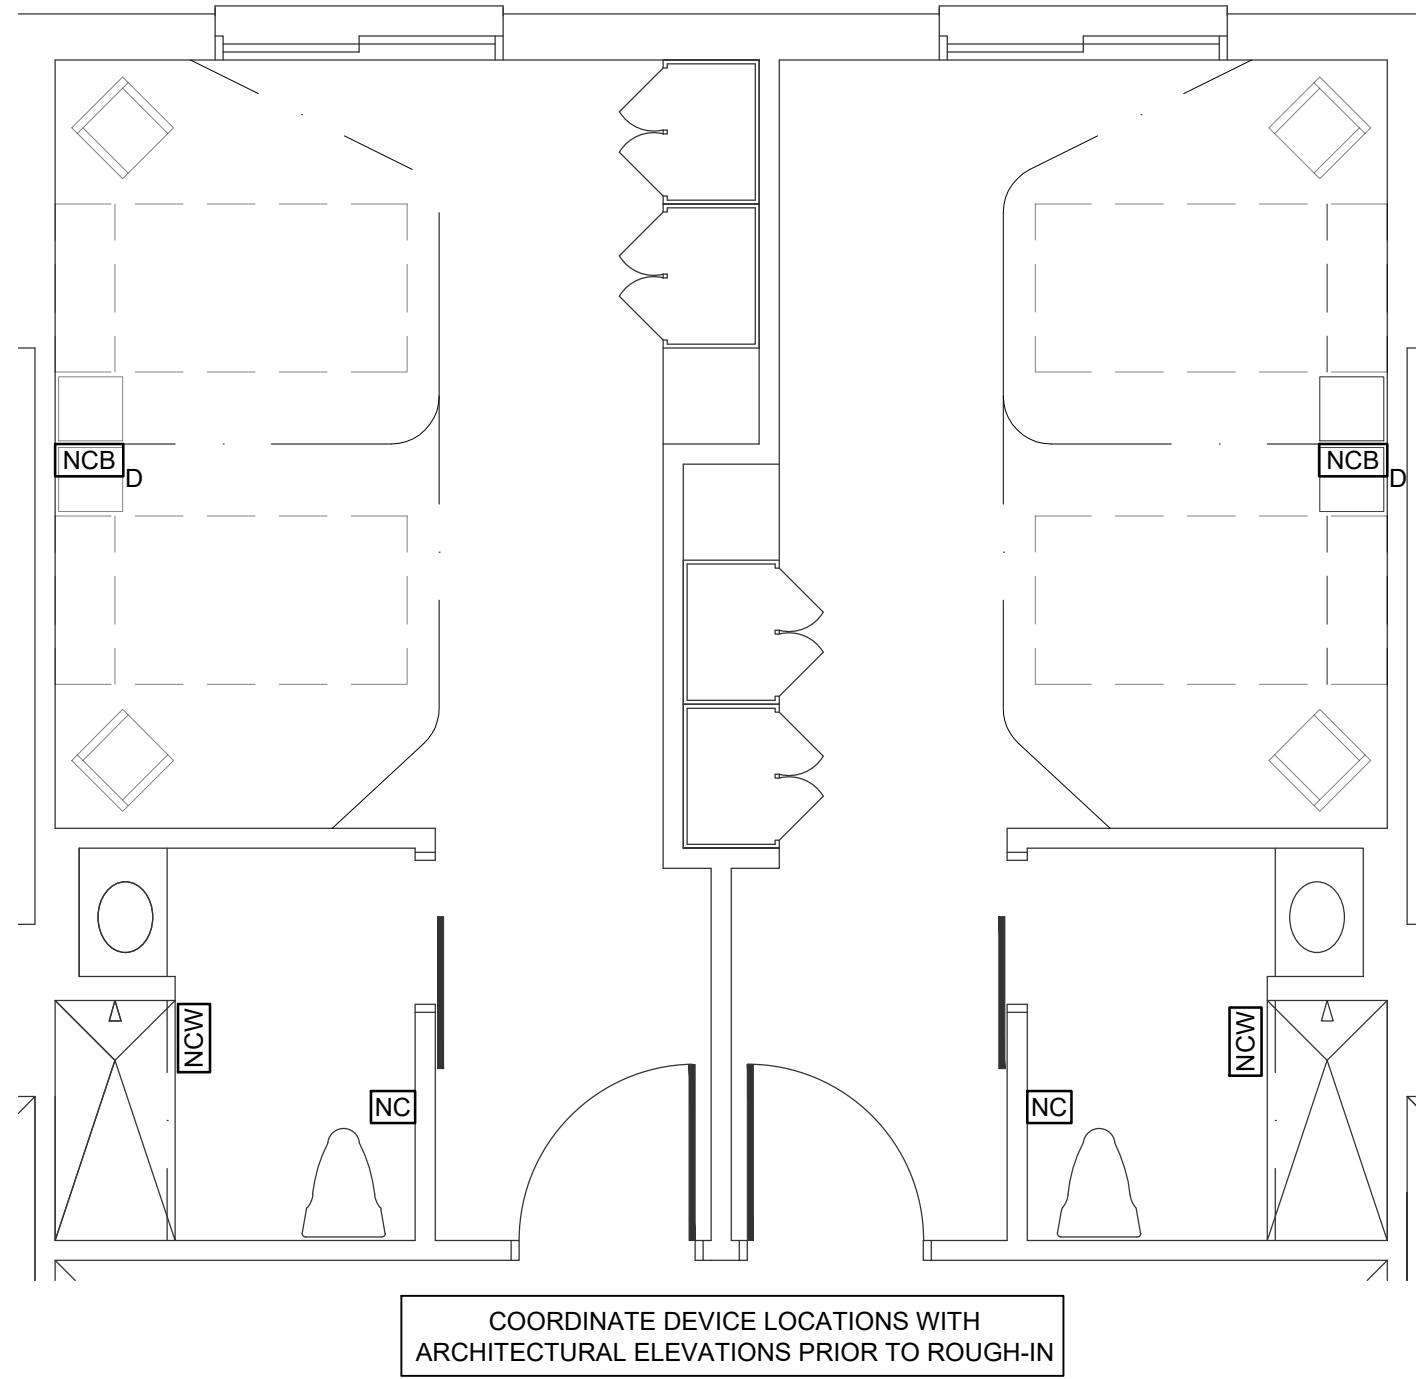

4
TYPICAL ENLARGED PLAN -
SEMI-PRIVATE BEDROOM SUITE
1/4" = 1'-0"

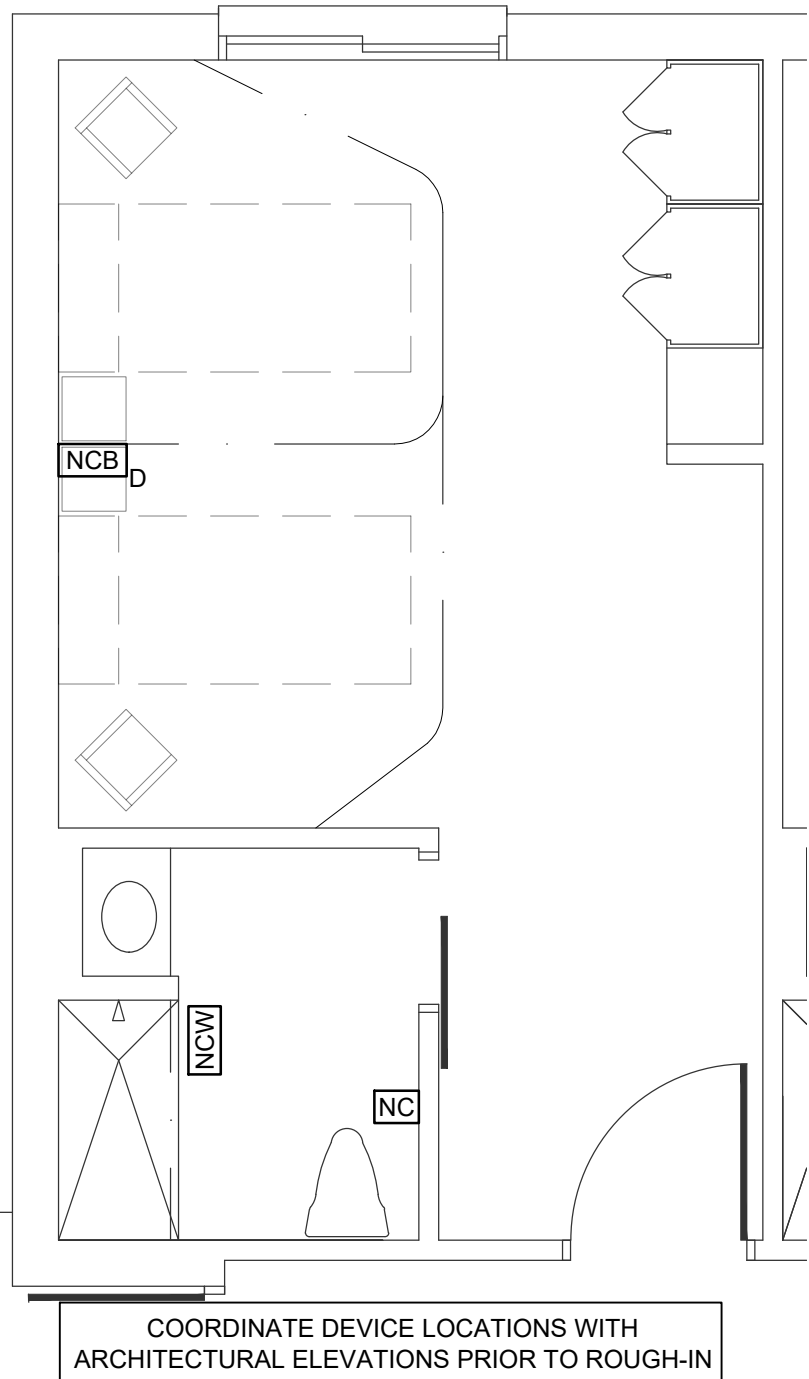

5
TYPICAL ENLARGED PLAN -
SEMI-PRIVATE BEDROOM "HALF" SUITE
1/4" = 1'-0"

WALL TYPE LEGEND	
	1 HOUR FIRE BARRIER WALL
	1 HOUR FIRE/SMOKE BARRIER WALL
	2 HOUR FIRE BARRIER WALL
	SMOKE RESISTANT WALL

CBHF
Engineers, PLLC

2246 Yaupon Drive
Wilmington, NC 28401
Phone: 910.791.4000
www.cbhfengineers.com

© Copyright 2026 CBHF Engineers, PLLC NC# P-0506

NOT FINAL, SUBJECT TO REVISION. NOT FOR PERMITTING, FABRICATION, MATERIAL OR EQUIPMENT PURCHASE, INSTALLATION, OR CONSTRUCTION. PRICING SHALL STATE ALL ASSUMPTIONS, EXCLUSIONS, ALLOWANCES, AND CONTINGENCIES AND SHALL BE RECONCILED WITH THE FINAL SIGNED AND SEALED DOCUMENTS.

PRELIMINARY

PRICING ONLY

NOT FOR CONSTRUCTION

SEAL

DAVID R. POLSTON

ARCHITECT

NC# 28403

DAVID R. POLSTON

ARCHITECT

NC# 28403

PRINCIPLE HEALTH CARE

WAKE COUNTY

Holly Springs, North Carolina

120 BED

NURSING FACILITY

NURSE CALL SYSTEM

BEDROOM PLANS

ES

4.0

FIRE ALARM SYSTEM CONTROL MATRIX

SYSTEM INPUTS	SYSTEM OUTPUTS							
	ACTUATE COMMON ALARM SIGNAL INDICATOR	ACTUATE NOTIFICATION APPLIANCES	ACTUATE COMMON TROUBLE SIGNAL INDICATOR	ACTUATE COMMON SUPERVISORY SIGNAL INDICATOR	ALARM SIGNAL TO MONITORING SERVICE	SUPERVISORY SIGNAL TO MONITORING SERVICE	TROUBLE SIGNAL TO MONITORING SERVICE	RELEASE MAGNETICALLY HELD DOORS
SMOKE DETECTORS	X	X			X		X	X
HEAT DETECTORS	X	X			X		X	X
MANUAL PULL STATIONS	X	X			X		X	
CARBON MONOXIDE DETECTORS			X		X			
SYSTEM TROUBLE CONDITION			X			X	X	
LOSS OF FACU AC POWER (NOTE 1)				X			X	
GROUND FAULT				X		X	X	
SHORT CIRCUIT				X		X	X	
OPEN CIRCUIT			X			X	X	
EXHAUST HOOD FIRE SUPPRESSION SYSTEM	X	X				X	X	X
SPRINKLER RISER #1 (SPRINKLER RISER 45) SYSTEM FLOW SWITCH (ES)	X	X		X			X	X
SPRINKLER RISER #1 (SPRINKLER RISER 45) SYSTEM TAMPER SWITCH (ES)				X		X	X	
SPRINKLER RISER #1 (SPRINKLER RISER 45) PRESSURE SWITCH (ES)				X		X	X	
SPRINKLER RISER #1 (SPRINKLER RISER 45) PIV SUPERVISORY				X		X	X	
SPRINKLER RISER #1 RPZ TAMPER SWITCH (ES)				X		X	X	

NOTES:
1. ONLY AFTER LOSS OF POWER FOR > 8 HOURS.
2. ALL SPRINKLER FIRE ALARM SYSTEM CONNECTIONS ARE NOT SHOWN. REFER TO FIRE PROTECTION DRAWINGS FOR SPRINKLER DEVICE LOCATIONS.

FIRE ALARM LEGEND

SYMBOL	DESCRIPTION
	FIRE ALARM MANUAL STATION, 48" AFF
	FIRE ALARM HORN/STROBE DEVICE, 80" AFF, "15cd" INDICATED CANDELA RATING
	FIRE ALARM VISUAL (ONLY) DEVICE, 80" AFF, "15 cd" INDICATES CANDELA RATING
	FIRE ALARM HORN/STROBE DEVICE, CEILING MOUNTED, "15cd" INDICATES CANDELA RATING
	FIRE ALARM VISUAL (ONLY) CEILING MOUNTED, "15cd" INDICATES CANDELA RATING
	FIRE ALARM CHIME/STROBE DEVICE, CEILING MOUNTED, "15cd" INDICATES CANDELA RATING
	DOOR HOLD OPEN DEVICE BY G.C.
	SMOKE DETECTOR, CEILING MOUNTED
	HEAT DETECTOR, CEILING MOUNTED
	CARBON MONOXIDE DETECTOR, CEILING MOUNTED
	EXTERIOR ELECTRIC WATER BELL , WP, ANNUNCIATED WATER FLOW
	SPRINKLER TAMPER SWITCH
	SPRINKLER FLOW SWITCH
	CONTROL MODULE
	MONITOR MODULE
	DUCT SMOKE DETECTOR, REMOTE INDICATING DEVICE (RAIL)
	REMOTE INDICATING DEVICE (RAIL), WALL MOUNTED
	ISOLATION MODULE
	FIRE ALARM CONTROL UNIT (FACP)
	FIRE ALARM REMOTE ANNUNCIATOR PANEL

(SYMBOLS SHOWN FOR REFERENCE ONLY AND MAY NOT IMPLY CONTRACTUAL REQUIREMENTS)

WALL TYPE LEGEND

	1 HOUR FIRE BARRIER WALL
	1 HOUR FIRE/SMOKE BARRIER WALL
	2 HOUR FIRE BARRIER WALL
	SMOKE RESISTANT WALL

CBHF
Engineers, PLLC

2246 Yaupon Drive
Wilmington, NC 28401
Phone: 910.791.4000
www.cbhfengineers.com

© Copyright 2026 CBHF Engineers, PLLC NCH P-0506




PRINCIPLE HEALTH CARE
WAKE COUNTY
Holly Springs, North Carolina

David R. Polston - Architect
3806 Park Ave. Suite C, Wilmington, NC 28403
Architecture Planning Design


120 BED
NURSING FACILITY
FIRE ALARM SYSTEM
NOTES AND DETAILS

FA
0.1


NOT FINAL. SUBJECT TO REVISION. NOT FOR PERMITTING. FABRICATION, MATERIAL OR EQUIPMENT PURCHASE, INSTALLATION, OR CONSTRUCTION. PRICING SHALL STATE ALL ASSUMPTIONS, EXCLUSIONS, ALLOWANCES, AND CONTINGENCIES AND SHALL BE RECONCILED WITH THE FINAL SIGNED AND SEALED DOCUMENTS.

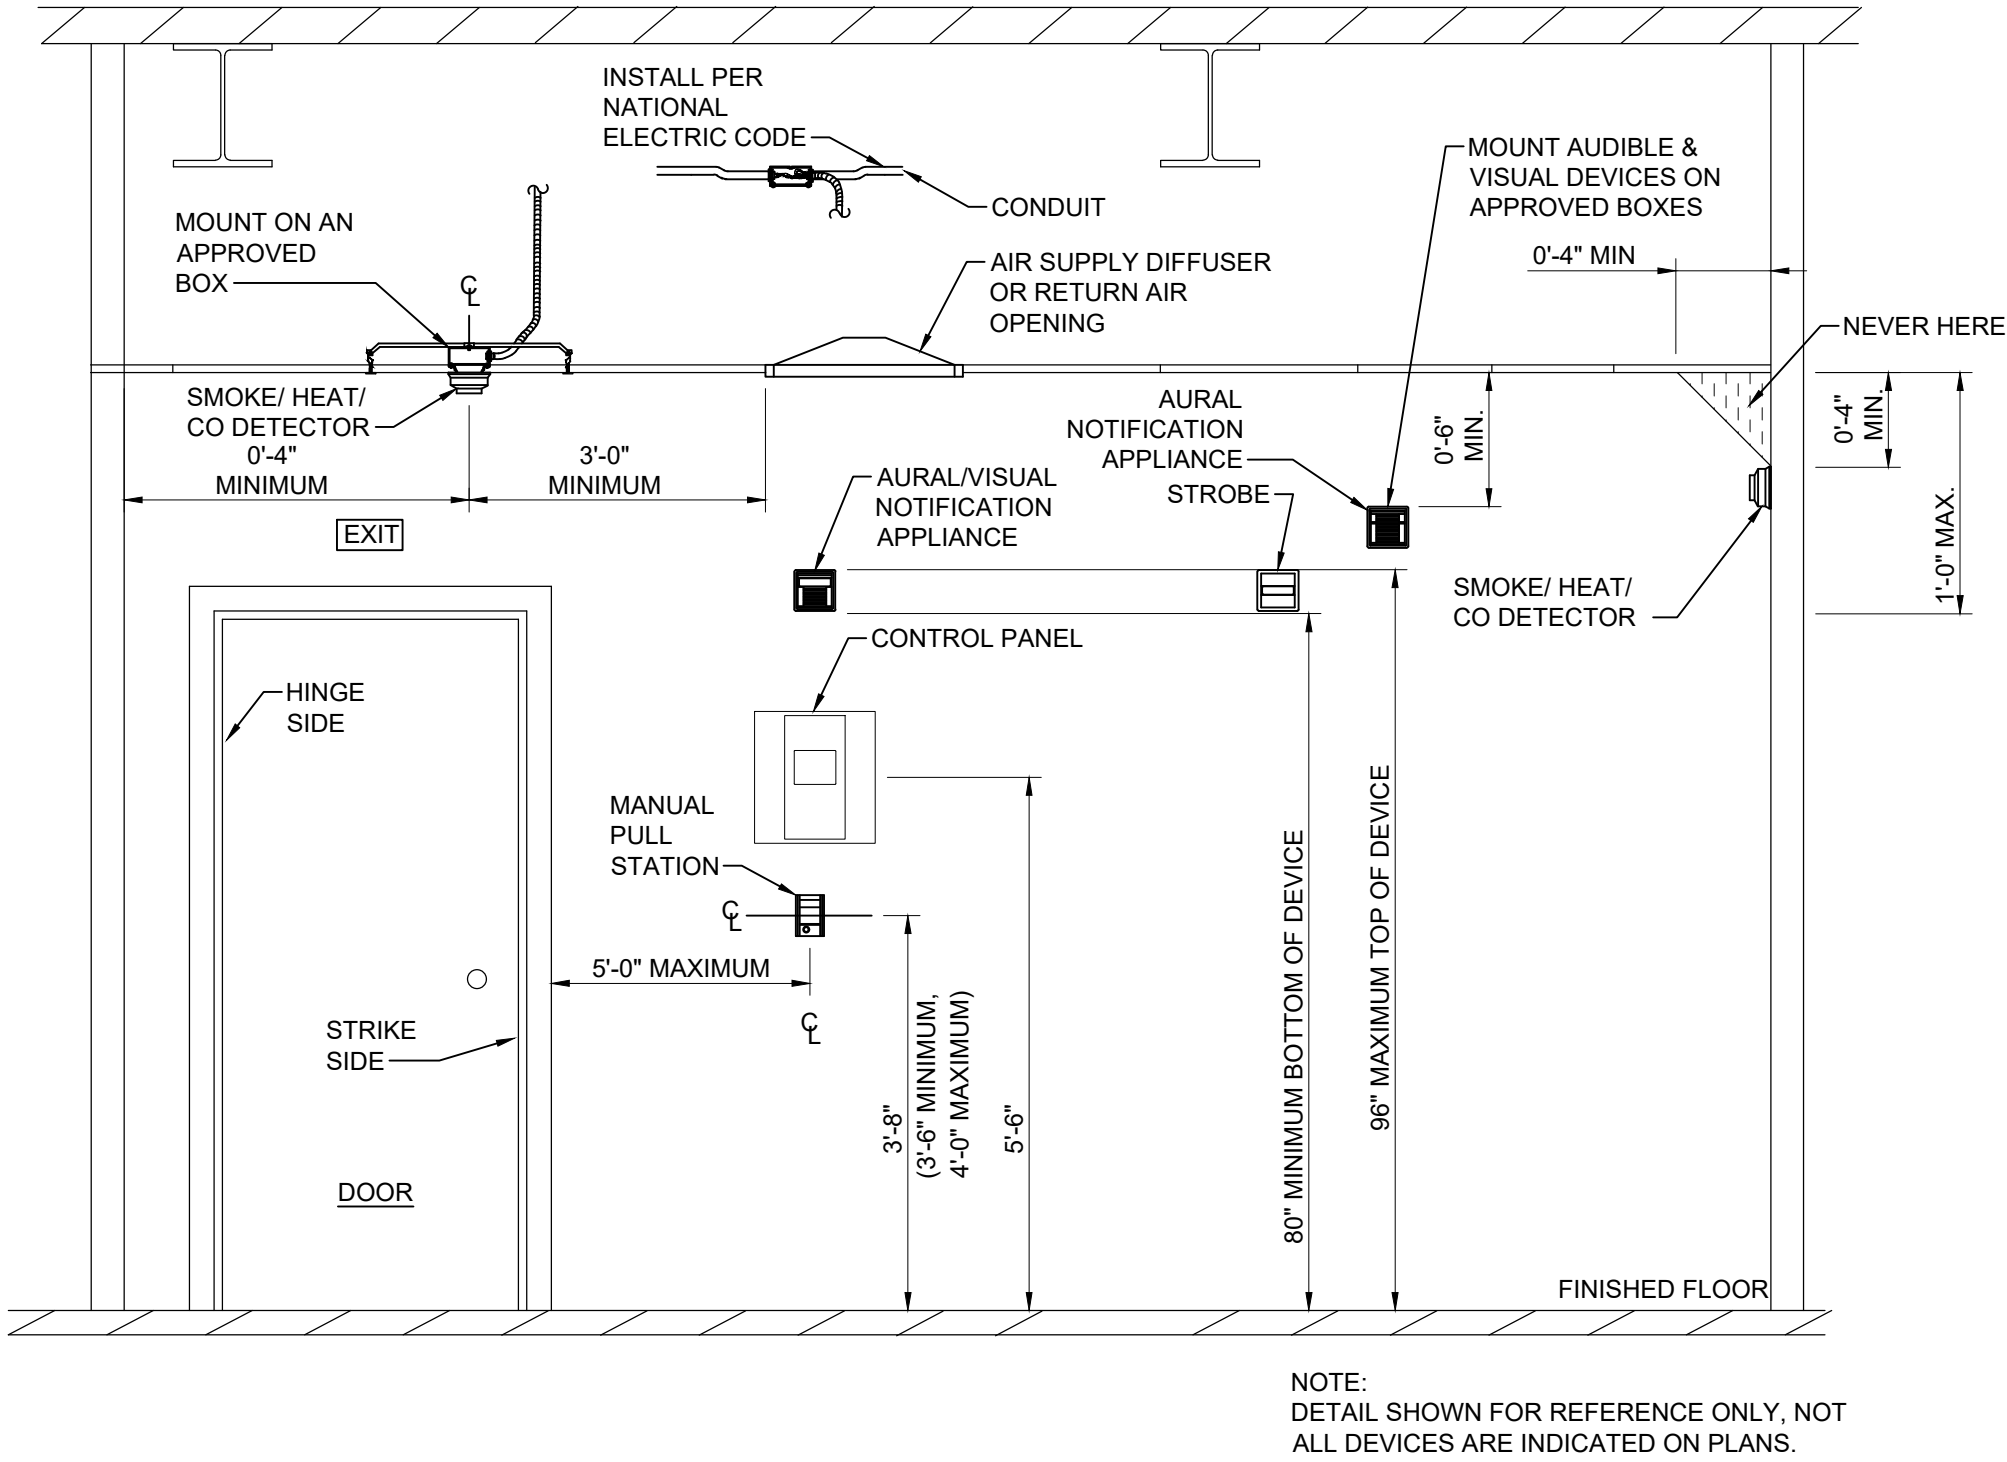

2 DEVICE MOUNTING DETAIL
NOT TO SCALE

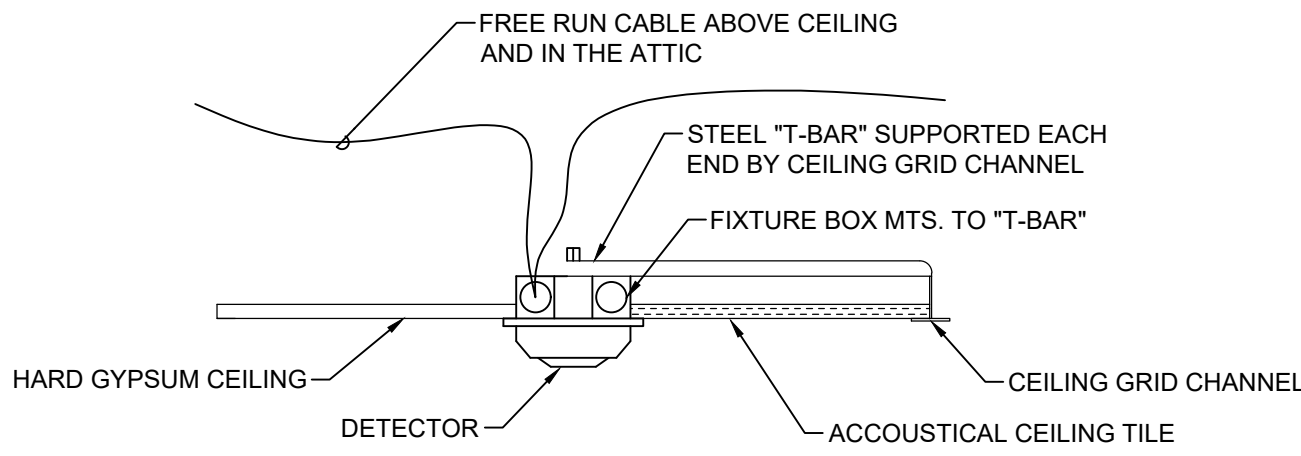


3 TYPICAL CEILING MOUNTED DEVICE DETAIL
NOT TO SCALE

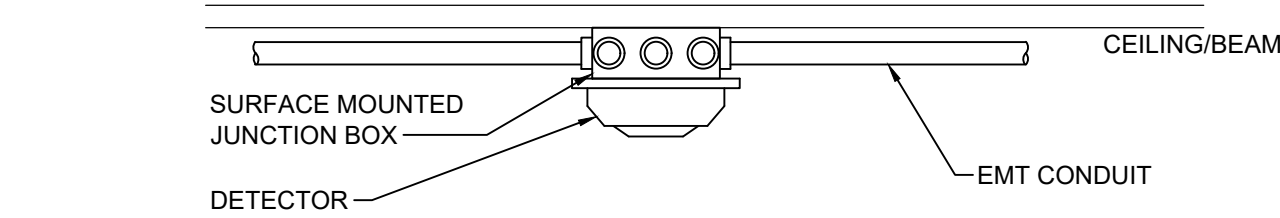

4 TYPICAL SURFACE MOUNTED DEVICE DETAIL
NOT TO SCALE


ATTIC LOW VOLTAGE SYSTEMS CABLE INSTALLATION NOTES:

- ALL LOW VOLTAGE SYSTEM CABLE INSTALLED FREE RUN IN THE ATTIC SHALL BE INSTALLED ON J HOOKS. CABLES SHALL BE INSTALLED IN A MANNER TO PROTECT THE CABLES FROM DAMAGE DURING INSTALLATION, FACILITATE CABLE MANAGEMENT AND IDENTIFICATION, AND PROVIDE A NEAT AND GROOMED APPEARANCE.
- EACH CABLE SYSTEM SHALL BE INSTALLED AND SUPPORTED INDEPENDENTLY.
- CABLING SHALL BE INSTALLED IN STRAIGHT PATHS IN A NEAT AND ORDERLY FASHION FOLLOWING MAINTENANCE WALKWAYS AND AT NINETY-DEGREE ANGLES. DIAGONAL, BEELINE AND OR NON-SUPPORTED CABLING ARE UNACCEPTABLE. CABLING SHALL BE ROUTED AS HIGH AS POSSIBLE AND ABOVE OTHER BUILDING FACILITIES IN THE PATH WITH THE LEAST OBSTRUCTIONS IN THE SPACE. PATHWAYS SHALL BE AT LEAST 2 FEET AWAY FROM ALL LIGHTING FIXTURES AND OTHER POTENTIAL EMF SOURCES. CABLES SHALL NOT BE STRAPPED TO ELECTRICAL POWER CONDUITS, PIPING OR OTHER SYSTEMS. THE PLACING OF CABLE TIES SHALL NOT DEFORM THE CABLES.
- THE CABLE SUPPORT STRUCTURE SHALL UTILIZE APPROVED J HOOK CABLE SUPPORTS AND BE SIZED TO ACCOMMODATE CHANGE. J HOOK TYPE CABLE SUPPORTS SHALL BE SECURELY FASTENED TO THE BUILDING STRUCTURE AND BE SPACED AT A MAXIMUM DISTANCE OF FOUR (4) FEET SO THAT SAG BETWEEN SUPPORTS DOES NOT EXCEED 12 INCHES. ALL J HOOKS SHALL BE SIZED WITH 20% SPARE CAPACITY. ALL ATTACHMENT HARDWARE SHALL BE APPROVED FOR THE TYPE OF INSTALLATION AND MAXIMUM LOAD RATING OF THE PRODUCTS INSTALLED.
- ALL PENETRATIONS THROUGH WALLS AND CEILINGS SHALL BE SLEEVED. ALL SLEEVES SHALL HAVE PERMANENTLY ATTACHED PLASTIC BUSHINGS. SLEEVES SHALL BE SIZED TO ACCEPT 50% GROWTH. ALL SLEEVES SHALL BE FIRE-STOPPED USING THIRD PARTY TESTING AGENCY APPROVED METHODS AND SHALL MAINTAIN ASSEMBLY FIRE RATINGS.

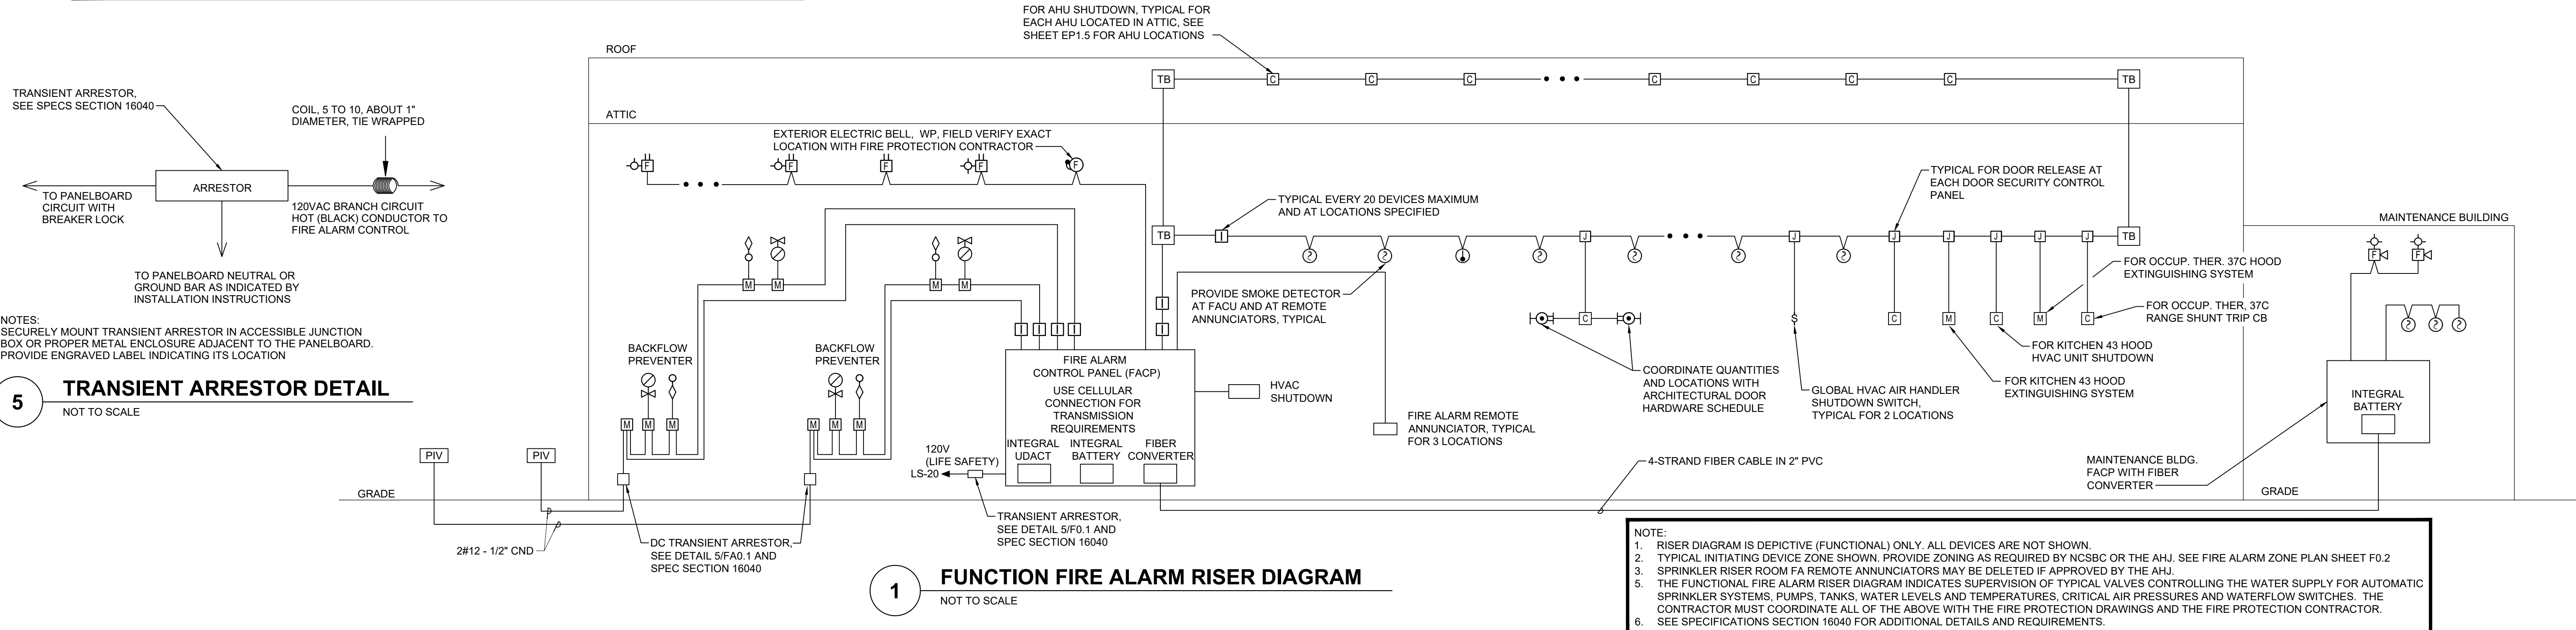

1 FUNCTION FIRE ALARM RISER DIAGRAM
NOT TO SCALE

5 TRANSIENT ARRESTOR DETAIL
NOT TO SCALE

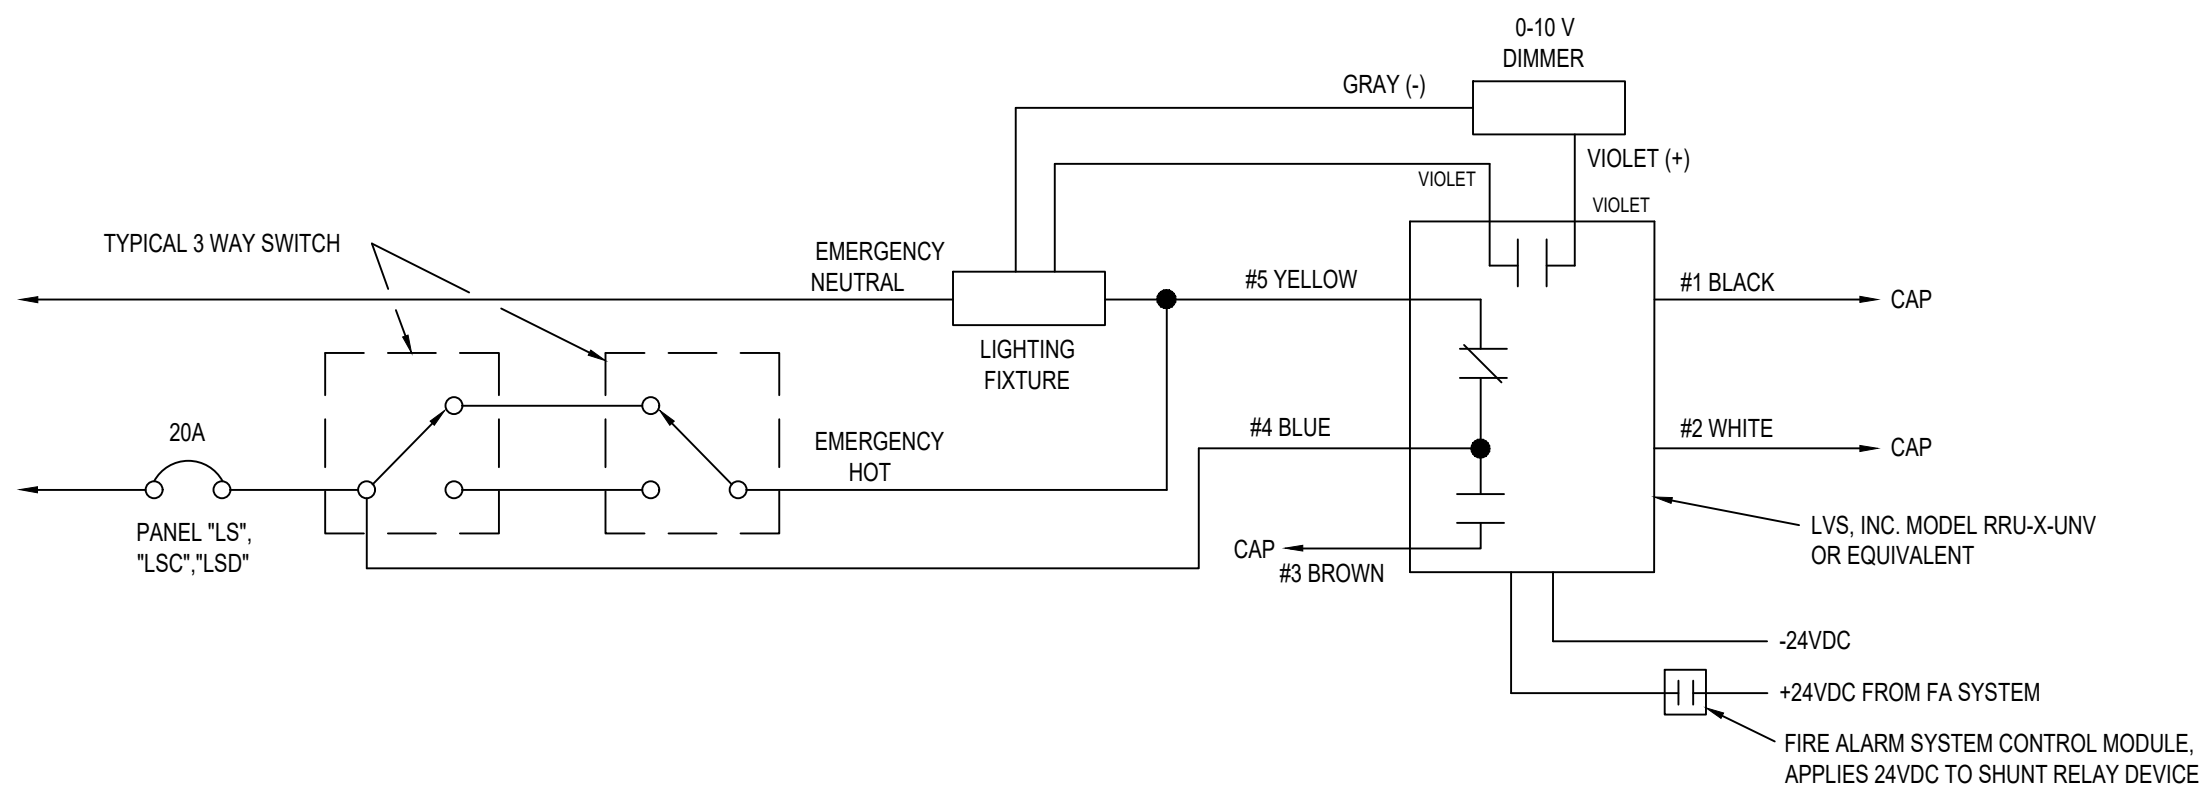


2 LIFE SAFETY LIGHTING SHUNT RELAY DETAIL (TYP)
NOT TO SCALE

NOTE: 3 WAY SWITCHING SHOWN

RED LAMICORE
PLACARD WITH 3/4"
WHITE ENGRAVED
LETTERS



3 FACP PLACARD DETAIL
NOT TO SCALE

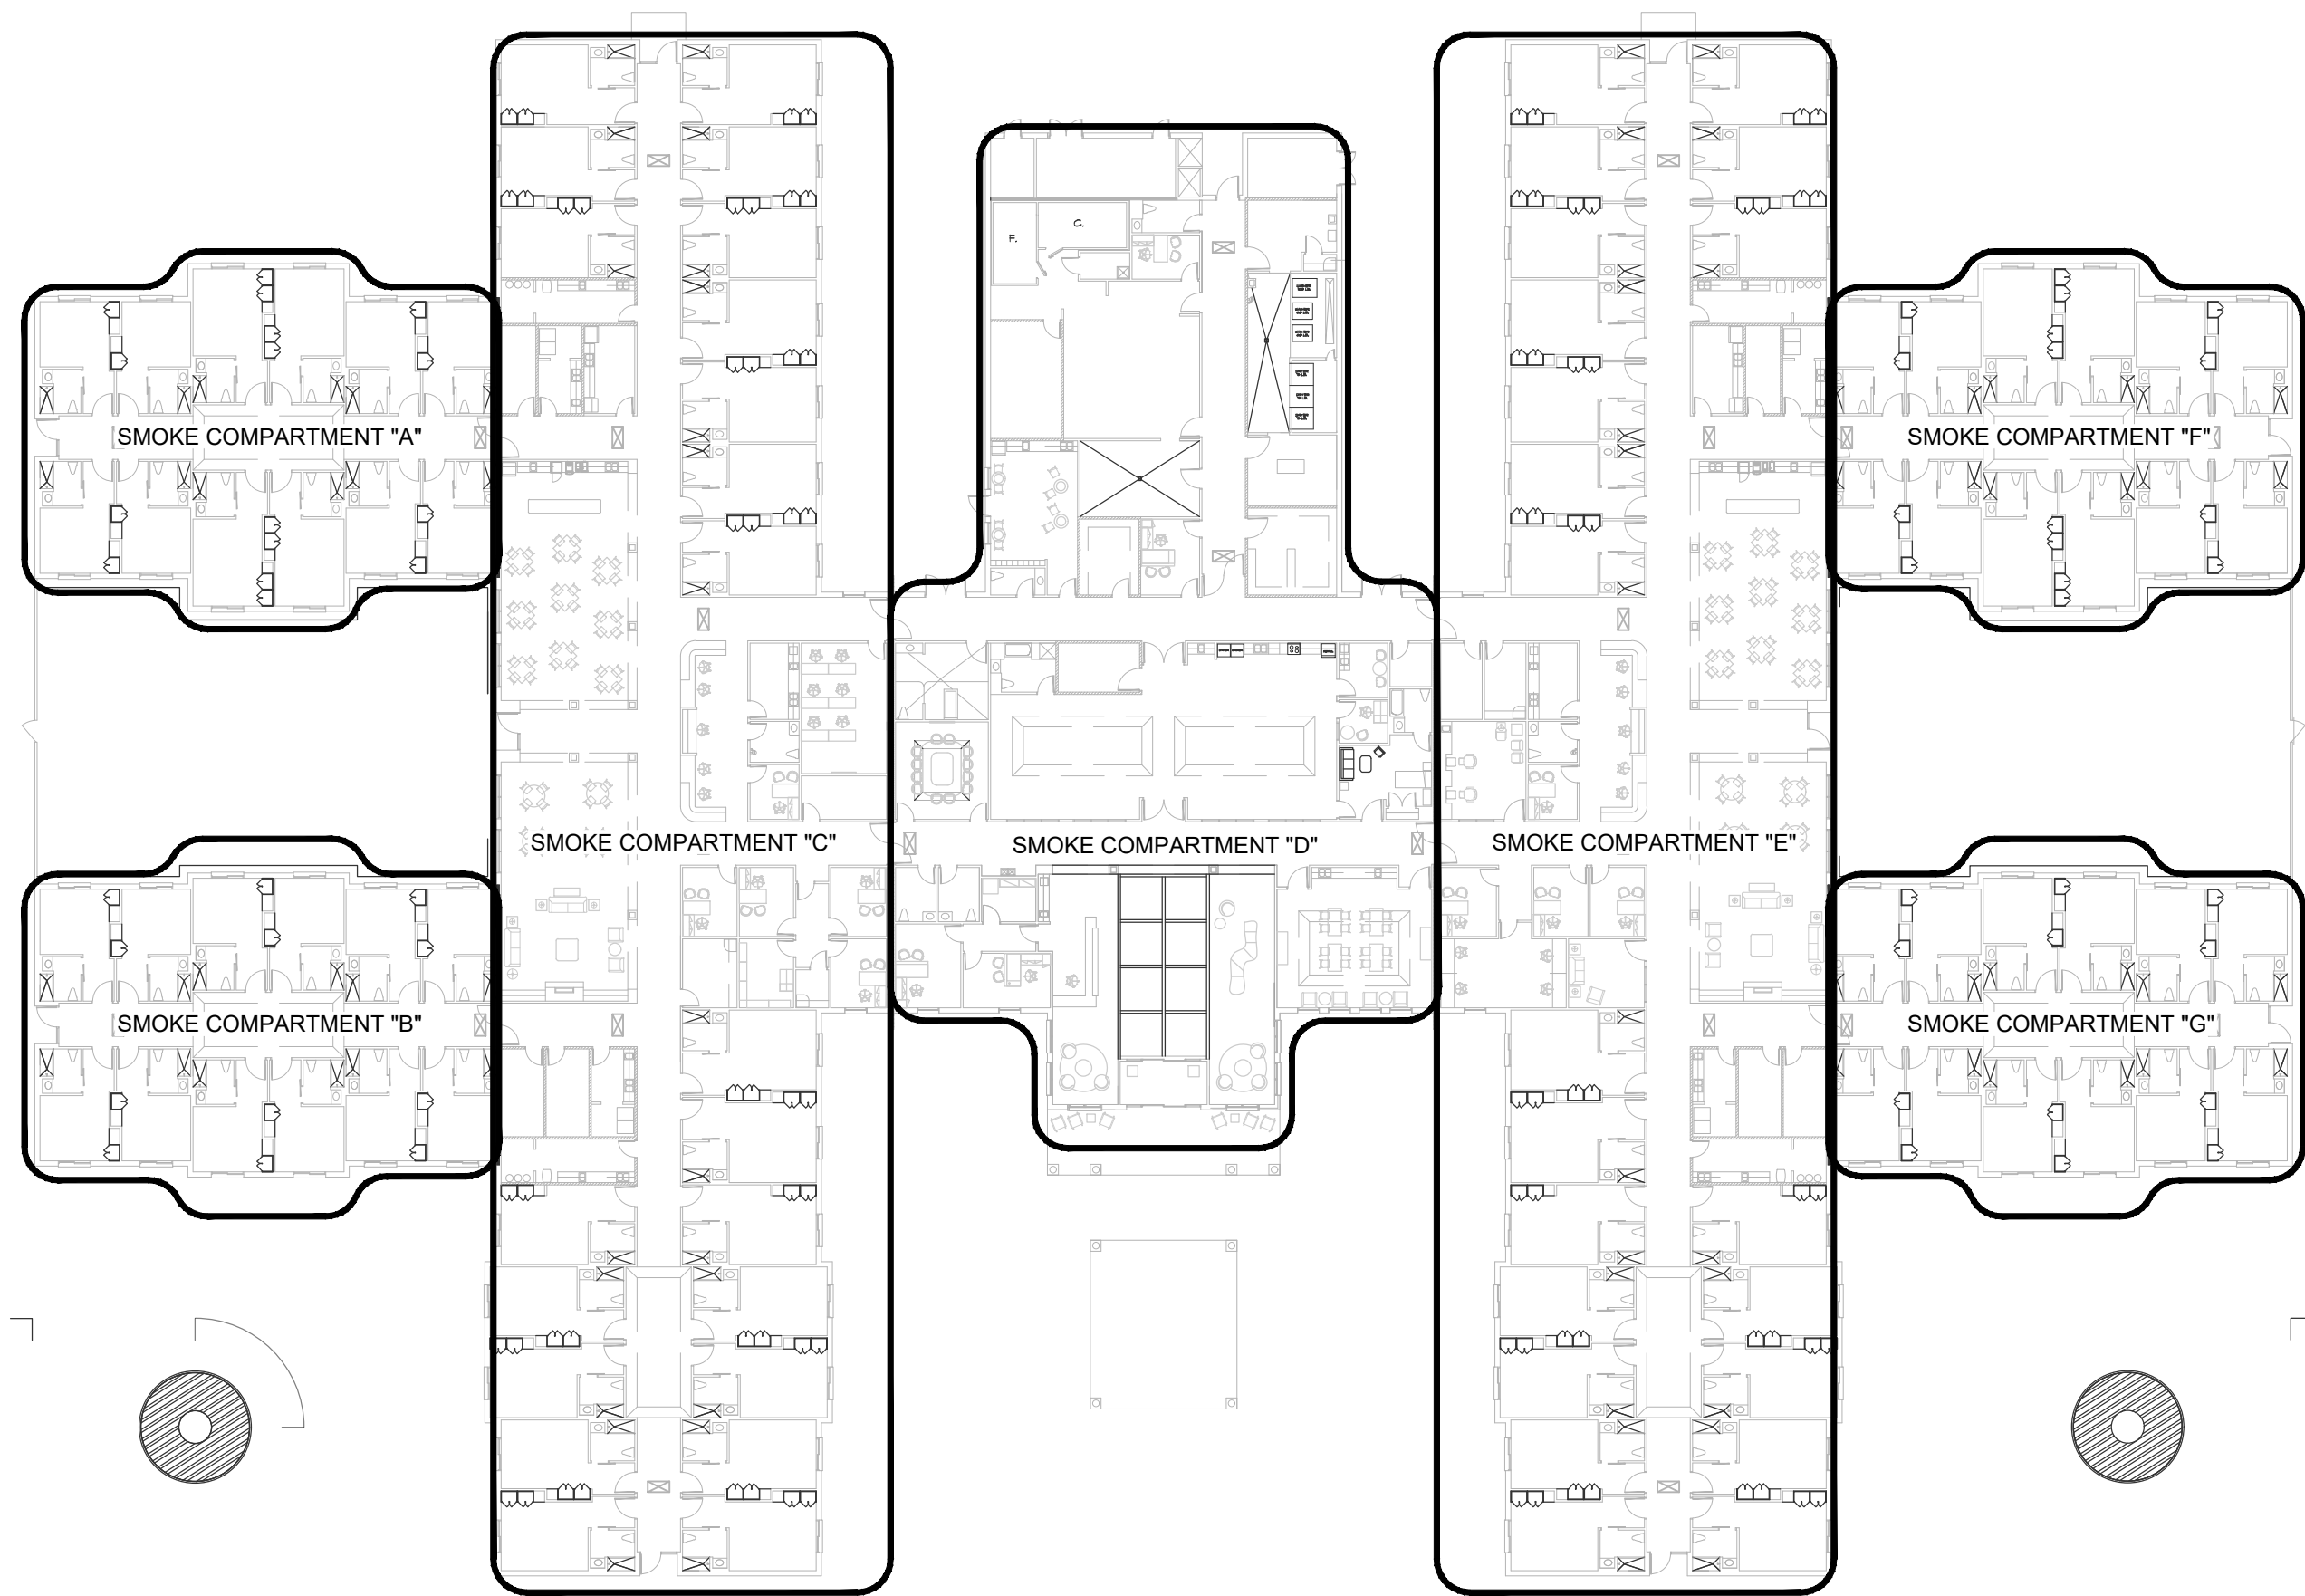

1 FIRE ALARM ZONE PLAN
NOT TO SCALE

NOTE:
SMOKE COMPARTMENT NOTIFICATION APPLIANCE ZONING IS
SHOWN. PROVIDE ZONING OF NOTIFICATION APPLIANCE CIRCUITS
AND SYSTEM OPERATION AS REQUIRED BY THE NORTH CAROLINA
STATE BUILDING CODE, DHFC AND LOCAL CODE OFFICIALS.

WALL TYPE LEGEND

	1 HOUR FIRE BARRIER WALL
	1 HOUR FIRE/SMOKE BARRIER WALL
	2 HOUR FIRE BARRIER WALL
	SMOKE RESISTANT WALL

CBHF
Engineers, PLLC
2246 Yaupon Drive
Wilmington, NC 28401
Phone: 910.791.4000
www.cbhfengineers.com
© Copyright 2026 CBHF Engineers, PLLC NCH P-0506



GENERAL FIRE ALARM NOTES

- ALL ELECTRICAL WORK SHALL BE IN FULL COMPLIANCE WITH NFPA 70, THE SOUTH CAROLINA STATE BUILDING CODE, ALL LOCAL CODES AND ORDINANCES AND IN ACCORDANCE WITH THE REQUIREMENTS OF THE LOCAL AUTHORITY HAVING JURISDICTION.
- ALL EQUIPMENT PROVIDED BY THE CONTRACTOR SHALL BE LISTED AND LABELED BY A NATIONALLY RECOGNIZED TESTING AGENCY, ACCEPTABLE TO THE AUTHORITY HAVING JURISDICTION, FOR THE CONDITIONS OF INSTALLATION. ALL MATERIAL, EQUIPMENT AND DEVICES SHALL BE NEW CURRENT PRODUCTS OF MANUFACTURERS REGULARLY ENGAGED IN THE PRODUCTION OF SUCH PRODUCTS. EQUIPMENT SHALL BE SUITABLE FOR ITS APPLICATION (E.G. WHEN INSTALLED OUTDOORS, IT SHALL BE WEATHERPROOF, ETC.)
- THE CONTRACTOR SHALL REVIEW THE FIRE ALARM DRAWINGS AND SPECIFICATIONS FOR WORK REQUIREMENTS, THE AMOUNT OF SPACE AVAILABLE FOR FIRE ALARM EQUIPMENT, AND LAYOUT HIS WORK IN A COMPATIBLE AND COMPLEMENTARY MANNER.
- THE CONTRACTOR SHALL ALSO BE RESPONSIBLE FOR THOROUGHLY FAMILIARIZING HIMSELF WITH ANY CONTRACTUAL REQUIREMENTS AS MAY BE SET FORTH IN THE OTHER DIVISIONS OF THE PROJECT SPECIFICATIONS.
- UNLESS SPECIFICALLY NOTED OTHERWISE, SYSTEMS PROVIDED OR INSTALLED BY THE FIRE ALARM CONTRACTOR SHALL BE COMPLETE AND FULLY-FUNCTIONING AFTER INSTALLATION. INCIDENTAL COMPONENTS MAY NOT BE SHOWN, AND ALL WORK WHICH MAY BE REASONABLY IMPLIED AS BEING INCIDENTAL TO THIS WORK, BUT REQUIRED FOR THE PROPER OPERATION OF THE EQUIPMENT OR SYSTEM, SHALL BE PROVIDED AT NO ADDITIONAL COST TO THE OWNER.
- THE WORK SHALL INCLUDE COMPLETE TESTING OF ALL EQUIPMENT AND WIRING AT THE COMPLETION OF WORK AND ANY MINOR CORRECTIONS, CHANGES OR ADJUSTMENTS NECESSARY FOR THE PROPER FUNCTIONING OF THE SYSTEM AND EQUIPMENT.
- ALL FIRE ALARM EQUIPMENT SHALL, AT ALL TIMES DURING CONSTRUCTION, BE ADEQUATELY PROTECTED AGAINST MECHANICAL INJURY, OR DAMAGE BY WATER AND/OR THE ELEMENTS. FIRE ALARM EQUIPMENT SHALL NOT BE STORED OUT OF DOORS, BUT SHALL BE STORED IN DRY PERMANENT SHELTERS. IF AN APPARATUS HAS BEEN DAMAGED, OR HAS BEEN SUBJECT TO POSSIBLE INJURY BY WATER OR THE ELEMENTS, SUCH DAMAGE SHALL BE REPLACED AT NO ADDITIONAL COST TO THE OWNER.
- DO NOT SCALE FIRE ALARM DRAWINGS. FIELD VERIFY ALL DIMENSIONS.
- FIRE ALARM DEVICE LAYOUTS ARE NOT INTENDED TO SHOW THE NUMBER OF FITTINGS, OR OTHER INSTALLATION DETAILS. UNLESS NOTED OTHERWISE, THE EXACT ROUTING OF RACEWAYS AND CABLES IS THE RESPONSIBILITY OF THE CONTRACTOR. RISER AND GENERAL CIRCUIT ARRANGEMENTS ARE SHOWN SCHEMATICALLY/DIAGRAMMATICALLY ONLY. THE CONTRACTOR SHALL ROUTE CONDUITS AS REQUIRED BY THE CONDITIONS OF THE INSTALLATION.
- UNLESS DIMENSIONED, DEVICE LOCATIONS SHOWN ON THE DRAWINGS ARE APPROXIMATE. ADJUST EXACT LOCATIONS AS REQUIRED TO SERVE THE INTENDED PURPOSE AND TO AVOID CONFLICTS AND INTERFERENCES WITH OTHER TRADES. EXACT DEVICE LOCATIONS IF NOT SHOWN ON THE FIRE ALARM DRAWINGS OR DIMENSIONED ON THE FIRE ALARM DRAWINGS, VERIFY EXACT LOCATION WITH THE ENGINEER PRIOR TO ROUGH-IN.
- CONDUIT TERMINATING IN PRESSED STEEL BOXES SHALL HAVE DOUBLE LOCKNUTS AND INSULATED BUSHINGS. CONDUITS TERMINATING IN GASKETED ENCLOSURES SHALL BE TERMINATED WITH GROUNDING TYPE CONDUIT HUBS.
- ALL EXTERIOR WIRING DEVICES, BOXES, ETC. SHALL BE WEATHERPROOF. FIRE ALARM DEVICES SHALL BE APPROPRIATELY RATED AND LISTED FOR THE ENVIRONMENT.
- MAINTAIN CEILING FIRE RATINGS WITH ALL NECESSARY ACCESSORIES, OPTIONS AND/OR FIELD FABRICATED SHROUDS COMPLYING WITH ALL APPLICABLE CODES.
- RACEWAYS PENETRATING FLOORS, CEILINGS OR WALLS SHALL BE PROPERLY SEALED SMOKE-TIGHT.
- ALL RACEWAYS SHALL BE CONCEALED WHERE POSSIBLE. IF APPLICABLE, MATCH EXISTING RACEWAY INSTALLATION METHODS AND ROUTINGS AT OR NEAR EXISTING FACILITIES.
- INSTALL EXPOSED RACEWAYS PARALLEL TO OR AT RIGHT ANGLES TO NEARBY SURFACES OR STRUCTURAL MEMBERS, AND FOLLOW THE SURFACE CONTOURS AS MUCH AS POSSIBLE. NO DIAGONAL RUNS WILL BE RUN STRAIGHT AND TRUE. RUN PARALLEL OR BANKED RACEWAYS TOGETHER ON COMMON SUPPORTS WHERE PRACTICAL. MAKE BENDS IN PARALLEL OR BANKED RUNS FROM SAME CENTERLINE TO MAKE BENDS PARALLEL.
- PROVIDE AND PLACE ALL SLEEVES FOR CONDUITS PENETRATING WALLS, FLOORS, PARTITIONS, ETC. LOCATE ALL NECESSARY SLOTS FOR ELECTRICAL WORK AND FORM BEFORE CONCRETE IS POURED.
- PATCHING OF WATERPROOFED SURFACES SHALL RENDER THE AREA OF THE PATCHING COMPLETELY WATERPROOF.
- SURFACE MOUNTED PANELS, JUNCTION AND PULL BOXES, RACEWAYS, ETC., INSTALLED ON EXTERIOR SURFACES OR INSIDE ON EXTERIOR WALLS SHALL BE SUPPORTED BY SPACERS TO PROVIDE A 1/4" MINIMUM CLEARANCE BETWEEN THE WALL AND EQUIPMENT.
- CEILING MOUNTED DEVICES INSTALLED IN ACOUSTICAL TILE CEILING AREAS SHALL BE SUPPORTED FROM THE STRUCTURE ABOVE WITH RODS OF SUFFICIENT SIZE TO PREVENT VERTICAL MOVEMENT OF THE DEVICE BOX. BRIDGES ALONE ARE NOT ADEQUATE UNLESS SPECIFICALLY APPROVED. CEILING MOUNTED DEVICES SHALL BE INSTALLED LEVEL. DO NOT SUPPORT DEVICES FROM ACOUSTICAL CEILING TILE.
- COORDINATE LOCATIONS OF FIRE ALARM DEVICES BEFORE ROUGH-IN. ADVISE THE ENGINEER OF CONFLICTS BEFORE ROUGH-IN.
- EXACT SPACING OF SMOKE AND HEAT DETECTORS BE FOLLOWED AS CLOSELY AS POSSIBLE WITH POSITIONS SHOWN ON THE DRAWINGS. DETECTOR SPACING IS BASED UPON NFPA 72 INCLUDING APPENDIX A. SLIGHT ADJUSTMENTS MAY BE MADE IN SPACING IF REQUIRED BY FIELD CONDITIONS, BUT SPACING SHALL NOT EXCEED ADA, NFPA AND EQUIPMENT MANUFACTURERS SPACING CRITERIA. DO NOT INSTALL SMOKE DETECTORS WITHIN 3 FEET OF SUPPLY AIR DIFFUSERS OR RETURN GRILLES. PROVIDE FLEX CONDUIT CONNECTION TO SMOKE AND HEAT DETECTORS OF ADEQUATE LENGTH TO ALLOW HORIZONTAL ADJUSTMENT OF FOUR FEET FROM POSITION INDICATED ON DRAWINGS.
- INSTALLATION INFORMATION PACKED WITH DEVICES AND EQUIPMENT SHALL BE RETAINED FOR INCLUSION IN THE OPERATIONS AND MAINTENANCE MANUALS.
- INSTALL WORK AT SUCH TIME AS TO REQUIRE THE MINIMUM AMOUNT TO CUTTING AND PATCHING.
- CUT OPENINGS ONLY LARGE ENOUGH TO ALLOW EASY INSTALLATION OF THE CONDUIT.


NOT FINAL. SUBJECT TO REVISION. NOT FOR PERMITTING. FABRICATION, MATERIAL OR EQUIPMENT PURCHASE, INSTALLATION, OR CONSTRUCTION. PRICING SHALL STATE ALL ASSUMPTIONS, EXCLUSIONS, ALLOWANCES, AND CONTINGENCES AND SHALL BE RECONCILED WITH THE FINAL SIGNED AND SEALED DOCUMENTS.

PRINCIPLE HEALTH CARE
WAKE COUNTY
Holly Springs, North Carolina

David R. Polston - Architect
3806 Park Ave. Suite C, Wilmington, NC 28403
Architecture Planning Design

120 BED
NURSING FACILITY
FIRE ALARM SYSTEM
NOTES AND ZONE PLAN

FA
0.2

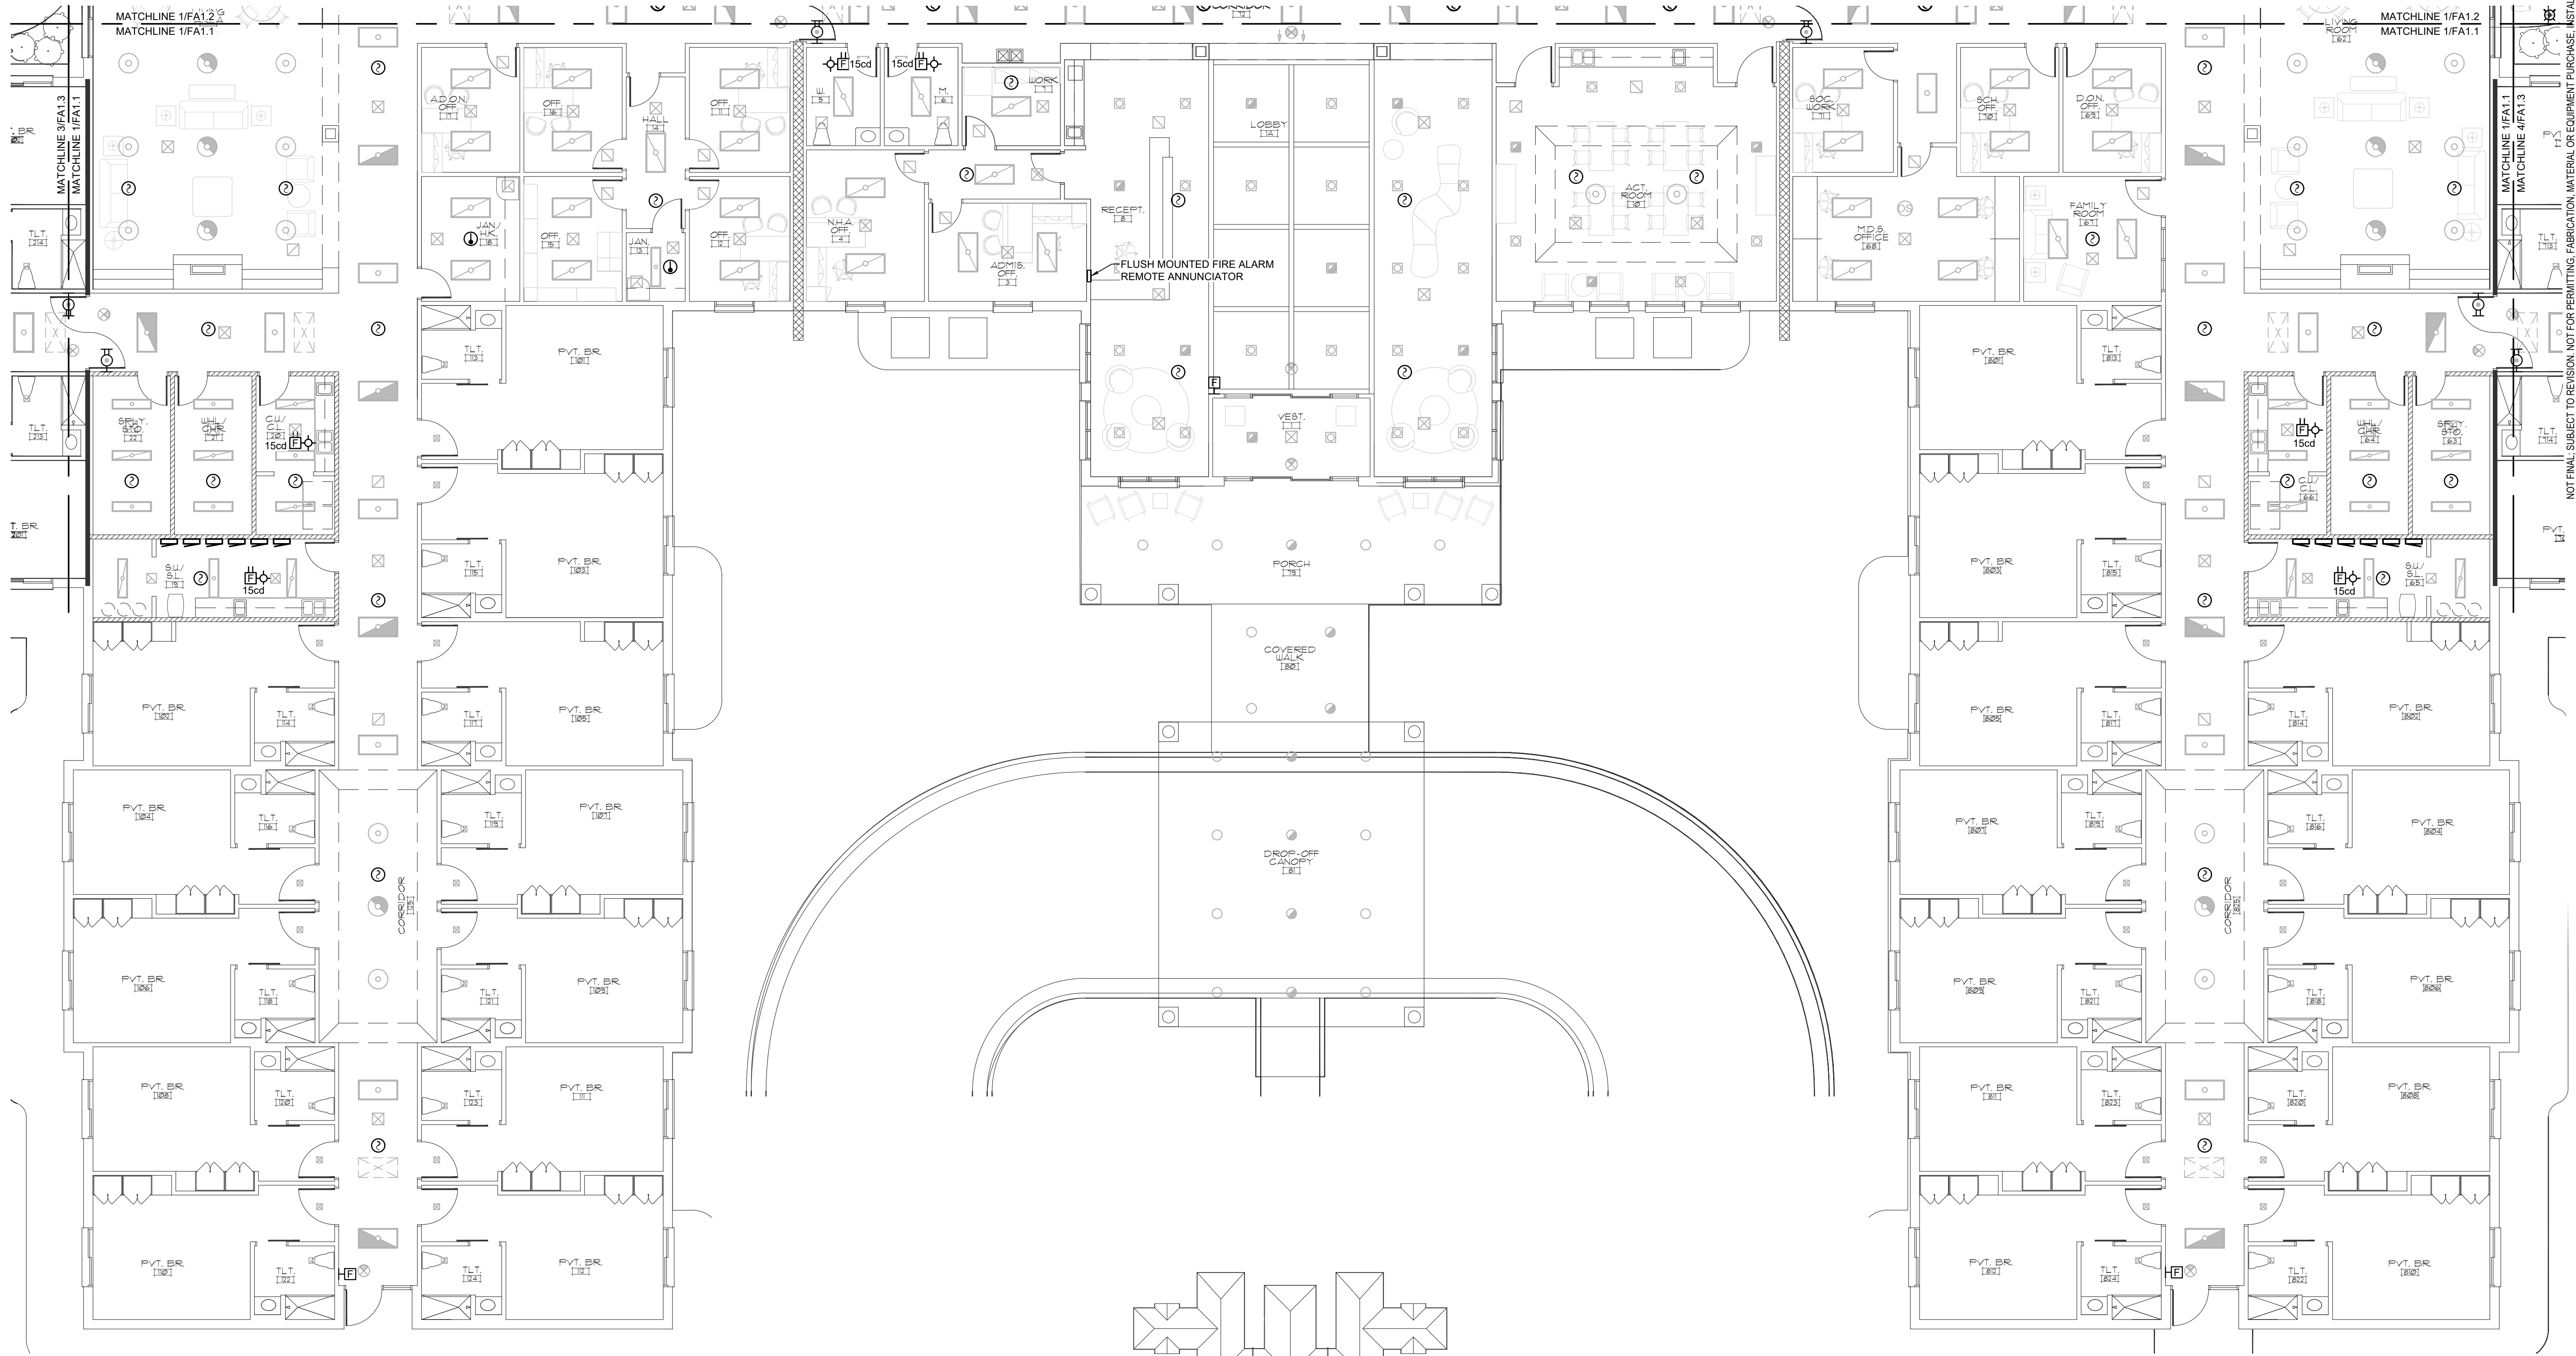

WALL TYPE LEGEND	
	1 HOUR FIRE BARRIER WALL
	1 HOUR FIRE/SMOKE BARRIER WALL
	2 HOUR FIRE BARRIER WALL
	SMOKE RESISTANT WALL

CBHF
Engineers, PLLC
 2246 Yaupon Drive
 Wilmington, NC 28401
 Phone: 910.791.4000
 www.cbhfengineers.com
 © Copyright 2026 CBHF Engineers, PLLC NCH P-0506

120 BED
 NURSING FACILITY
 FIRE ALARM SYSTEM
 PARTIAL FLOOR PLAN

David R. Polston - Architect
 3806 Park Ave. Suite C, Wilmington, NC 28403
 Architecture Planning Design

PRINCIPLE HEALTH CARE
WAKE COUNTY
 Holly Springs, North Carolina

FA 1.1

1

PARTIAL FIRE ALARM PLAN
 1/8" = 1'-0"

0 4' 8' 16'

PLAN NORTH



0

KEYPLAN
 NOT TO SCALE

NOT FINAL. SUBJECT TO REVISION. NOT FOR PERMITTING, FABRICATION, MATERIAL OR EQUIPMENT PURCHASE, INSTALLATION, OR CONSTRUCTION. PRICING SHALL STATE ALL ASSUMPTIONS, EXCLUSIONS, ALLOWANCES, AND CONTINGENCIES AND SHALL BE RECONCILED WITH THE FINAL SIGNED AND SEALED DOCUMENTS.



1
PARTIAL FIRE ALARM PLAN
1/8" = 1'-0"

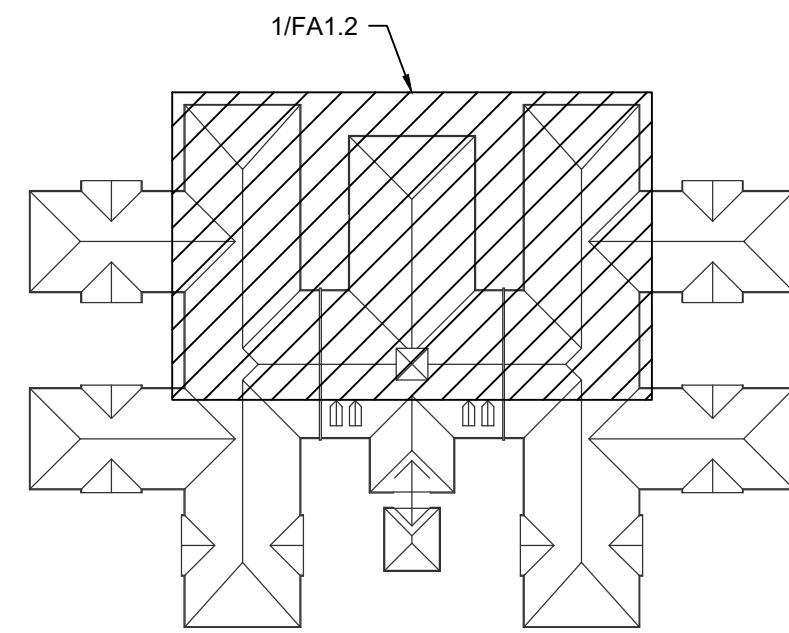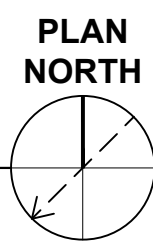

0
KEYPLAN
NOT TO SCALE


CARBON MONOXIDE DETECTOR PLACEMENT NOTES:

- A. PROVIDE CARBON MONOXIDE (CO) DETECTION IN AREAS WHERE FUEL-BURNING APPLIANCES ARE INSTALLED, INCLUDING BUT NOT LIMITED TO COMMERCIAL KITCHENS AND LAUNDRY ROOMS WITH GAS-FIRED EQUIPMENT.
- B. INSTALL CO DETECTORS AS SHOWN AND IN THE SAME ROOM AS FUEL-BURNING APPLIANCES AND/OR IN ADJACENT SPACES WHERE CO CAN MIGRATE, IN ACCORDANCE WITH MANUFACTURER'S INSTRUCTIONS AND APPLICABLE CODES.
- C. LOCATE DETECTORS ON WALLS OR CEILINGS AS SHOWN AND PER MANUFACTURER'S REQUIREMENTS; DO NOT INSTALL WITHIN DEAD AIR SPACES, DIRECTLY ABOVE APPLIANCES, OR IN AREAS SUBJECT TO EXCESSIVE MOISTURE, GREASE, OR AIR TURBULENCE.
- D. CO ALARM ACTIVATION SHALL INITIATE A DISTINCT SUPERVISORY OR ALARM SIGNAL AS REQUIRED BY CODE AND SHALL NOT BE SILENCED BY NORMAL FIRE ALARM ACKNOWLEDGE FUNCTIONS.
- E. CO DETECTORS SHALL BE LISTED FOR COMMERCIAL APPLICATIONS AND INSTALLED IN ACCORDANCE WITH NFPA 720 (WHERE ADOPTED) OR NFPA 72 REQUIREMENTS FOR CO DETECTION.
- F. CO DETECTOR LOCATIONS AND QUANTITIES SHALL BE COORDINATED WITH THE FIRE ALARM SYSTEM DESIGNER AND AUTHORITY HAVING JURISDICTION (AHJ) PRIOR TO INSTALLATION.

WALL TYPE LEGEND

- 1 HOUR FIRE BARRIER WALL
1 HOUR FIRE/SMOKE BARRIER WALL
2 HOUR FIRE BARRIER WALL
SMOKE RESISTANT WALL

CBHF
Engineers, PLLC
2246 Yaupon Drive
Wilmington, NC 28401
Phone: 910.791.4000
www.cbhfengineers.com
© Copyright 2026 CBHF Engineers, PLLC NCH P-0506

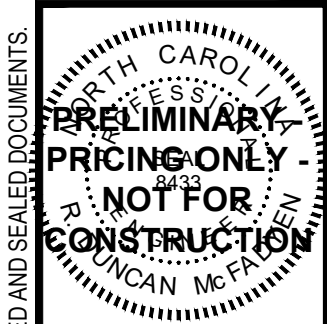



PRINCIPLE HEALTH CARE
WAKE COUNTY
Holly Springs, North Carolina

David R. Polston - Architect
3806 Park Ave. Suite C, Wilmington, NC 28403
Architecture Planning Design

120 BED
NURSING FACILITY
FIRE ALARM SYSTEM
PARTIAL FLOOR PLAN


FA
1.2

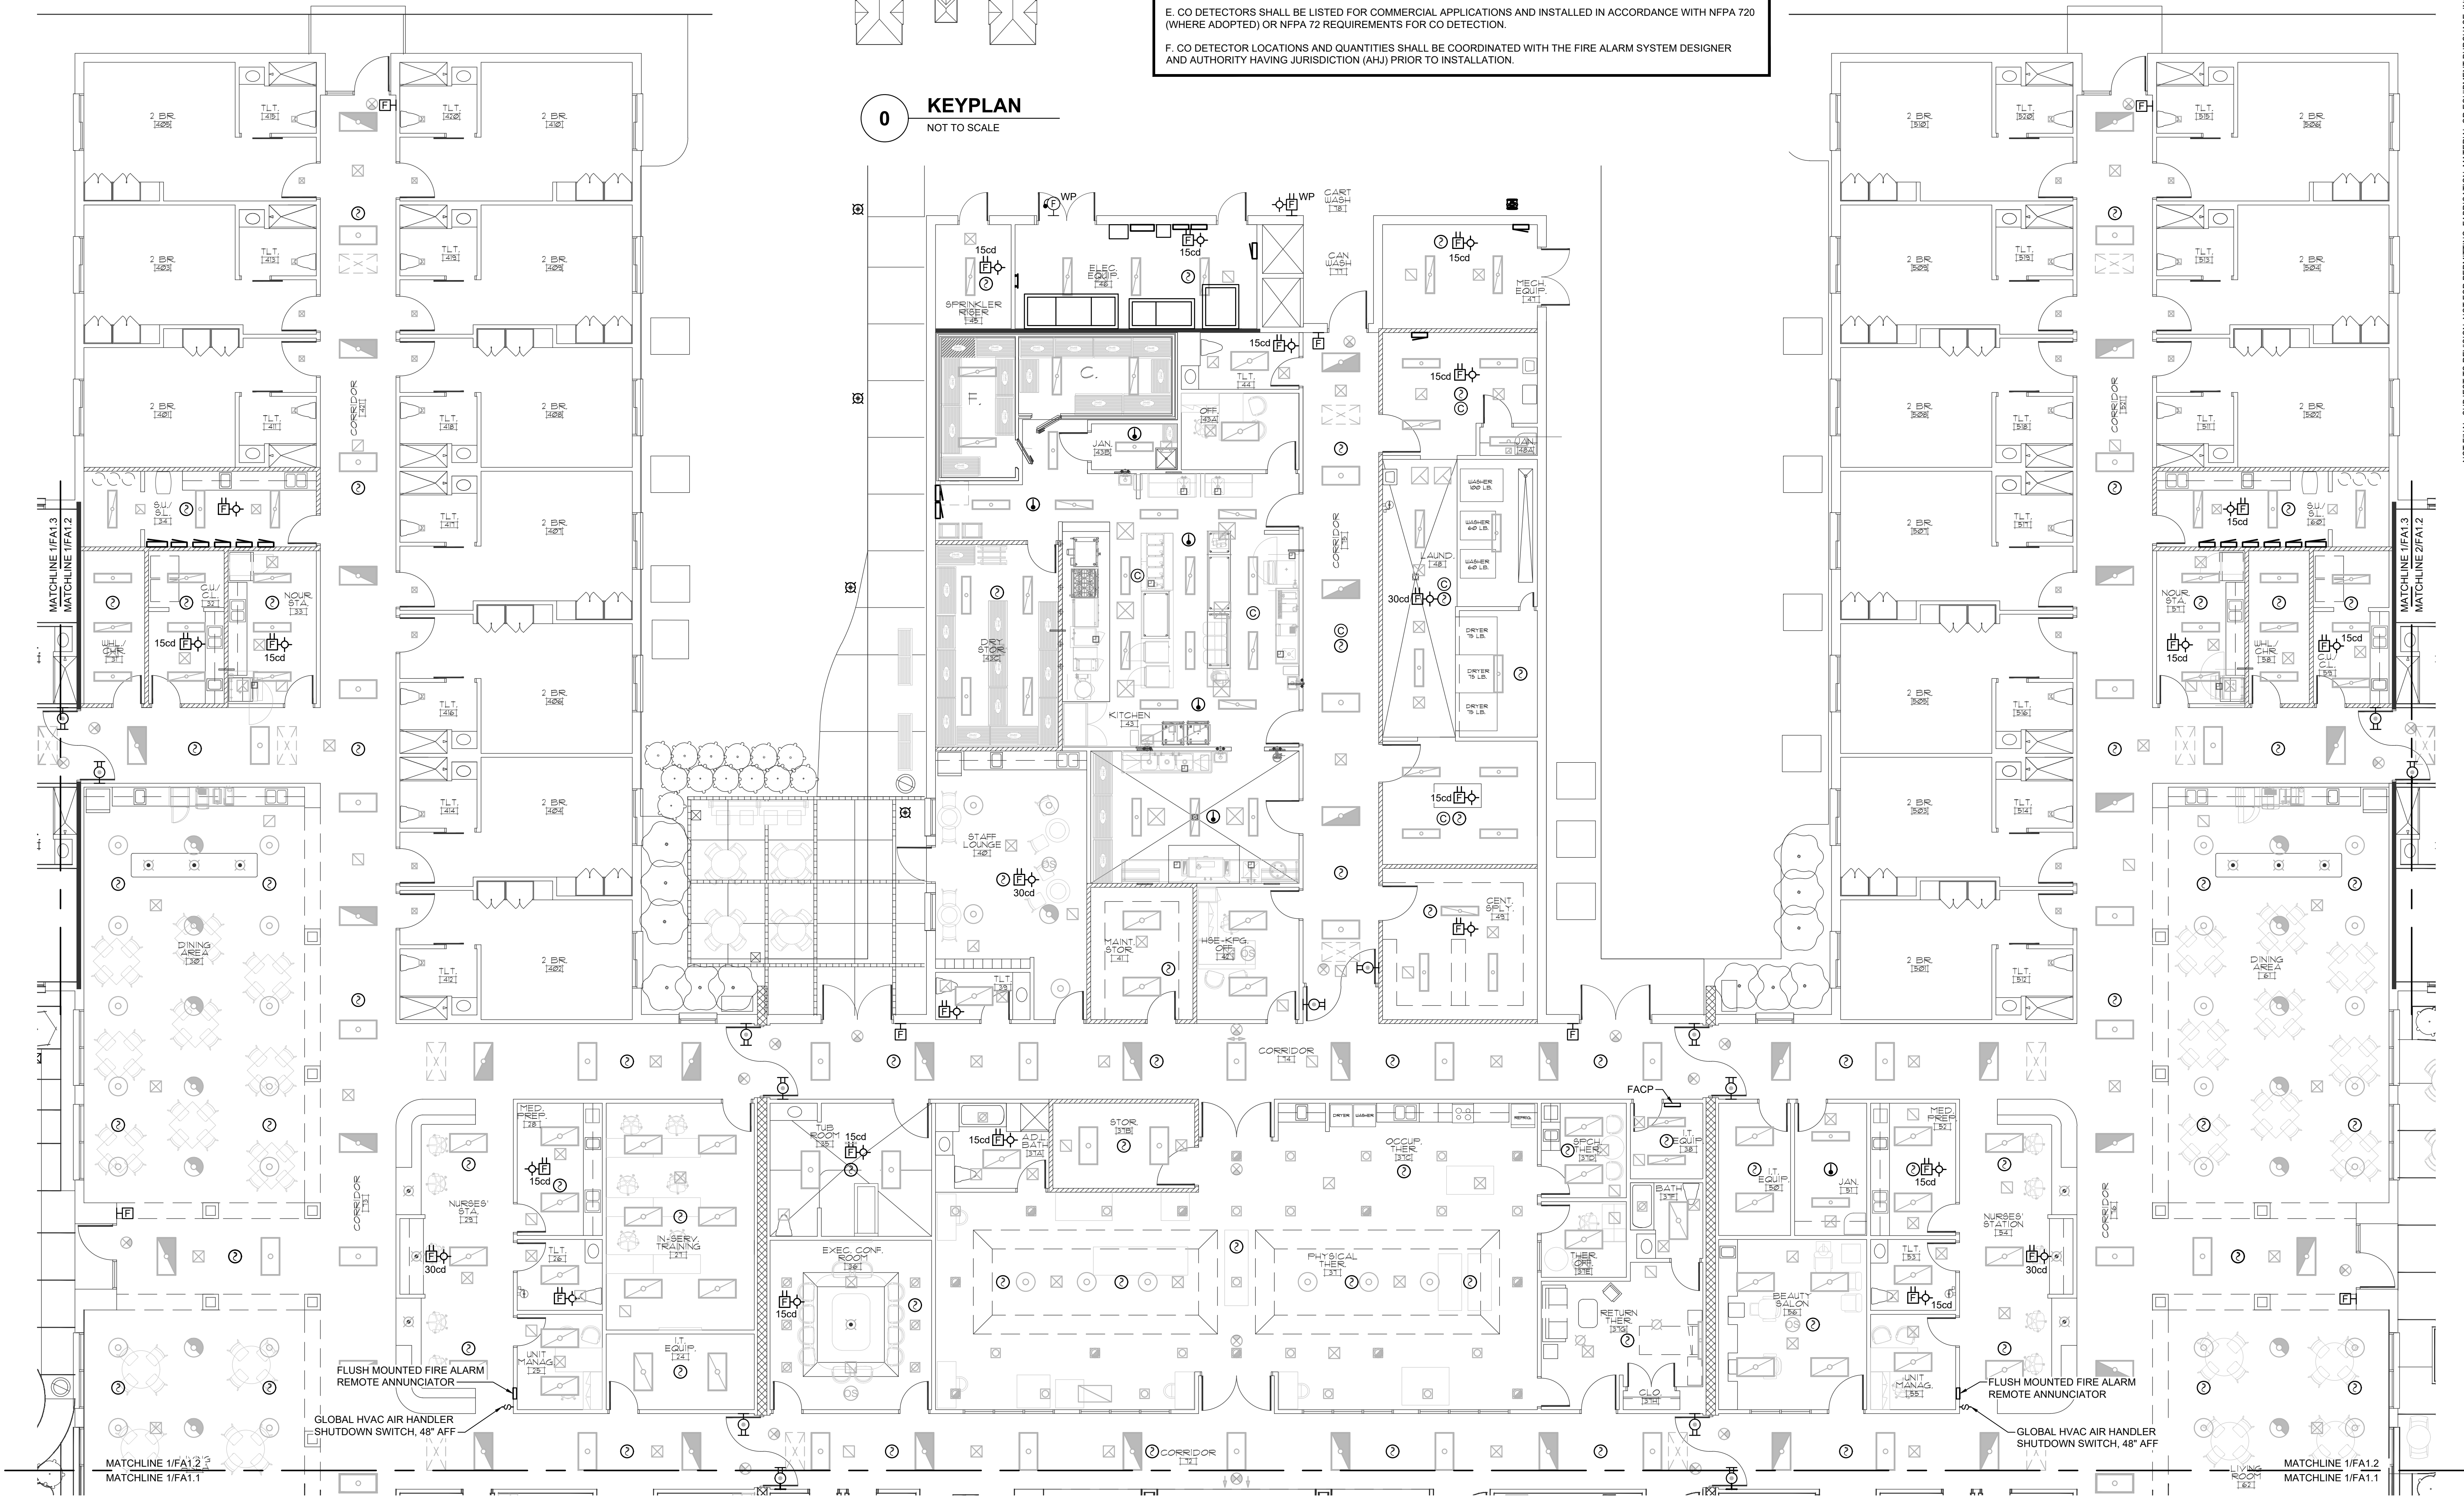

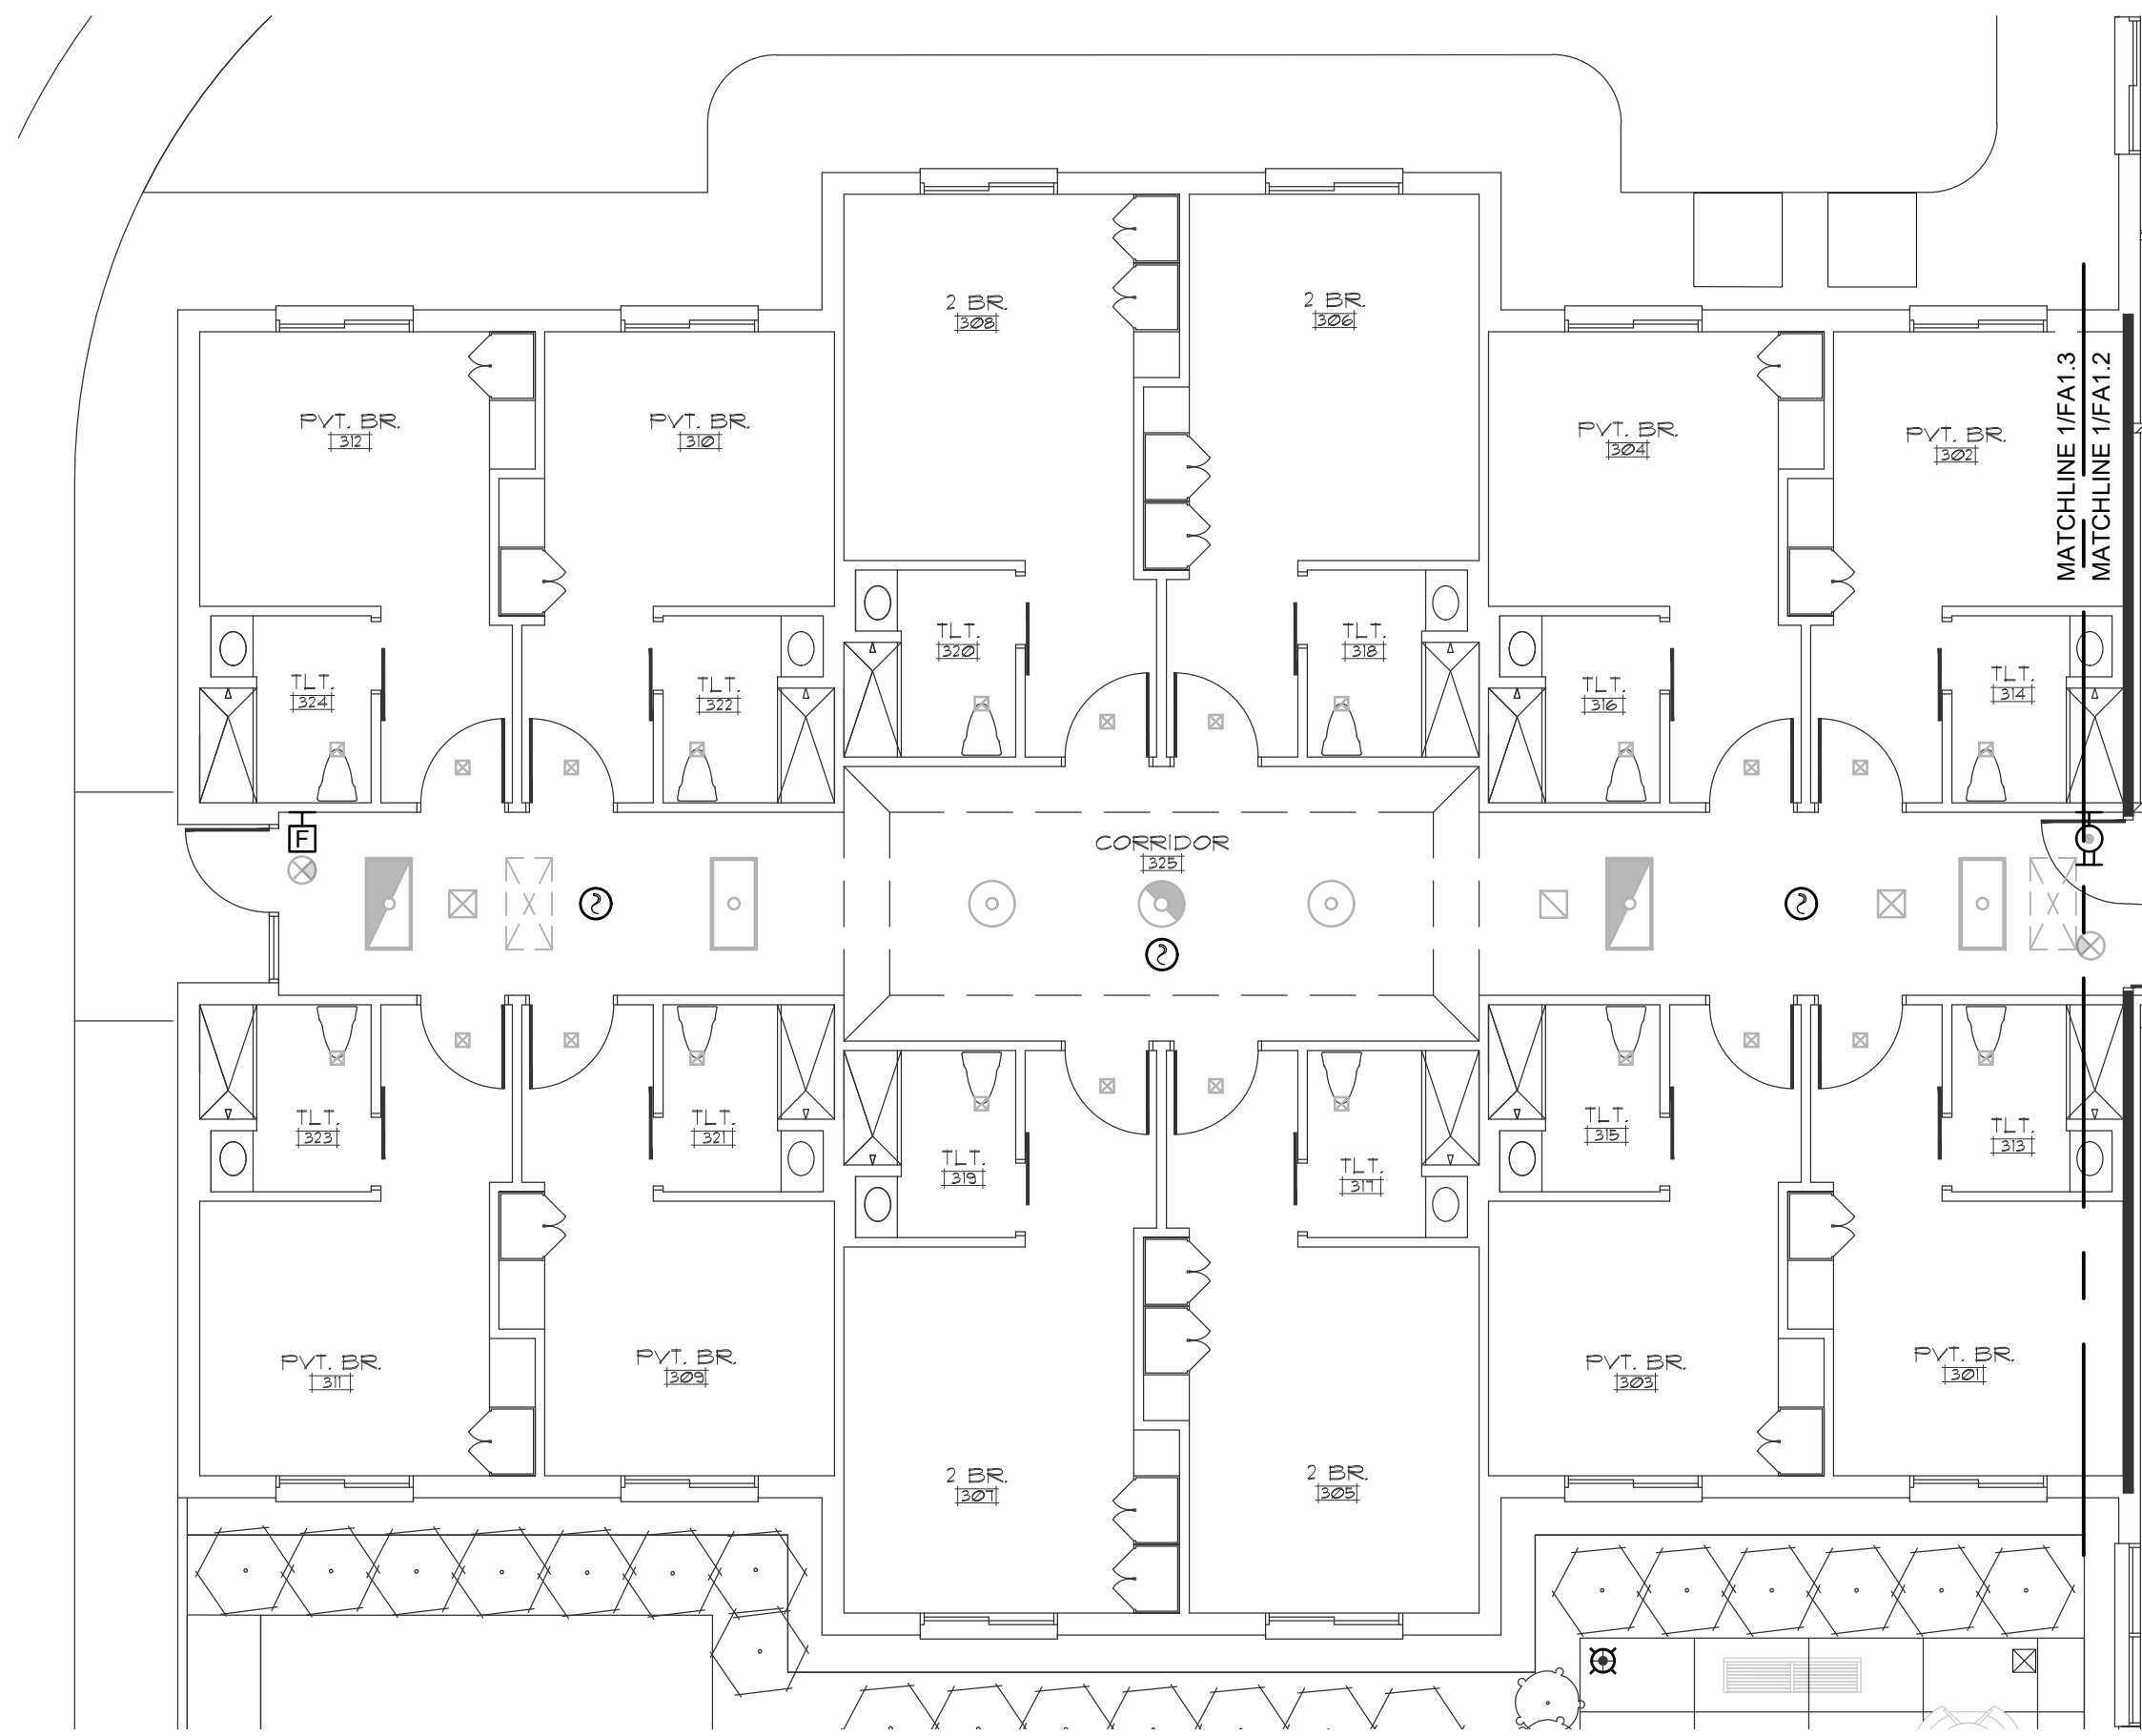


1 PARTIAL FIRE ALARM PLAN
1/8" = 1'-0"
0 4' 8' 16'

PLAN NORTH

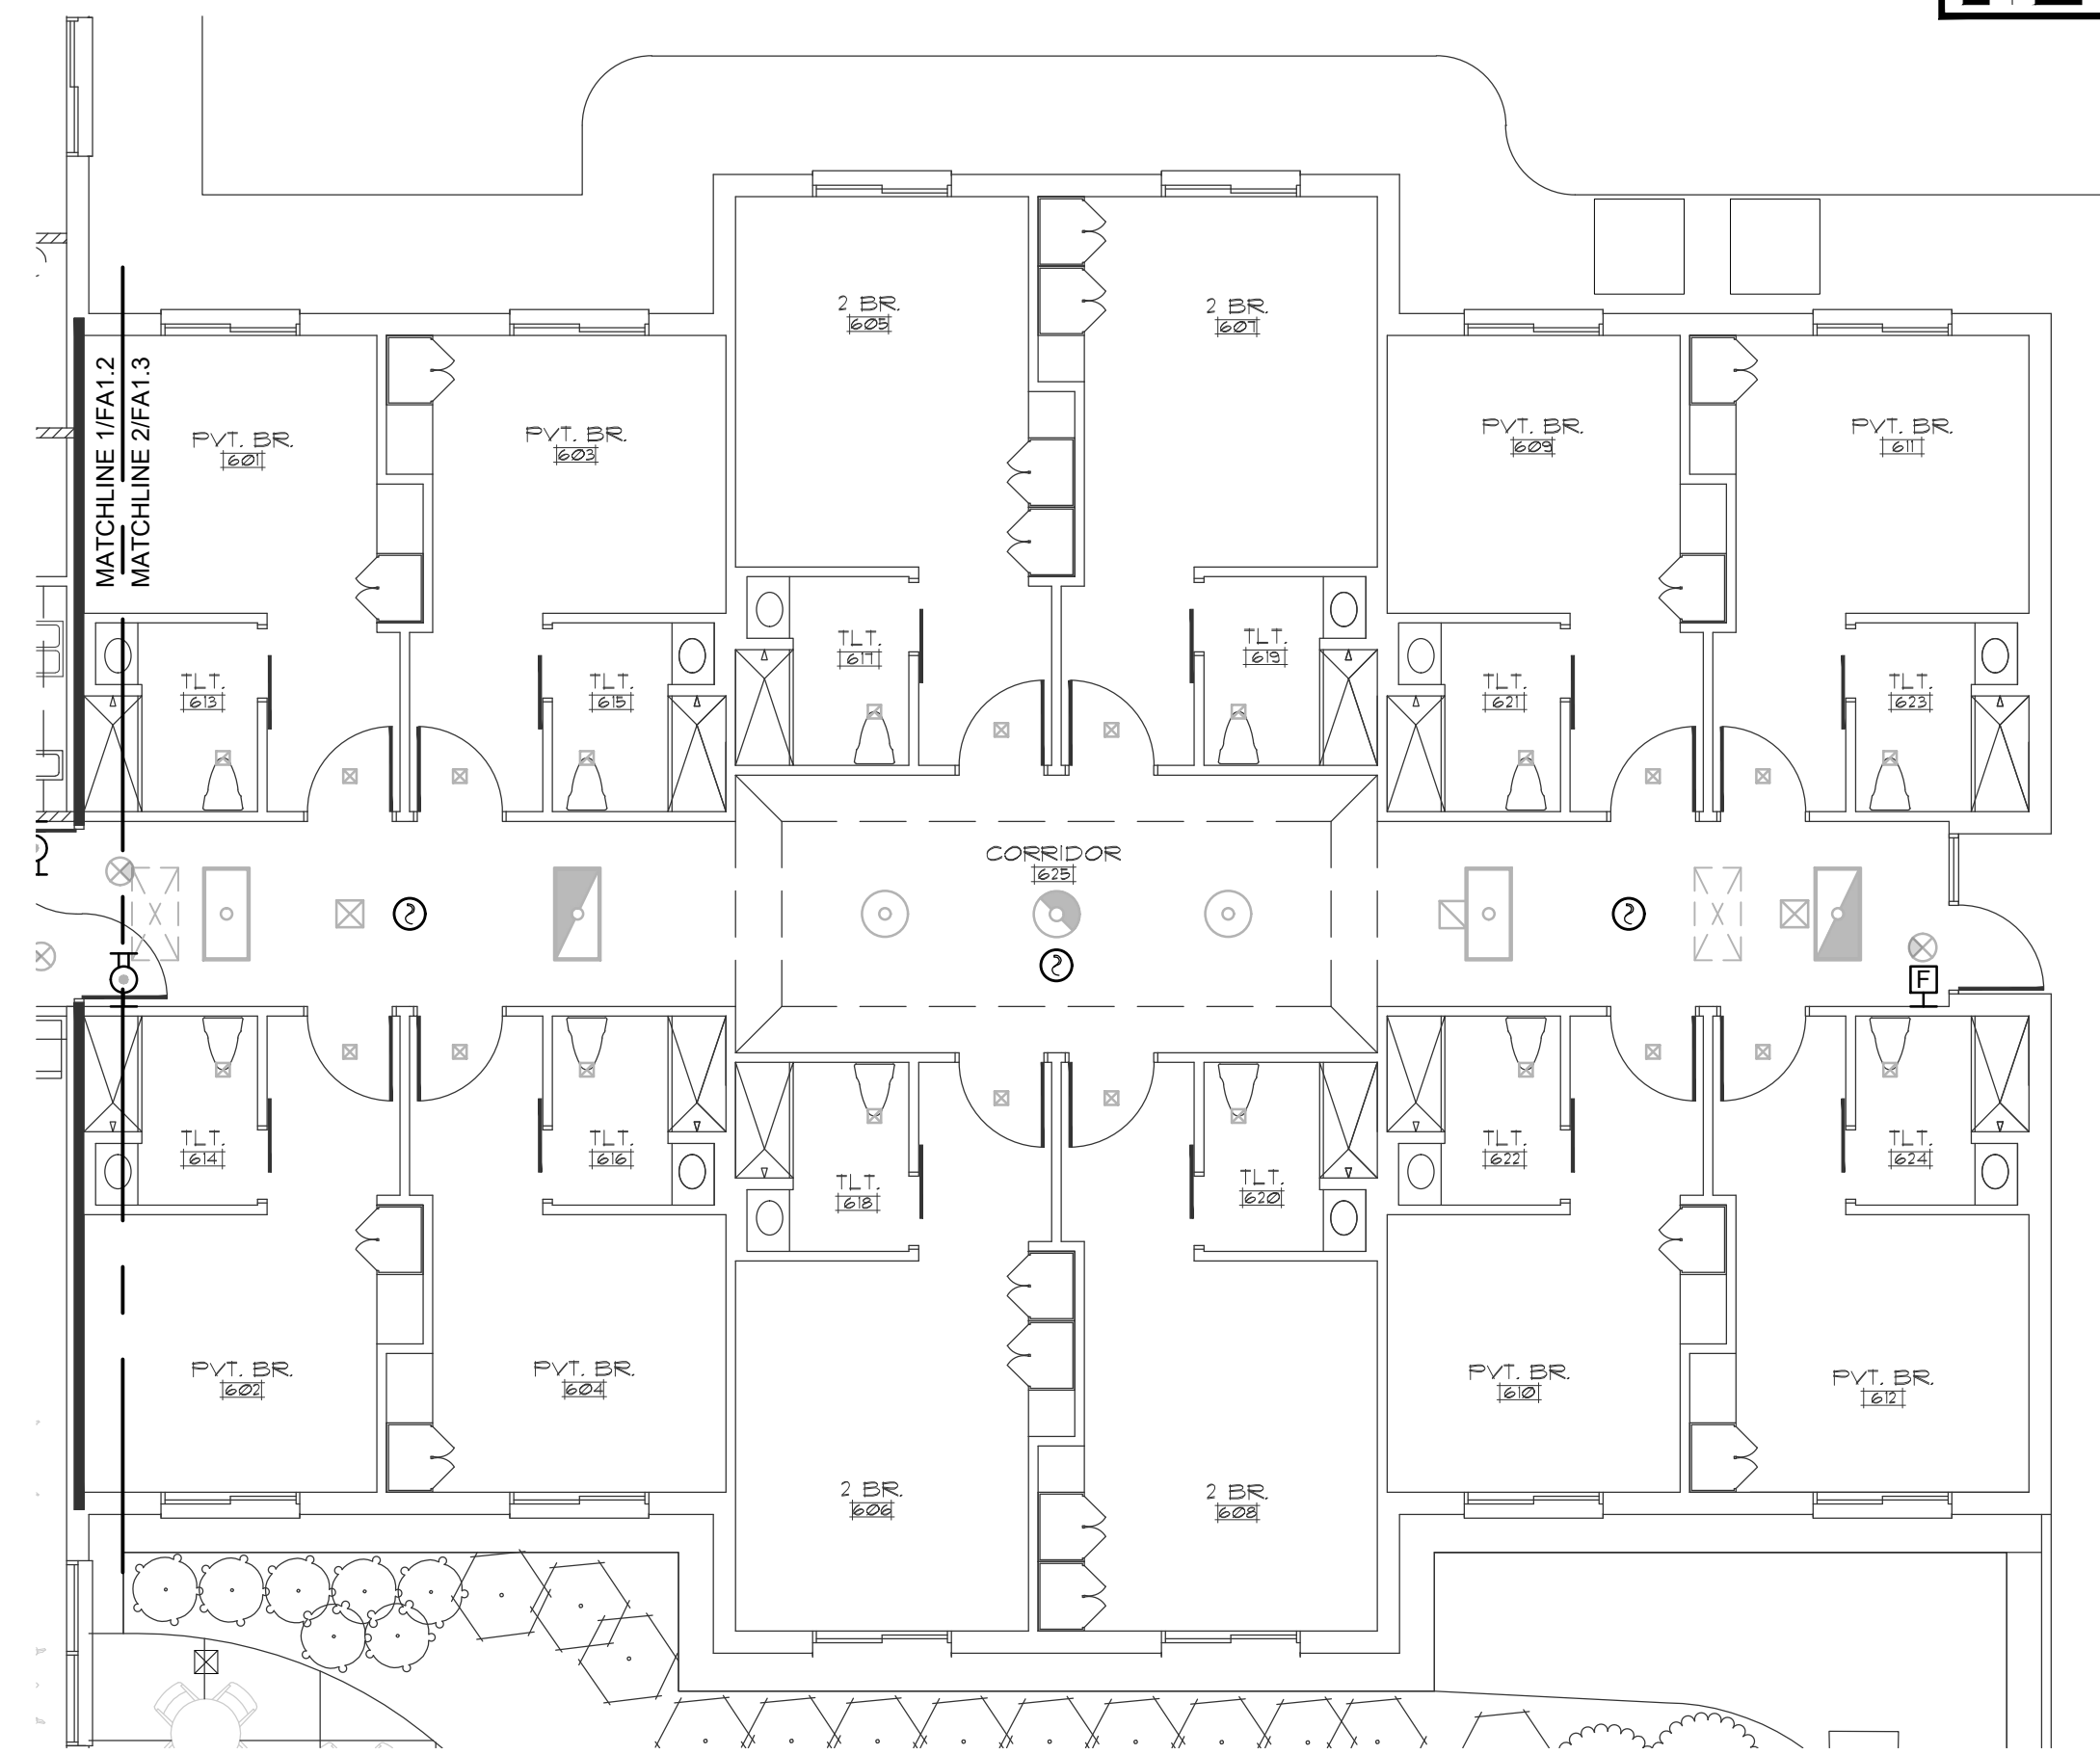


2 PARTIAL FIRE ALARM PLAN
1/8" = 1'-0"
0 4' 8' 16'

PLAN NORTH

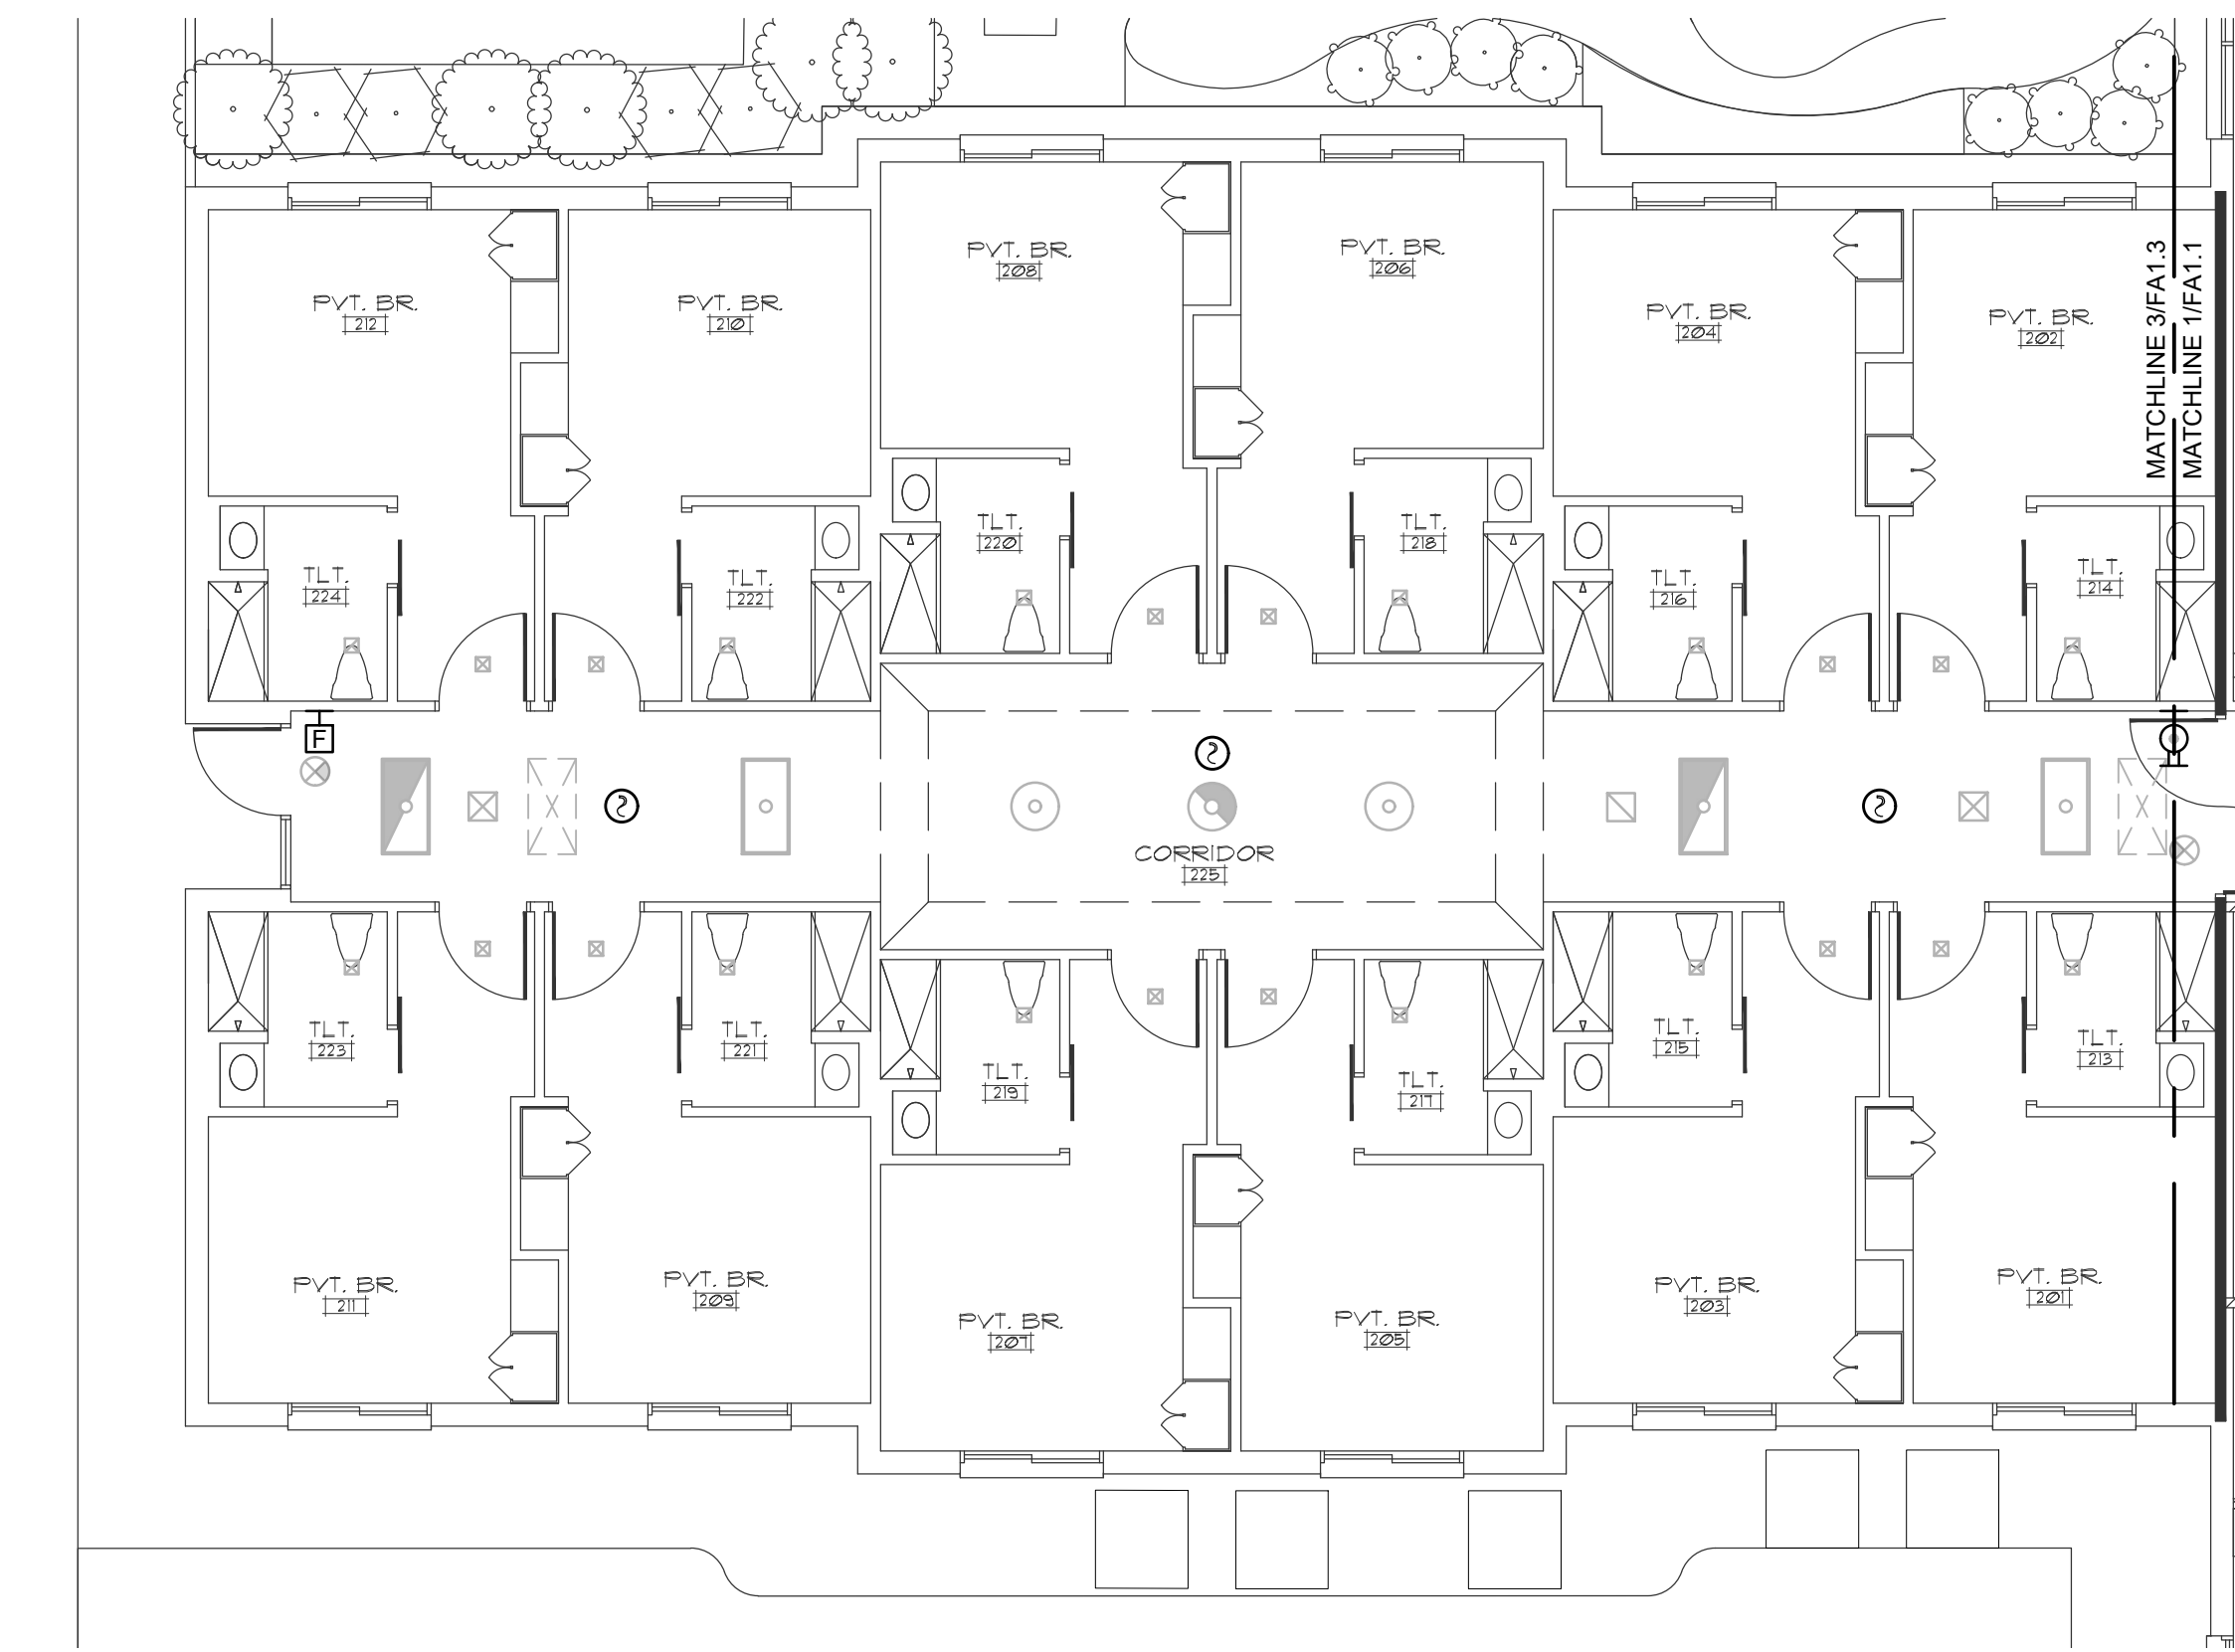

3 PARTIAL FIRE ALARM PLAN
1/8" = 1'-0"
0 4' 8' 16'

PLAN NORTH

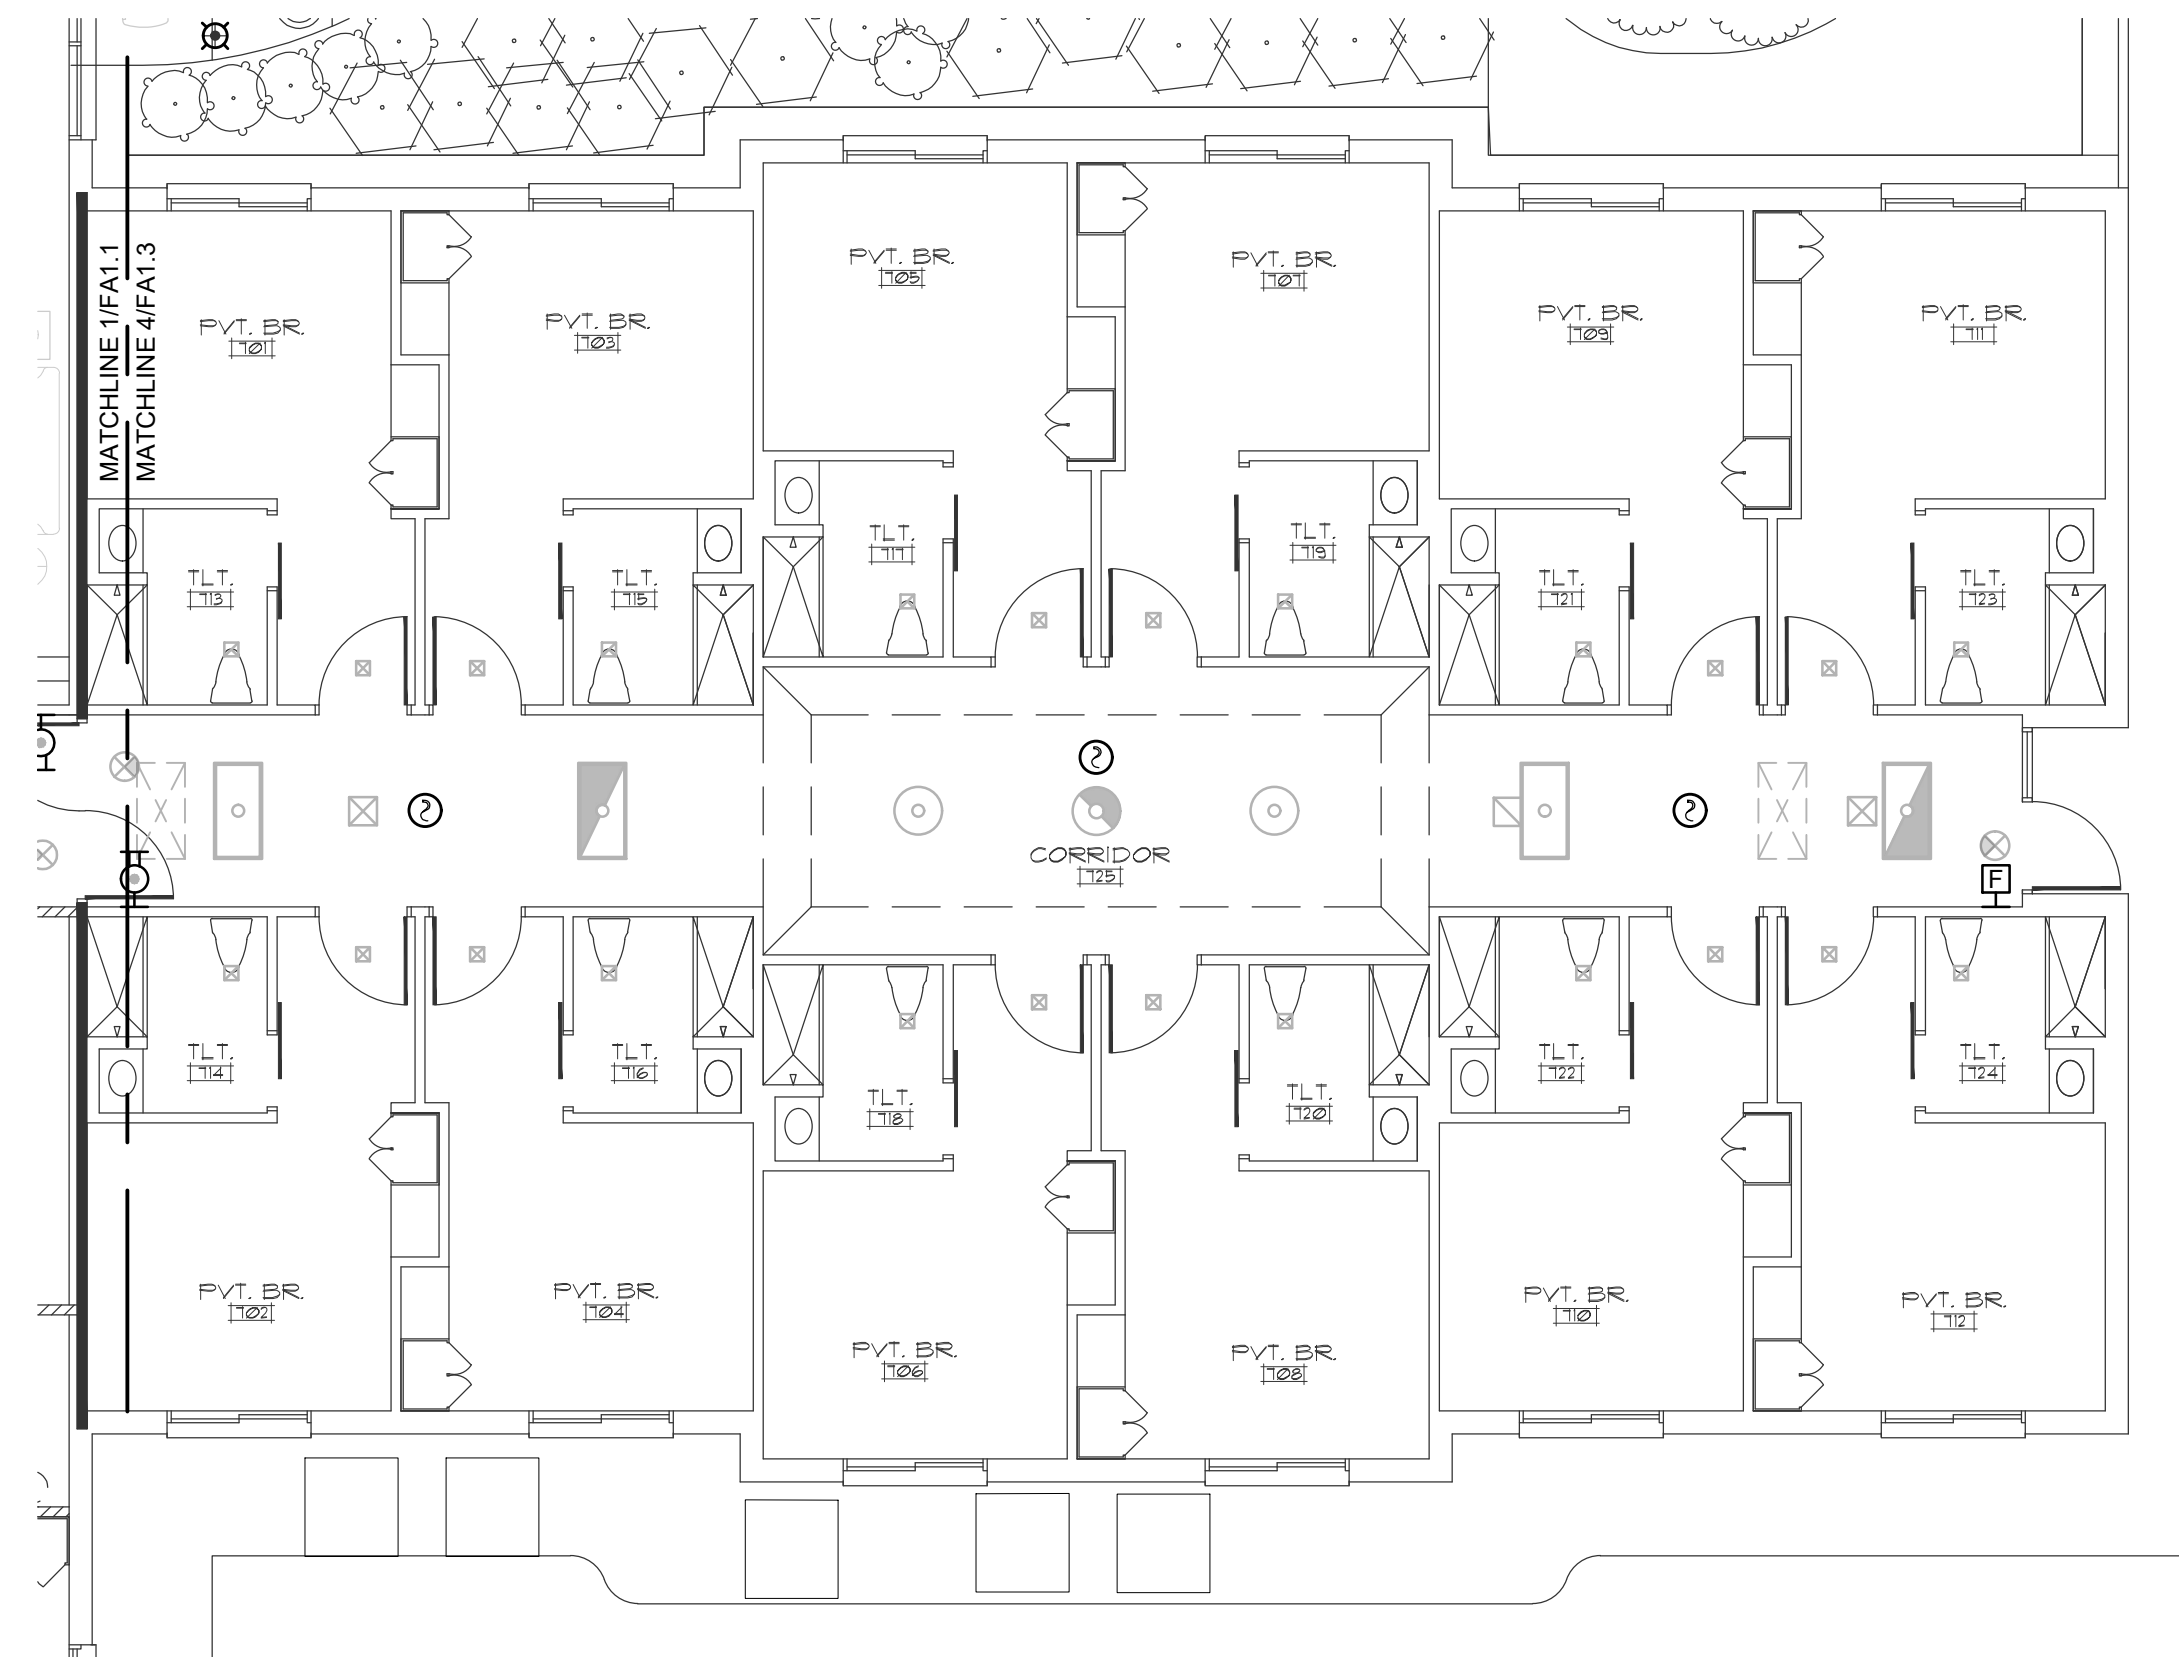


4 PARTIAL FIRE ALARM PLAN
1/8" = 1'-0"
0 4' 8' 16'

PLAN NORTH

WALL TYPE LEGEND	
	1 HOUR FIRE BARRIER WALL
	1 HOUR FIRE/SMOKE BARRIER WALL
	2 HOUR FIRE BARRIER WALL
	SMOKE RESISTANT WALL

CBHF
Engineers, PLLC
2246 Yaupon Drive
Wilmington, NC 28401
Phone: 910.791.4000
www.cbhfengineers.com
© Copyright 2026 CBHF Engineers, PLLC NC# P-0506

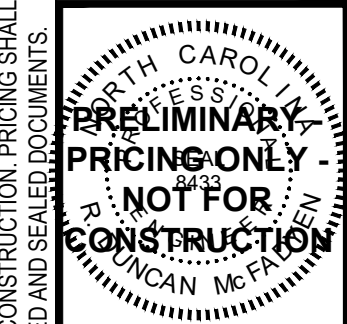


PRINCIPLE HEALTH CARE
WAKE COUNTY
Holly Springs, North Carolina

David R. Polston - Architect
3806 Park Ave. Suite C, Wilmington, NC 28403
Architecture Planning Design

120 BED
NURSING FACILITY
FIRE ALARM SYSTEM
PARTIAL FLOOR PLAN

F
1.3

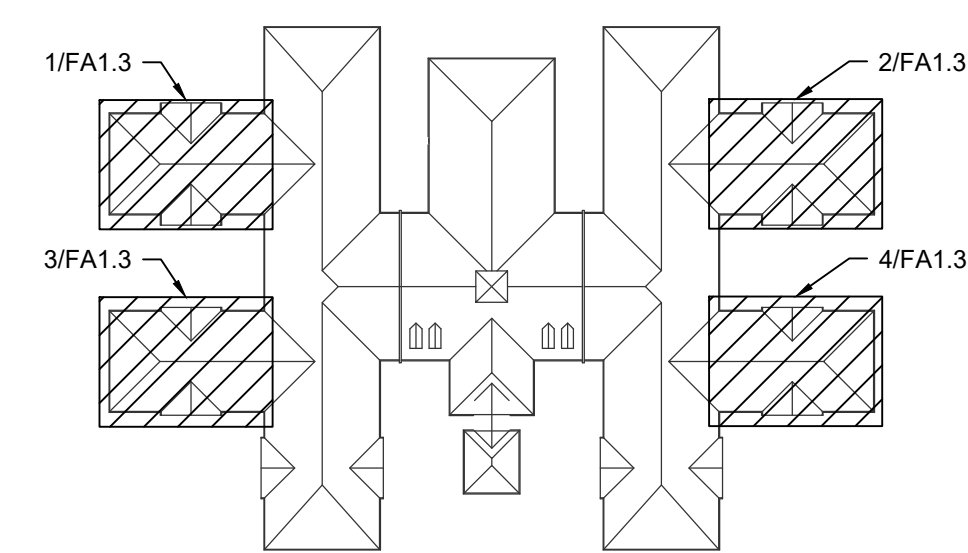

0 KEYPLAN
NOT TO SCALE

NOT FINAL SUBJECT TO REVISION. NOT FOR PERMITTING, FABRICATION, MATERIAL OR EQUIPMENT PURCHASE, INSTALLATION, OR CONSTRUCTION. PRICING SHALL STATE ALL ASSUMPTIONS, EXCLUSIONS, ALLOWANCES, AND CONTINGENCIES AND SHALL BE RECONCILED WITH THE FINAL SIGNED AND SEALED DOCUMENTS.